
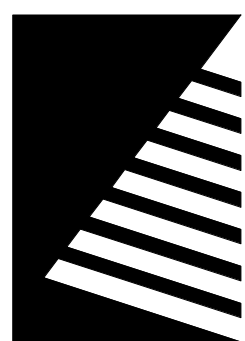


FOODSERVICE EQUIPMENT SCHEDULE - AREA C			
ITEM #	QTY	DESCRIPTION	REMARKS
100	7	HAND SINK	
101A	5	PAN STORAGE SHELVING	
101B	6	PAN STORAGE SHELVING	EXISTING/OWNER TO RELOCATE
102	3	MOBILE LUG RACK	
103	1	UTILITY CART	EXISTING/OWNER TO RELOCATE
104	1	WORKCOUNTER W/SINKS	
105	8	MOBILE TRASH BIN	EXISTING/OWNER TO RELOCATE
106	1	OPEN NUMBER	
107	1	SPRAY RINSE	
108	1	WALL SHELF	
109	1	FOOD PROCESSOR	EXISTING/OWNER TO RELOCATE
110	1	OPEN NUMBER	
111	21	STAINLESS STEEL CORNER GUARD	
112	1	REACH-IN REFRIGERATOR, 2-SEC.	EXISTING/RELOCATE
113	1	MOBILE EQUIPMENT STAND	
114	1	SLICER	EXISTING/OWNER TO RELOCATE
115	2	DOUBLE WIDE WORKTABLE	
116	1	HORIZONTAL CUTTER/MIXER	ADD ALTERNATE
117	1	FLOOR TROUGH	
118	1	HOSE STATION	
119	1	HOSE STATION SECURITY CABINET	
120-127	1	OPEN NUMBER	
128	5	CHEMICAL STORAGE SHELVING	
129	1	MOBILE WORKTABLE	
130	1	OPEN NUMBER	
131	2	CHEMICAL STORAGE SHELVING	EXISTING/OWNER TO RELOCATE
132	1	STACKED WASHER/DRYER	
133	1	OPEN NUMBER	
134	3	STAINLESS STEEL WALL CAP	
135-139	1	OPEN NUMBER	
140	2	MOBILE WORKTABLE	
141	2	WORKCOUNTER	EXISTING/RELOCATE/MODIFY
142	5	MOBILE WARMING CABINET	
143	16	MOBILE RACK	EXISTING/OWNER TO RELOCATE
144	1	80 QUART MIXER	EXISTING/RELOCATE
145	1	WORKCOUNTER W/SINKS	
146	1	WORKCOUNTER W/SINKS	
147	2	SHEET PAN DOLLY	
148	1	EXHAUST HOOD (TYPE I)	
149	1	STAINLESS STEEL WALL PANEL	
150	1	UTILITY DISTRIBUTION SYSTEM	
151	1	FIRE PROTECTION SYSTEM	
152	1	OPEN NUMBER	
153	1	DEMAND CONTROL VENTILATION SYSTEM	
154	2	60 GALLON KETTLE	
155	2	80 GALLON KETTLE	
156	1	FLOOR TROUGH	
157	1	OPEN NUMBER	
158	2	STEAMER, 2-SEC.	EXISTING/RELOCATE
159	1	OPEN NUMBER	
160	1	STEAMER, 2-SEC.	EXISTING/RELOCATE
161	1	STEAMER, 2-SEC.	
162	1	HOSE REEL	
163	2	RACK OVEN, 2-SEC.	
164	2	OVEN RACK, DOUBLE	
165-167	1	OPEN NUMBER	
168	3	HOSE REEL SECURITY CABINET	
169	1	FIRE PROTECTION SYSTEM	
170	1	FIRE PROTECTION SYSTEM	
171	1	OPEN NUMBER	
172	2	POT AND PAN CART	
173	1	POT & PAN SINK	
174	1	DISPOSER	
175	1	SPRAY RINSE	
176-180	1	OPEN NUMBER	
181	1	CART WASH STAINLESS STEEL WALL PANEL	
182	1	HOSE STATION	
183	1	FLOOR TROUGH	
184	2	HOSE REEL	
185	2	EYE/FACE WASH STATION	
186	1	SOILED DISHTABLE	
187	2	DISPOSER	
188	1	HOSE STATION SECURITY CABINET	
189	1	FLIGHT-TYPE DISHMACHINE W/DRYER	
190	1	EXHAUST DUCT RISER	
191	2	SPRAY RINSE	
192	1	FLOOR TROUGH	
193	12	DRYING RACK	EXISTING/OWNER TO RELOCATE
194	1	FLOOR TROUGH	
195	1	CONDENSATE HOOD	

LEGEND
DENOTES EXISTING EQUIPMENT

1 FOODSERVICE EQUIPMENT PLAN - AREA 3
1/4" = 1'-0"

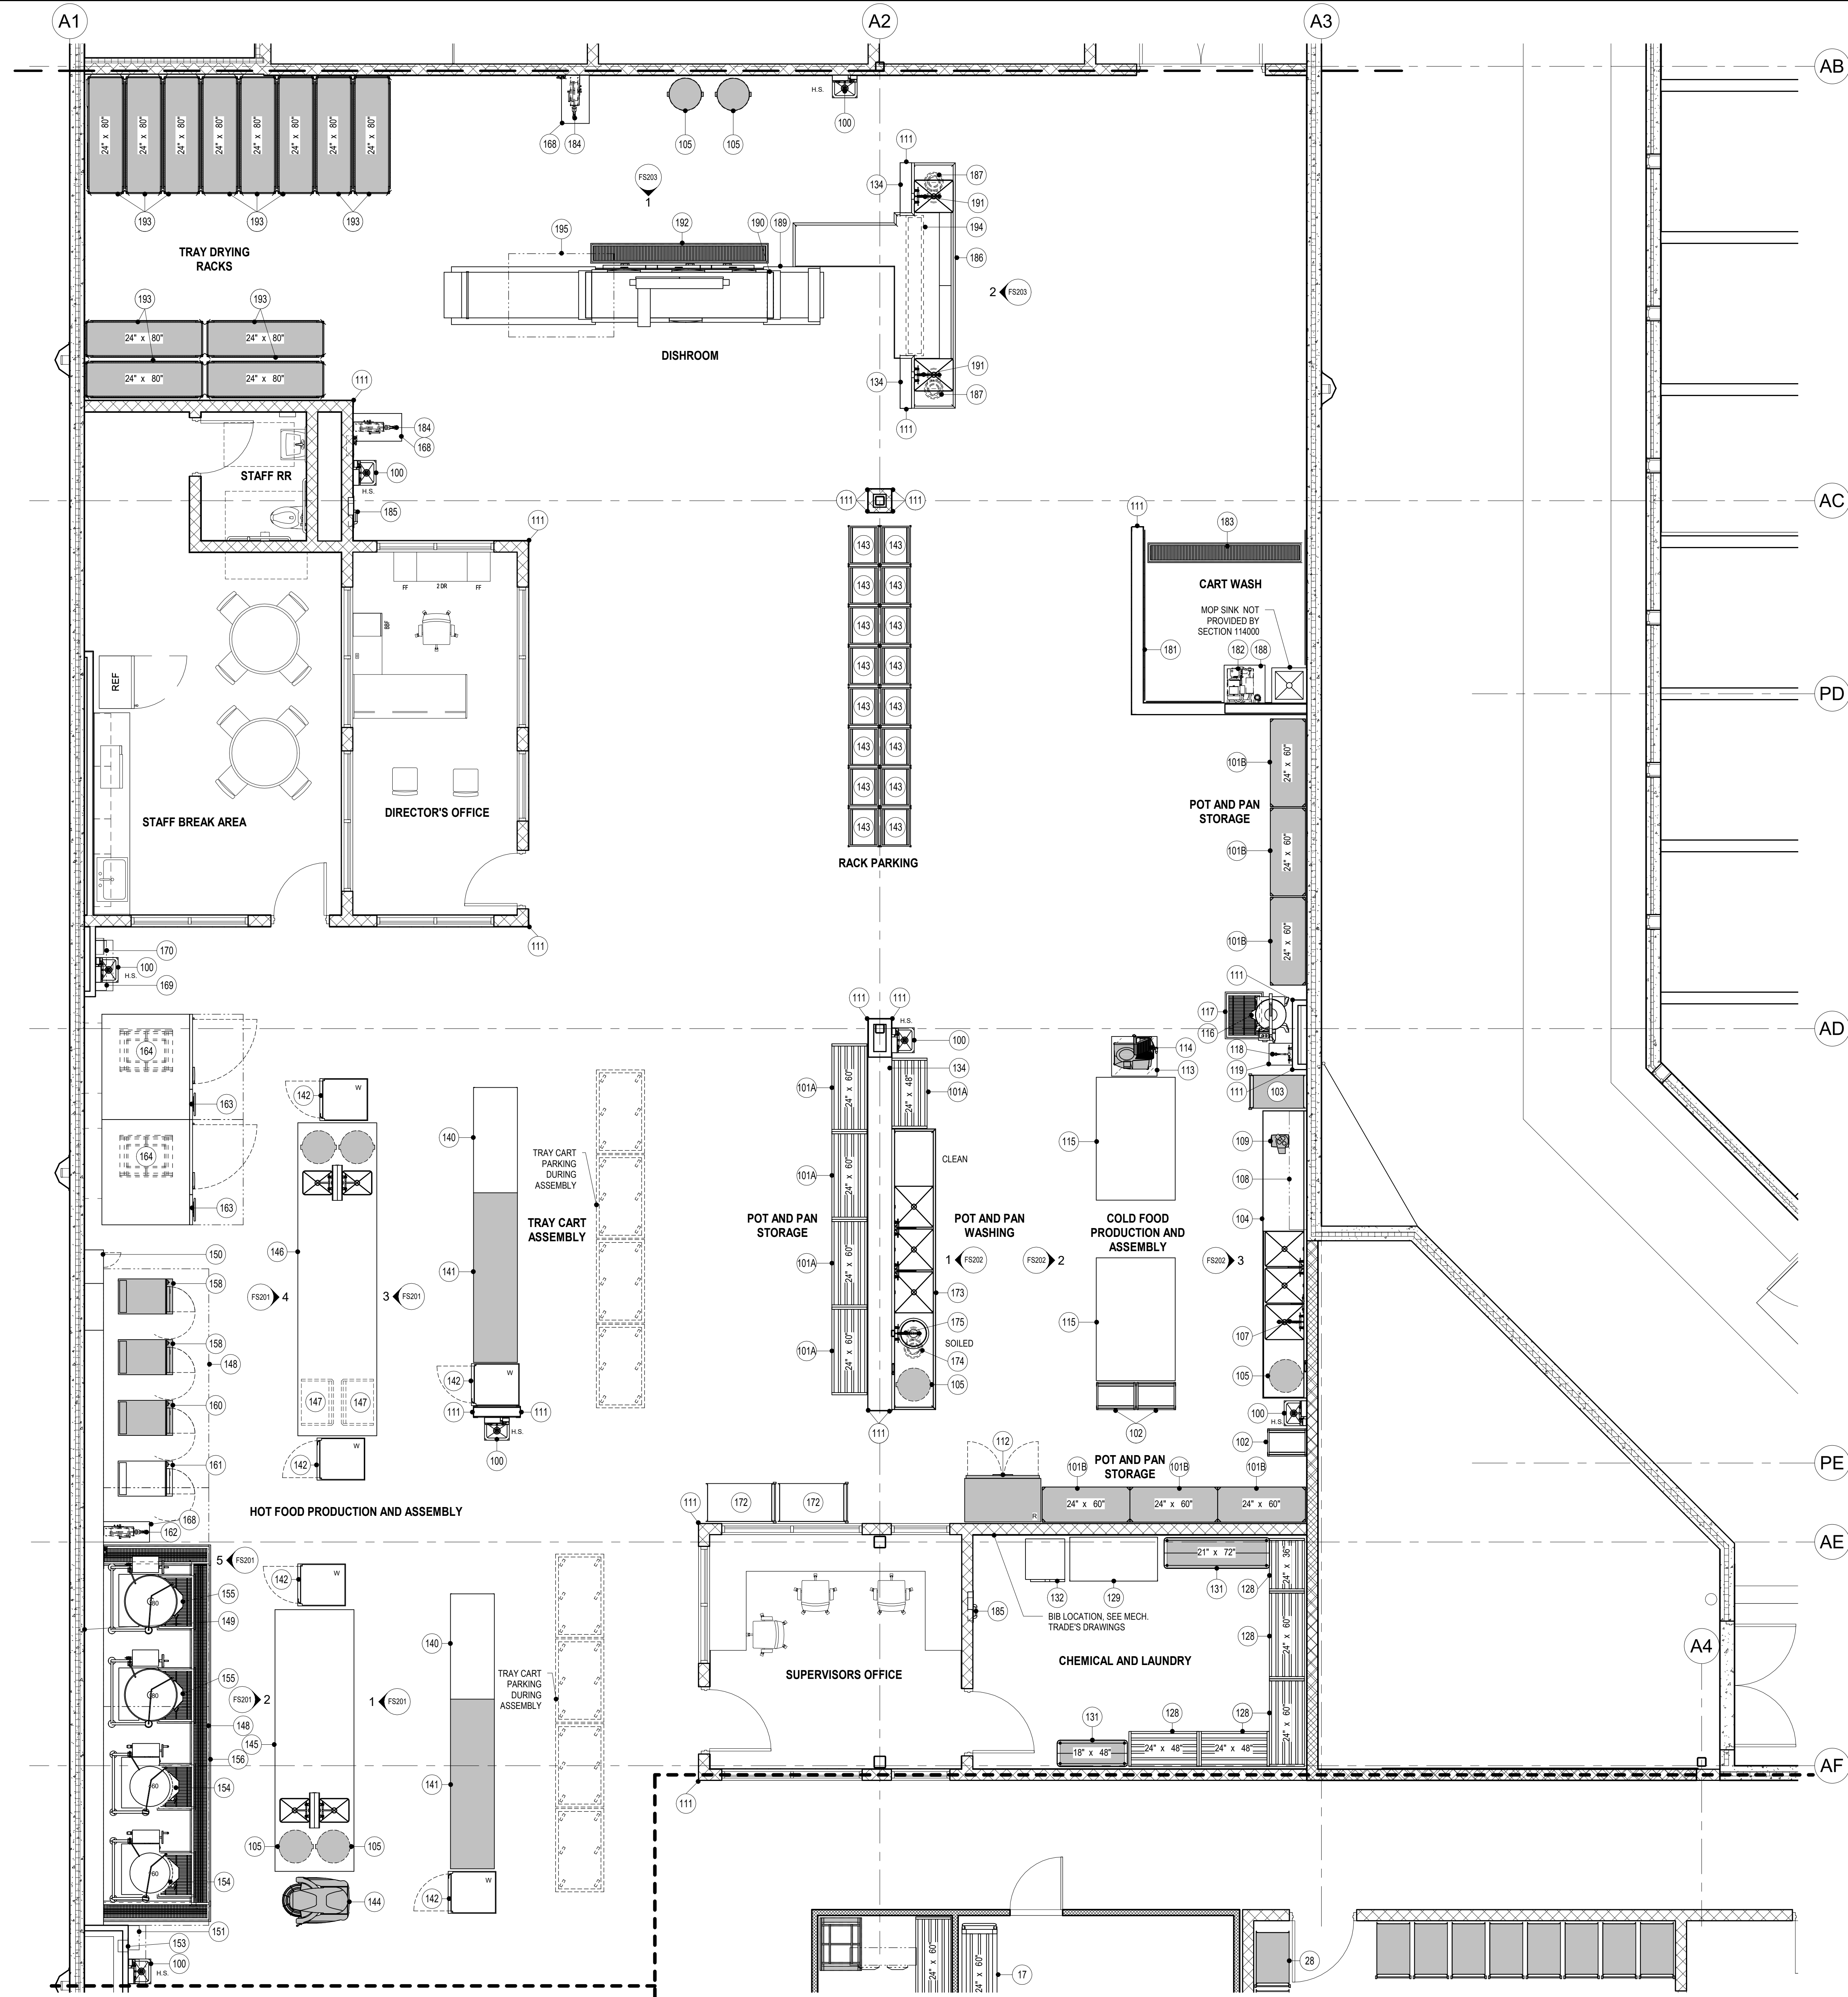

Farnsworth
GROUP

14225 UNIVERSITY AVENUE, SUITE 110
WALKEE, IOWA 50263
(515) 225-3469 / info@f-w.com

www.f-w.com
Engineers | Architects | Surveyors | Scientists

RIPPE ASSOCIATES
FOODSERVICE DESIGN + CONSULTING

kppf

IMEG

Bishop Engineering

ISSUE:
DATE: DESCRIPTION:

BID SET

PROJECT:
STATE OF IOWA DEPARTMENT
OF CORRECTIONS

CLARINDA
CORRECTIONAL
FACILITY - KITCHEN &
LAUNDRY ADDITION

2000 N 16TH ST, CLARINDA, IA
51632

DATE: 02/09/2024

DESIGNED: EG/TP

DRAWN: MM/BB

REVIEWED: EG/RB


SHEET TITLE:

FOODSERVICE
EQUIPMENT PLAN
AND SCHEDULE -
AREA 3

SHEET NUMBER:


FS103

PROJECT NO.: 0240202.00
RFB922300-02

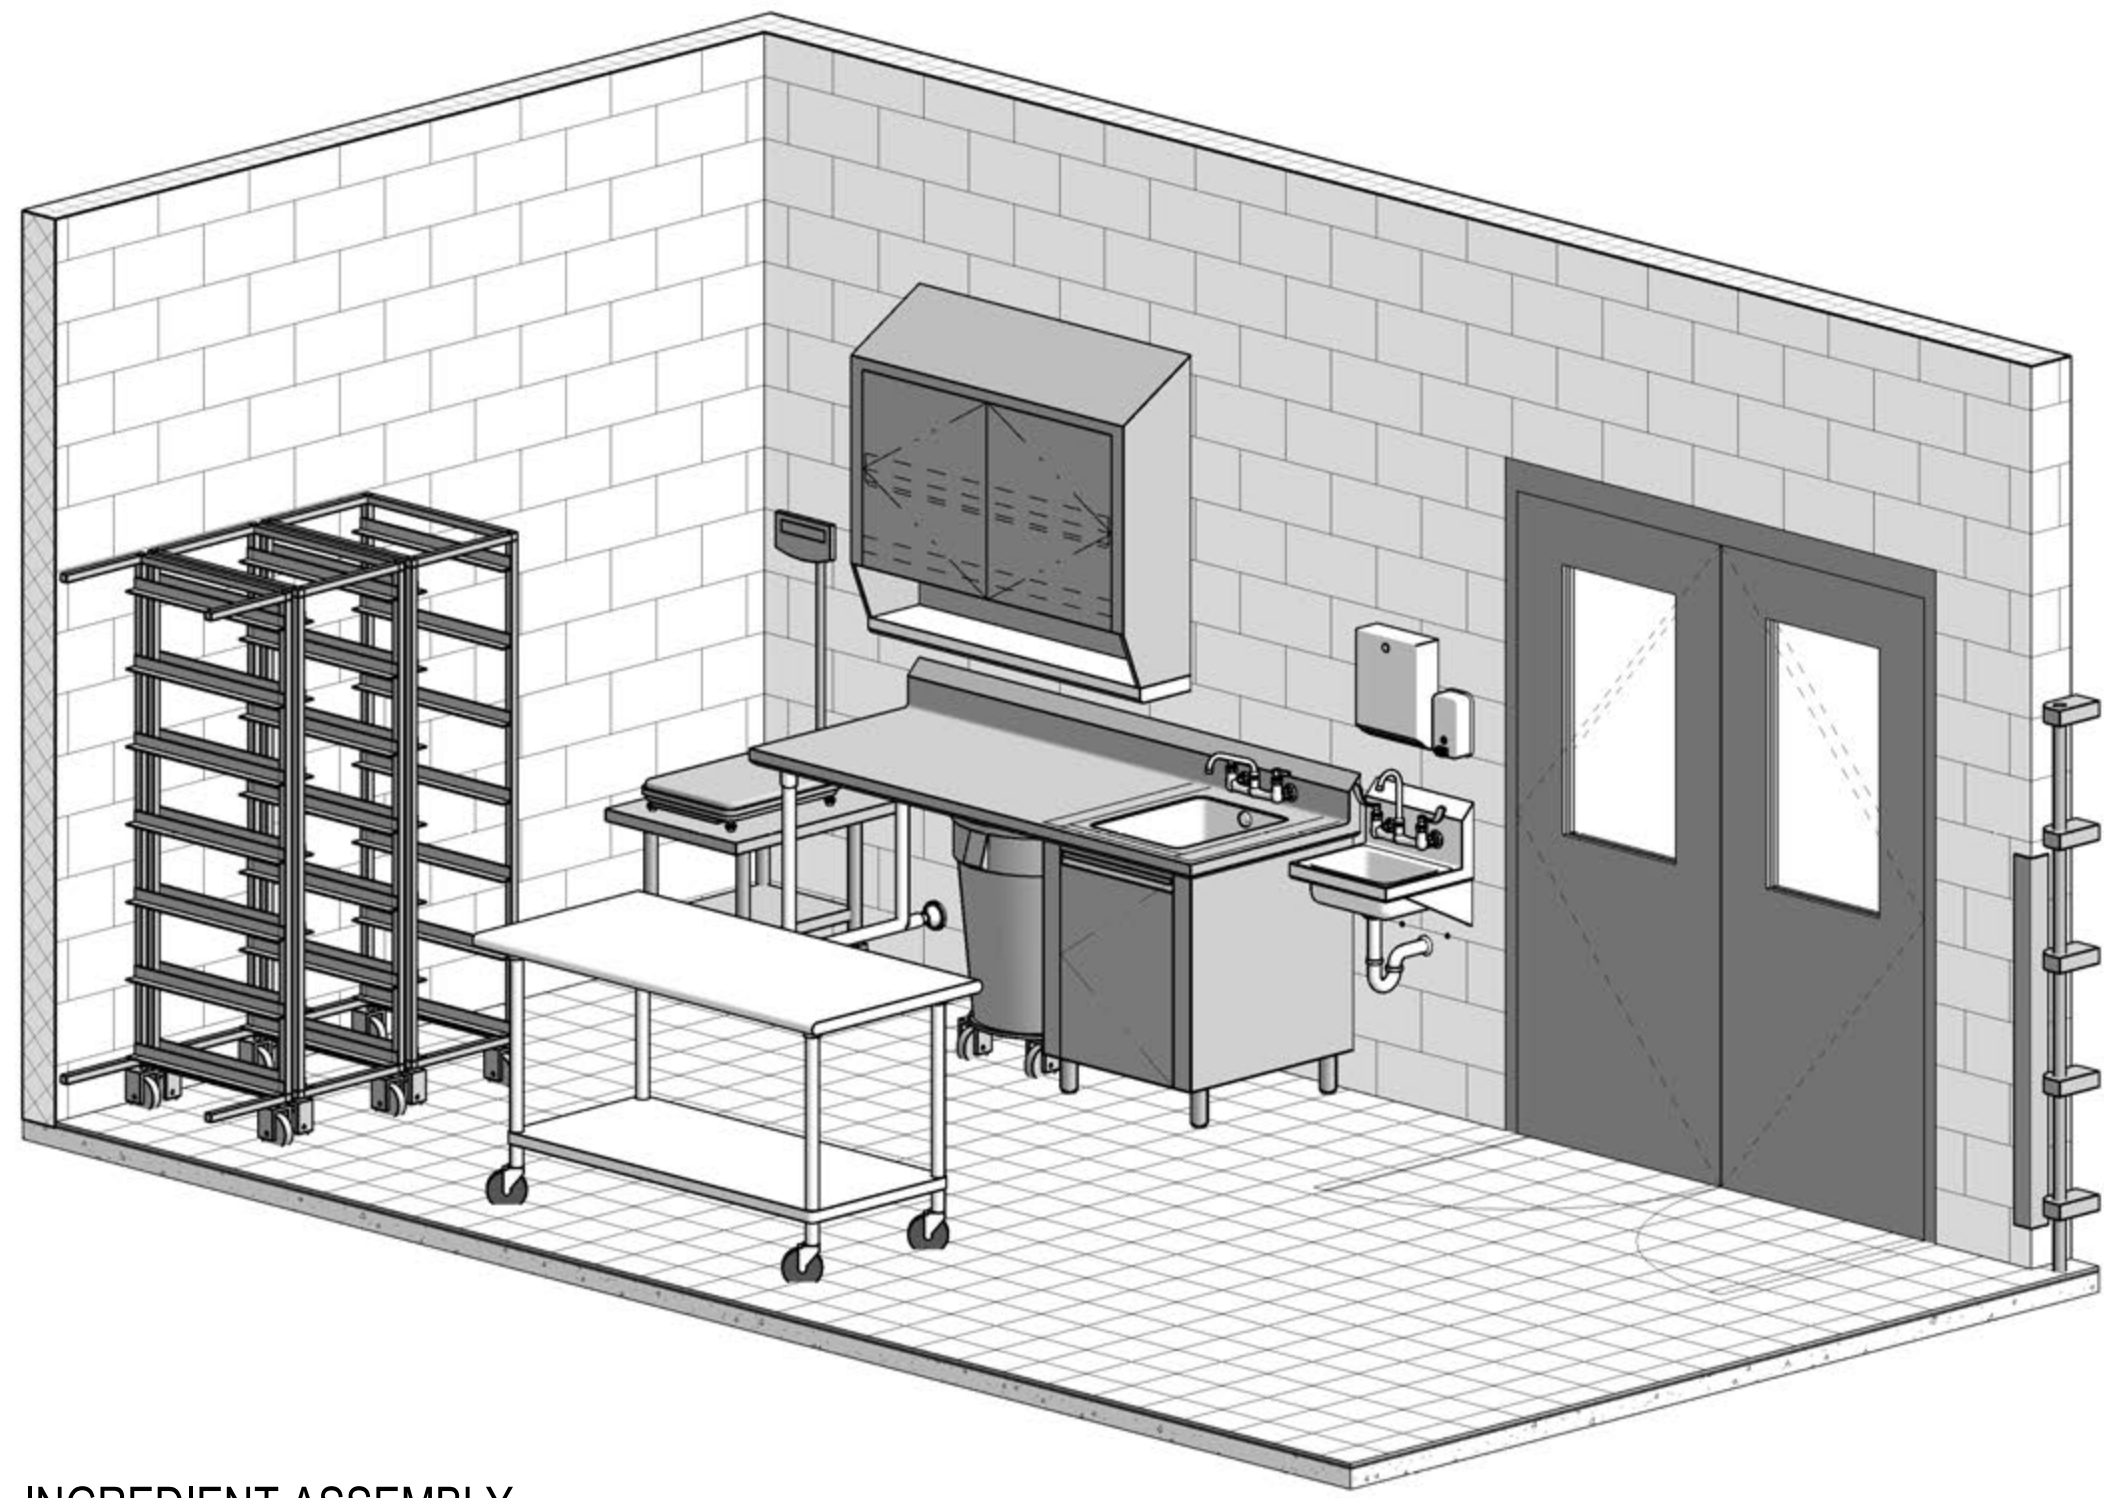


INGREDIENT ASSEMBLY


RRA KEYNOTE LEGEND	
KEYNOTE	KEYNOTE TEXT
SD-1a	TABLE EDGE - TURN DOWN
SD-2a	BACKSPLASH - AT WALL
SD-3	FRAMEWORK
SD-4	TABLE & SINK LEGS
SD-6	REMOVABLE UNDERSHELF
SD-7	CABINET CONSTRUCTION
SD-9a	GENERAL USE 16"x20"x10" DP.
SD-17	HINGED SOLID DOOR - INTEGRAL PULL
SD-28	WALL CABINET W/SHELF
SD-30	UTILITY CURB
SD-39	STAINLESS STEEL CORNER GUARD
SD-70	SHEET PAN DOLLY

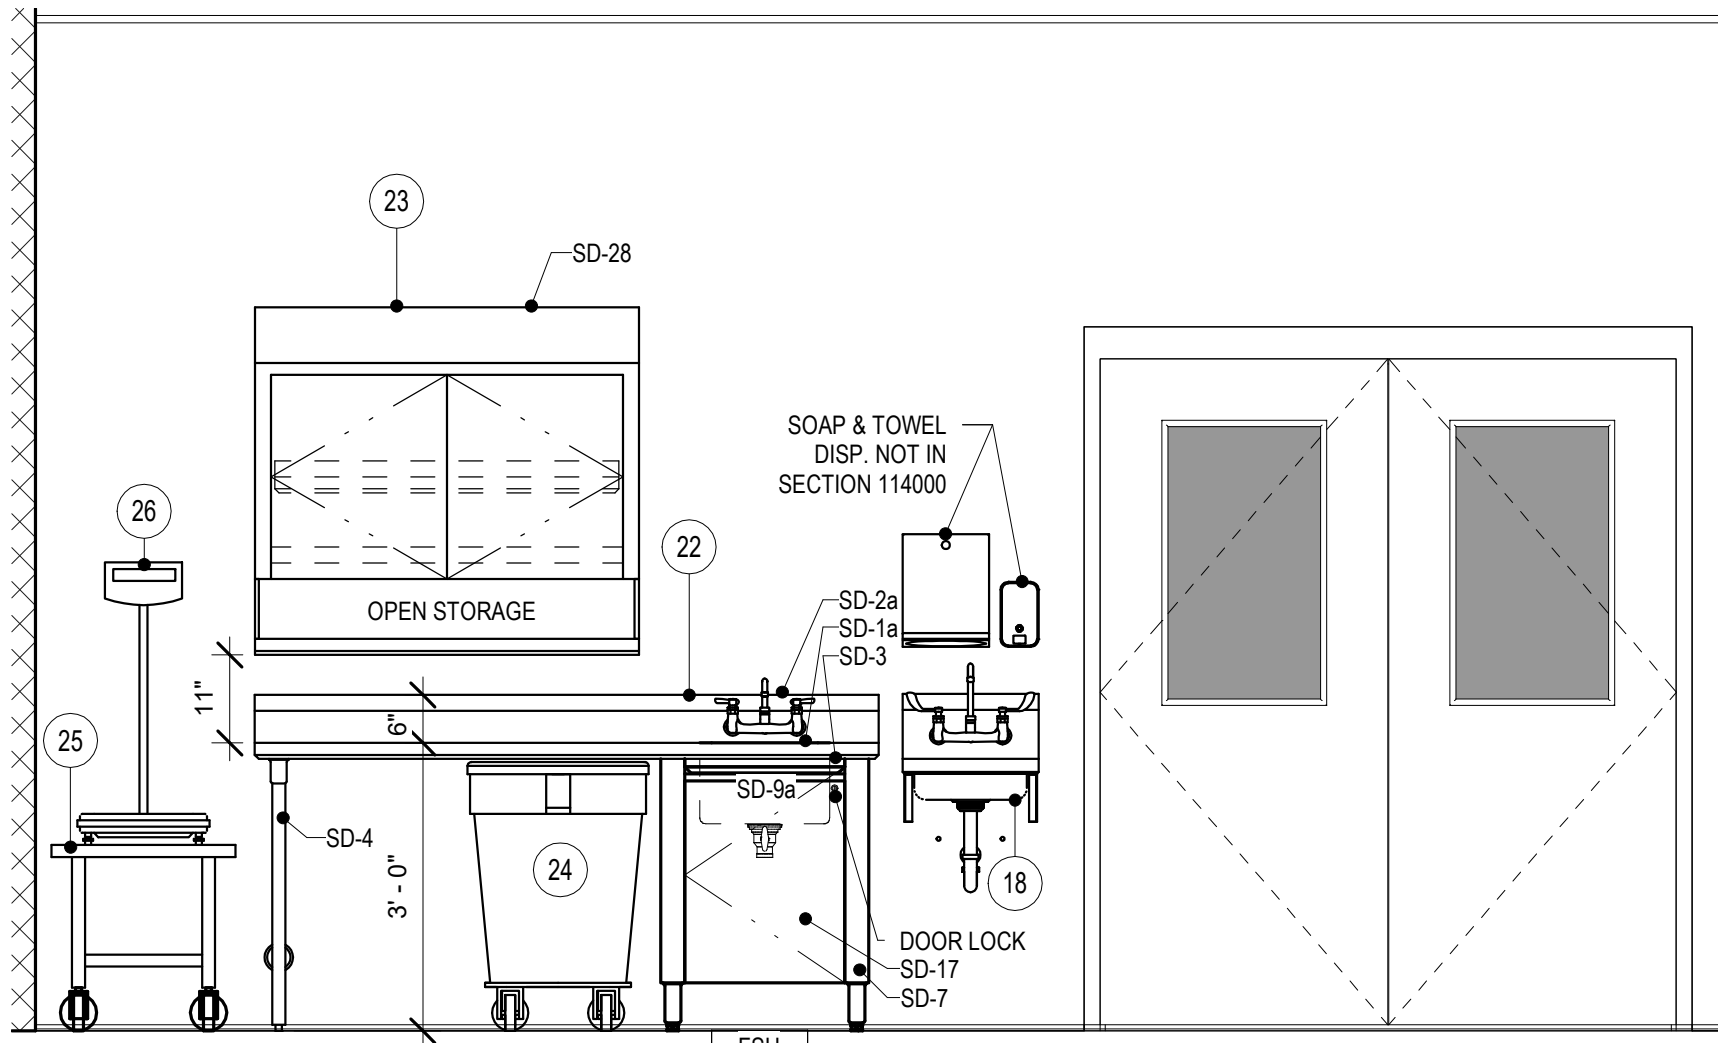


1 ITEM 22 - WORKCOUNTER W/ SINK
1/2" = 1'-0"

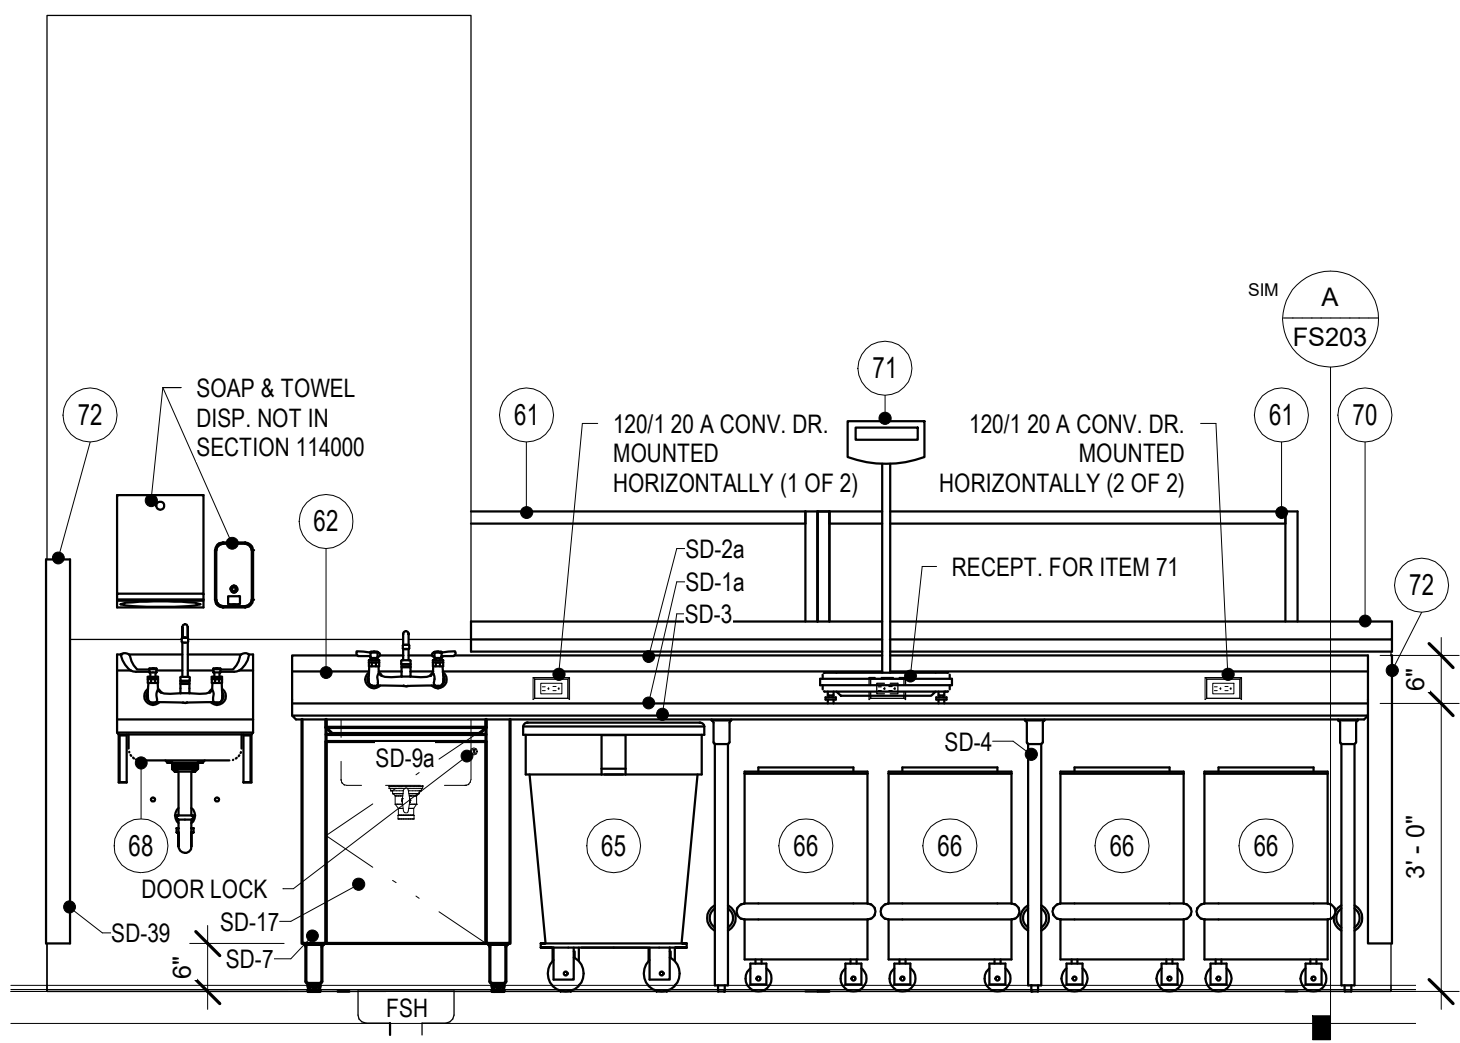


2 ITEM 62 - WORKCOUNTER W/ SINK
1/2" = 1'-0"

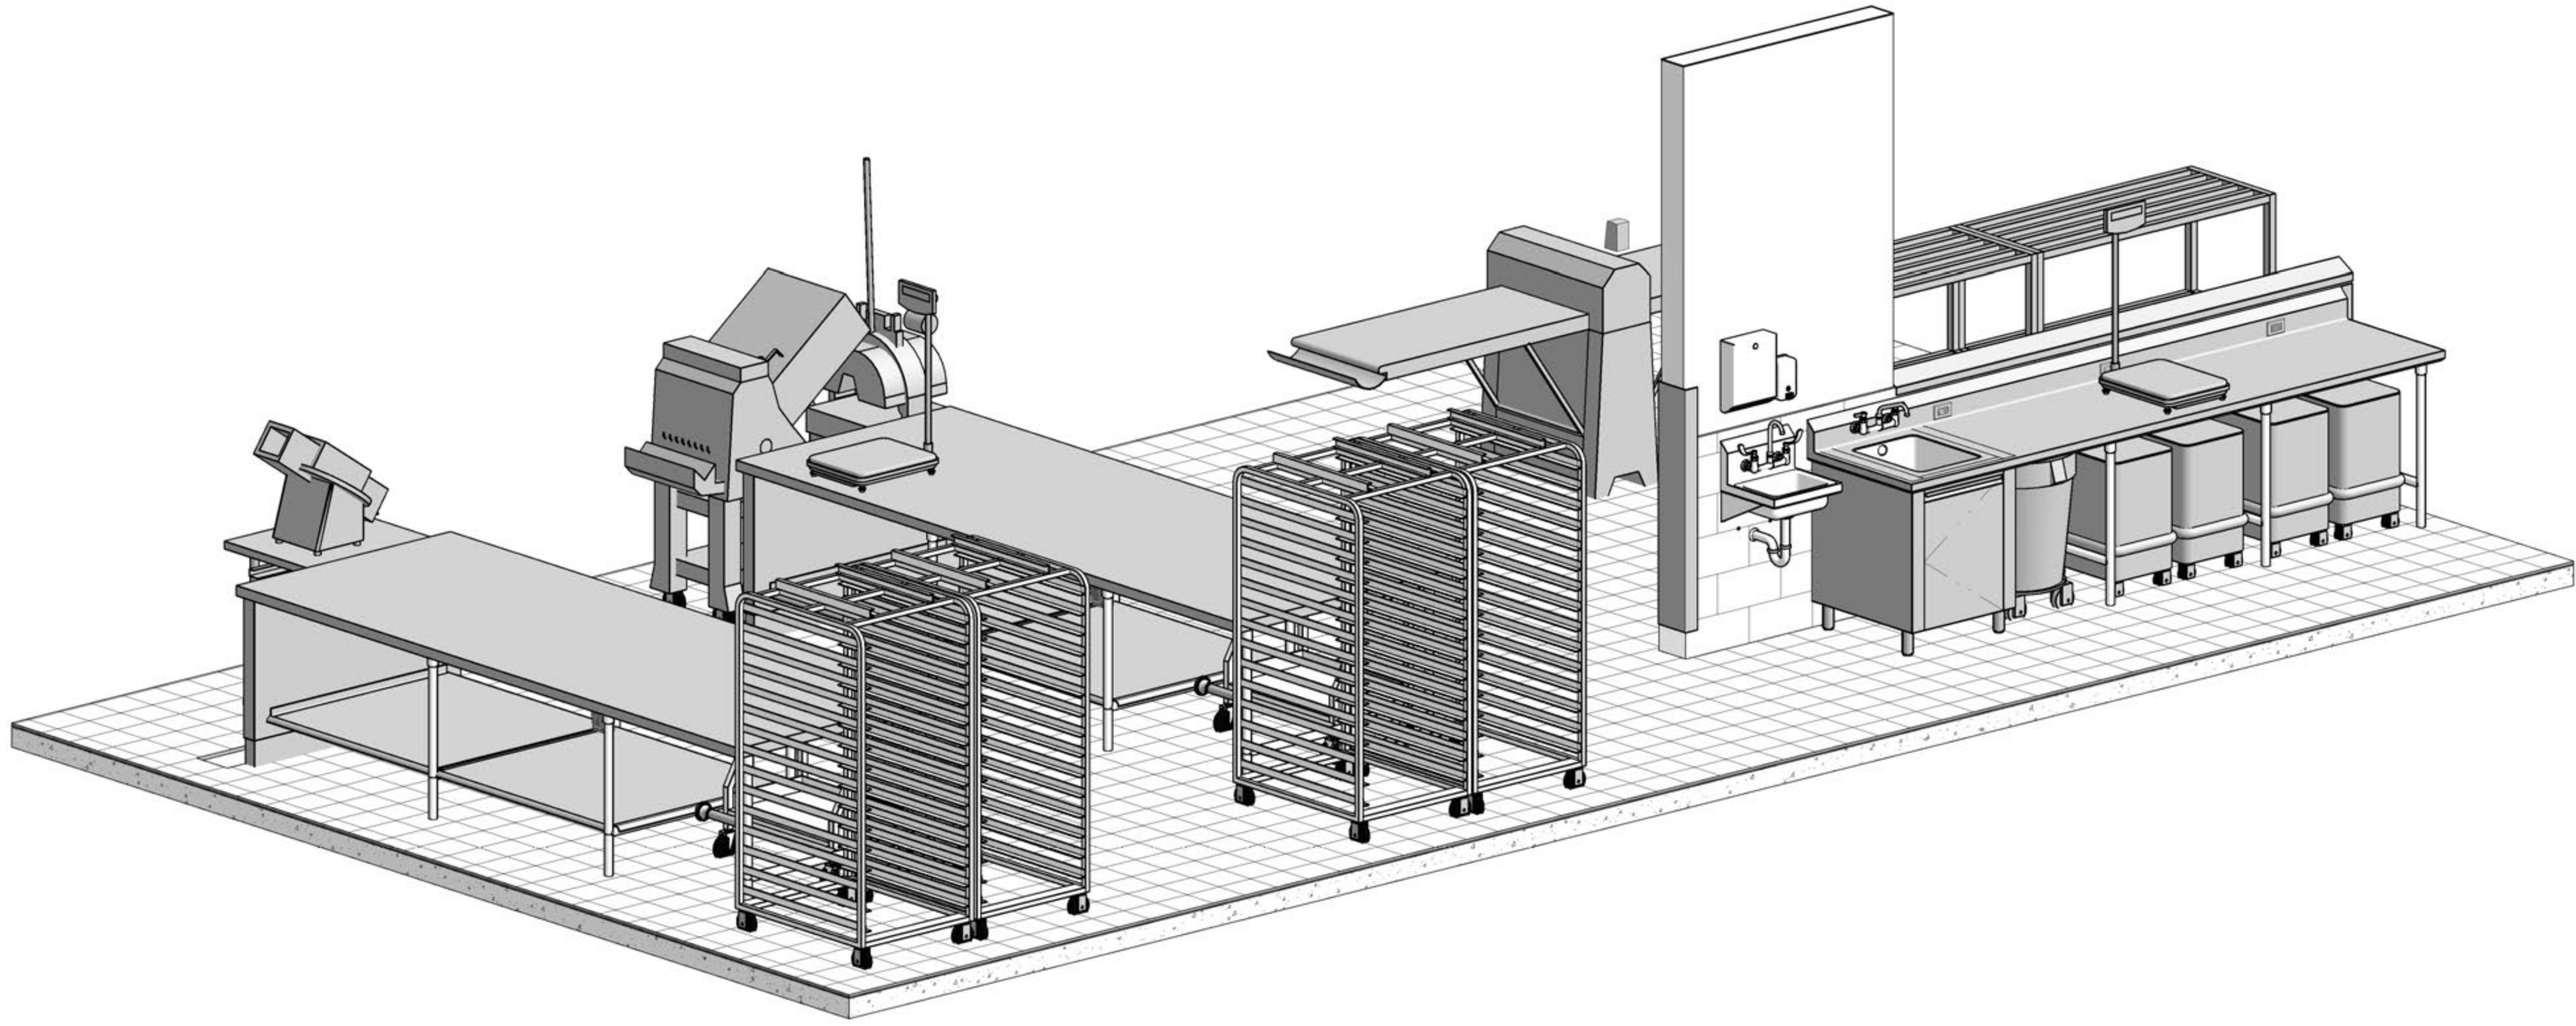


BAKERY PREP

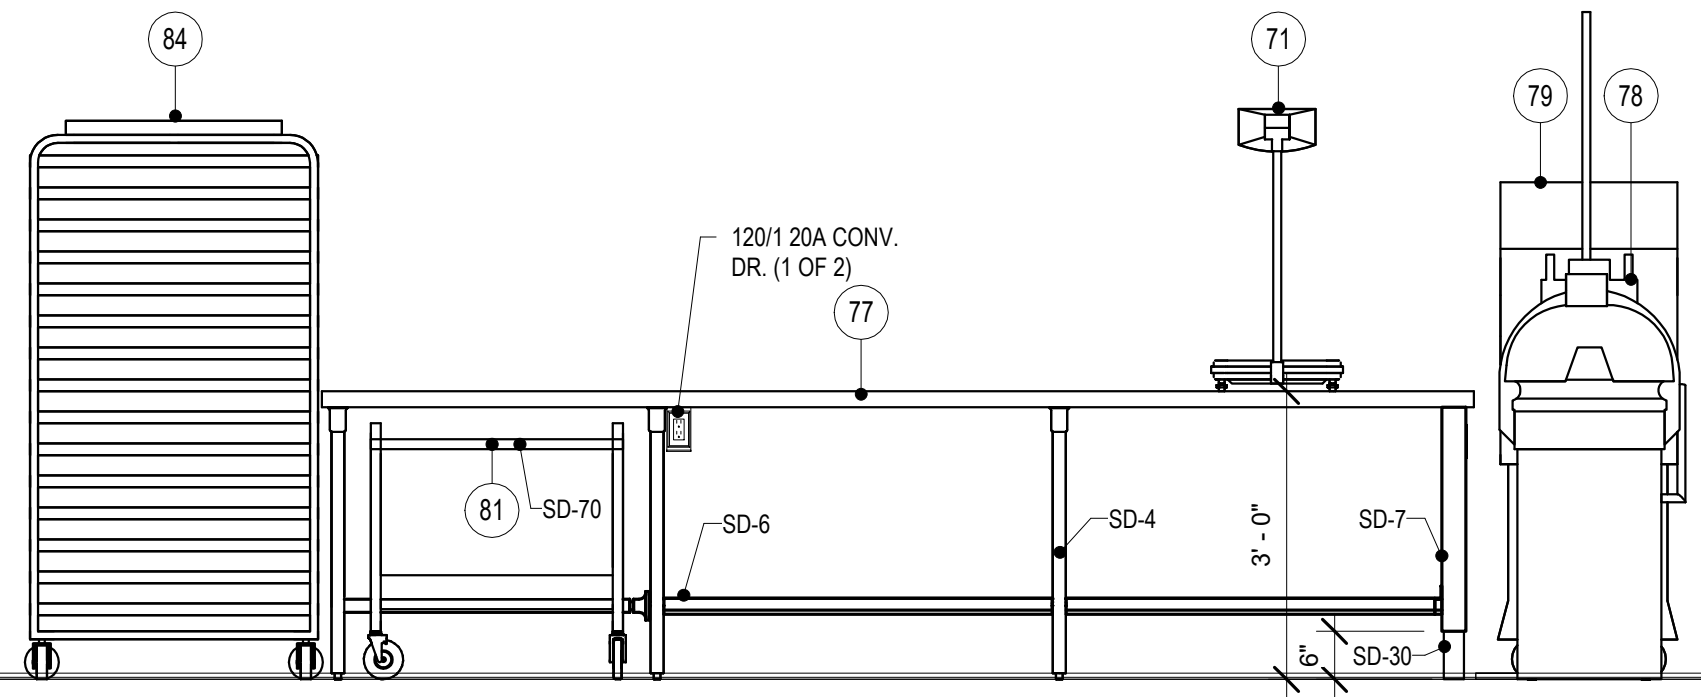


3 ITEM 77 - WORKCOUNTER 1
1/2" = 1'-0"

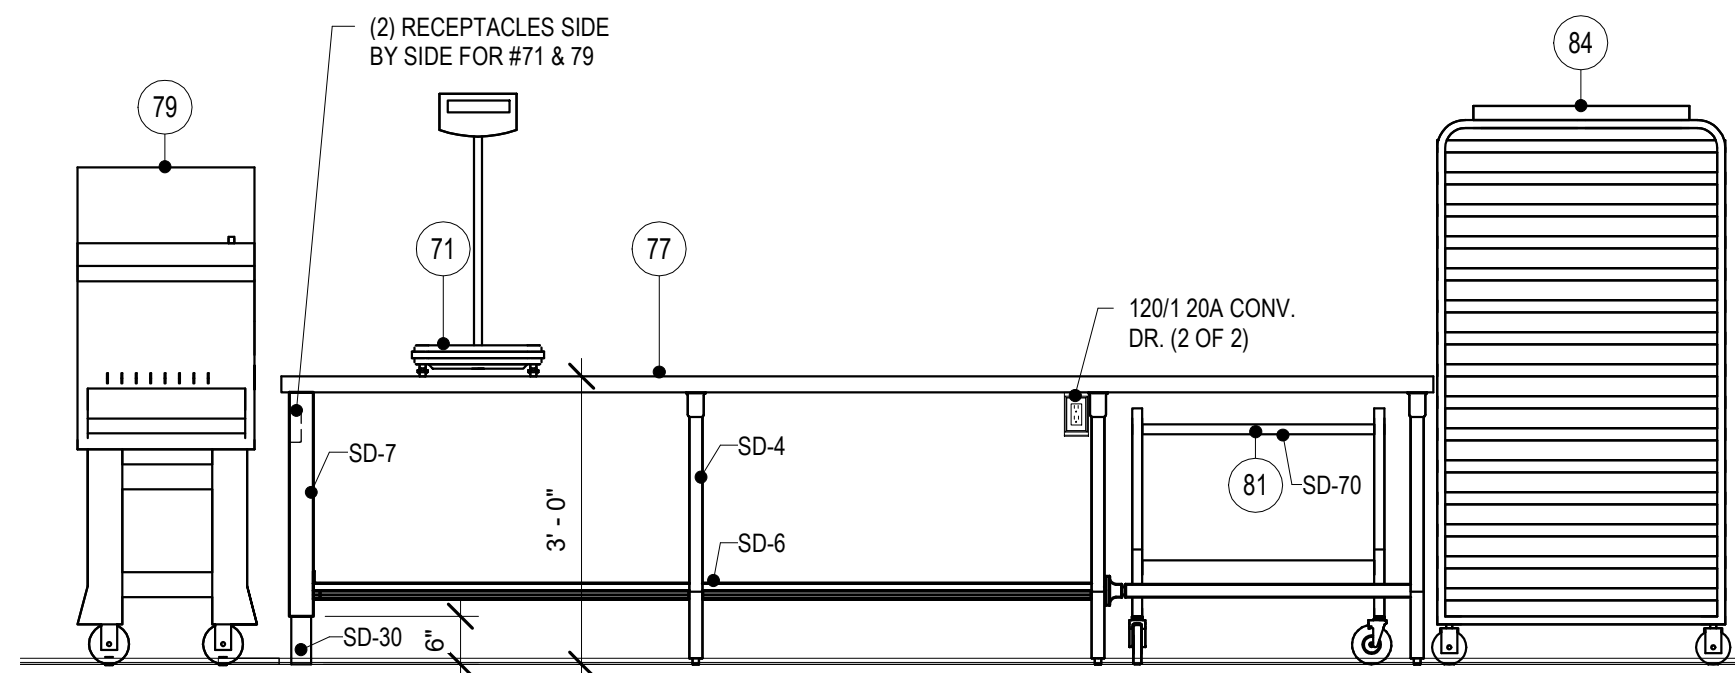


4 ITEM 77 - WORKCOUNTER 2
1/2" = 1'-0"

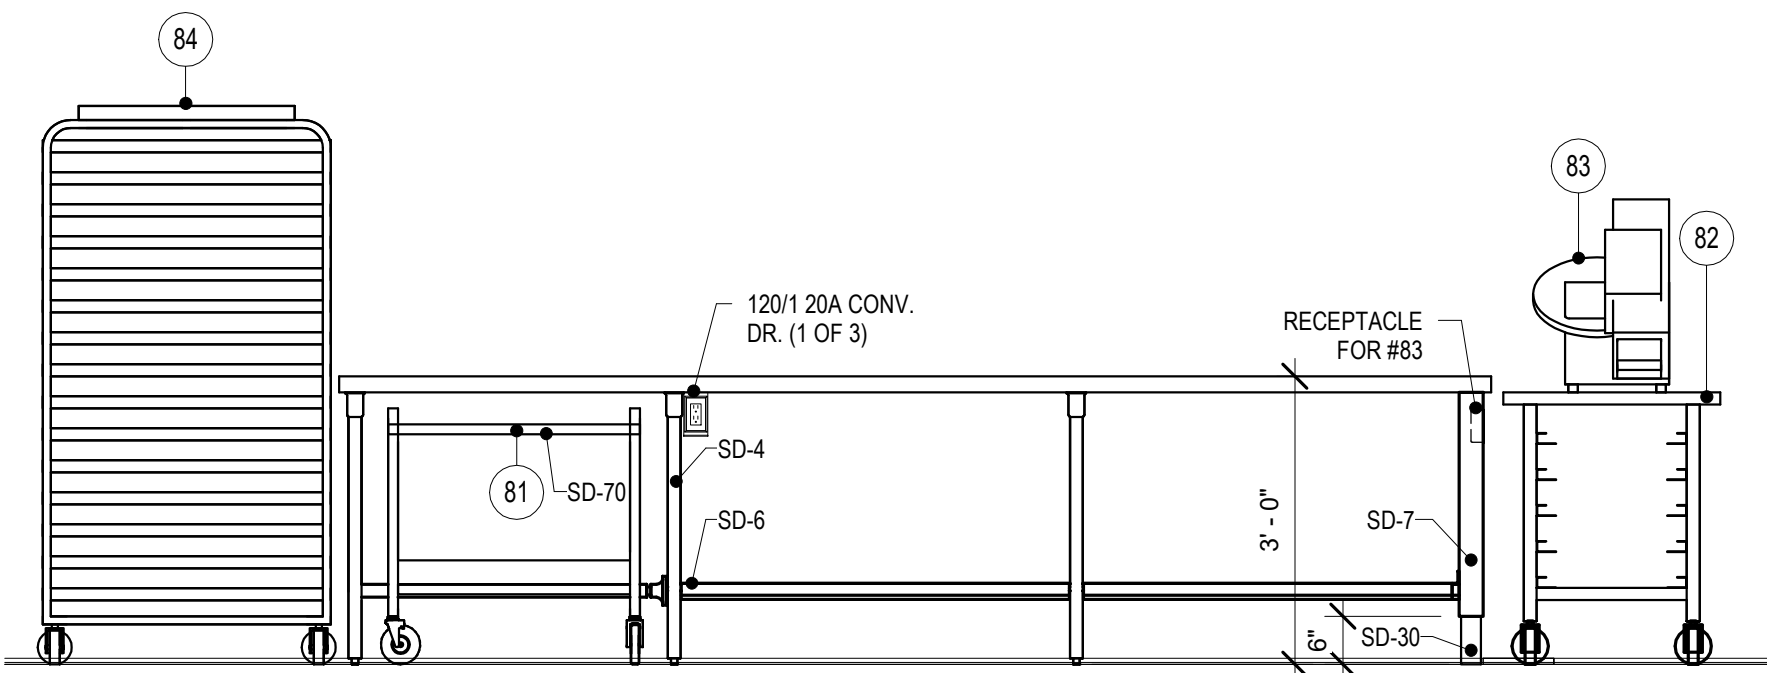

5 ITEM 77 - WORKCOUNTER 3
1/2" = 1'-0"

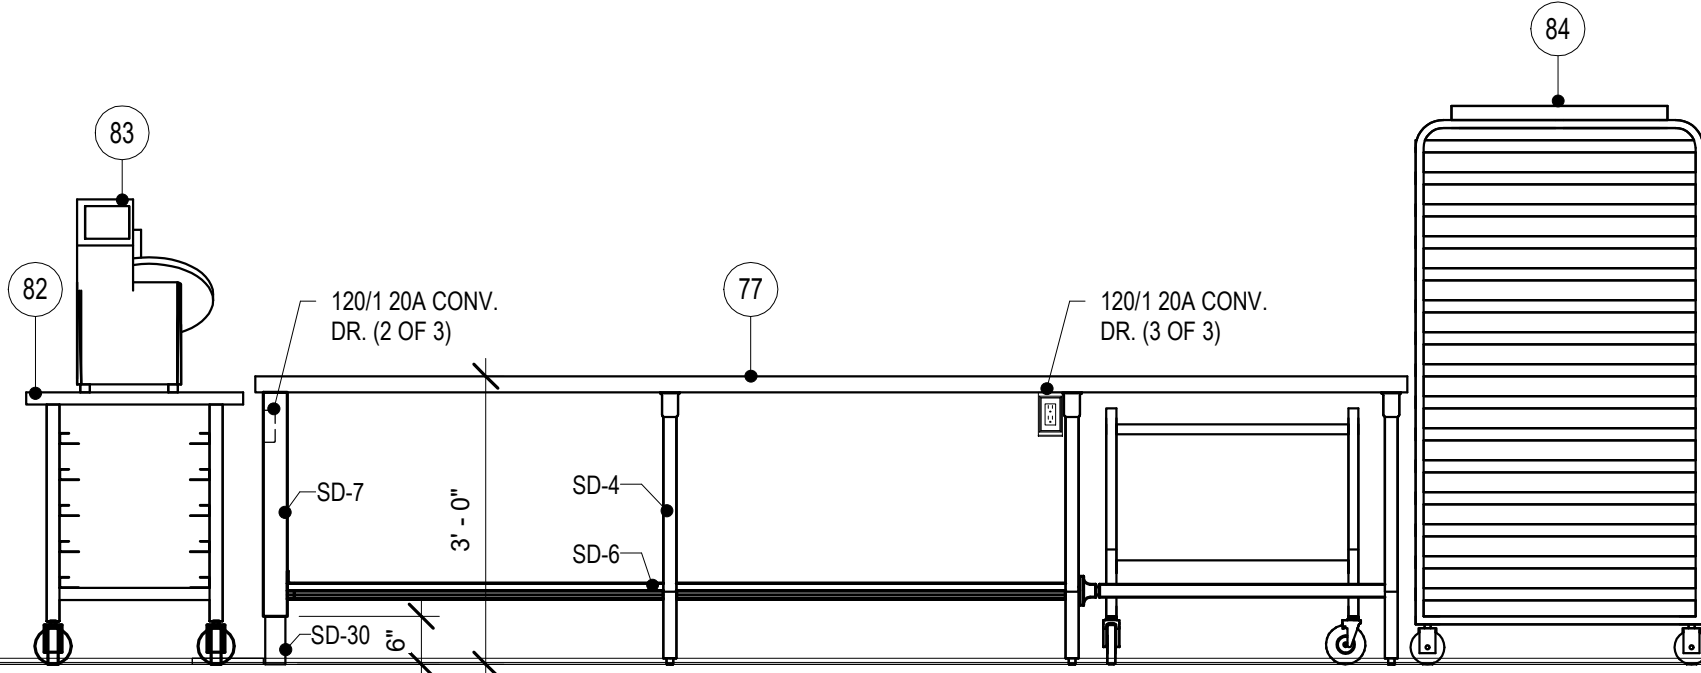

6 ITEM 77 - WORKCOUNTER 4
1/2" = 1'-0"

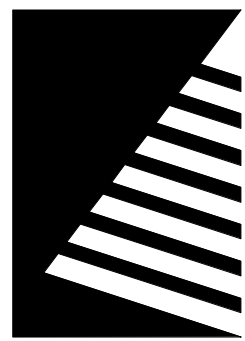

Farnsworth
GROUP

14225 UNIVERSITY AVENUE, SUITE 110
WALKEE, IOWA 50263
(515) 225-3469 / info@f-w.com

www.f-w.com
Engineers | Architects | Surveyors | Scientists

RIPPE ASSOCIATES
FOODSERVICE DESIGN + CONSULTING

kpff

IMEG

Bishop Engineering

ISSUE:
DATE: DESCRIPTION:

BID SET

PROJECT:
STATE OF IOWA DEPARTMENT
OF CORRECTIONS

CLARINDA
CORRECTIONAL
FACILITY - KITCHEN &
LAUNDRY ADDITION

2000 N 16TH ST, CLARINDA, IA
51632

DATE: 02/09/2024

DESIGNED: EG/TP

DRAWN: MM/BB


REVIEWED: EG/RB

SHEET TITLE:
FOODSERVICE
ELEVATIONS AND
SECTIONS

SHEET NUMBER:


FS200

PROJECT NO.: 0240202.00
RFB922300-02

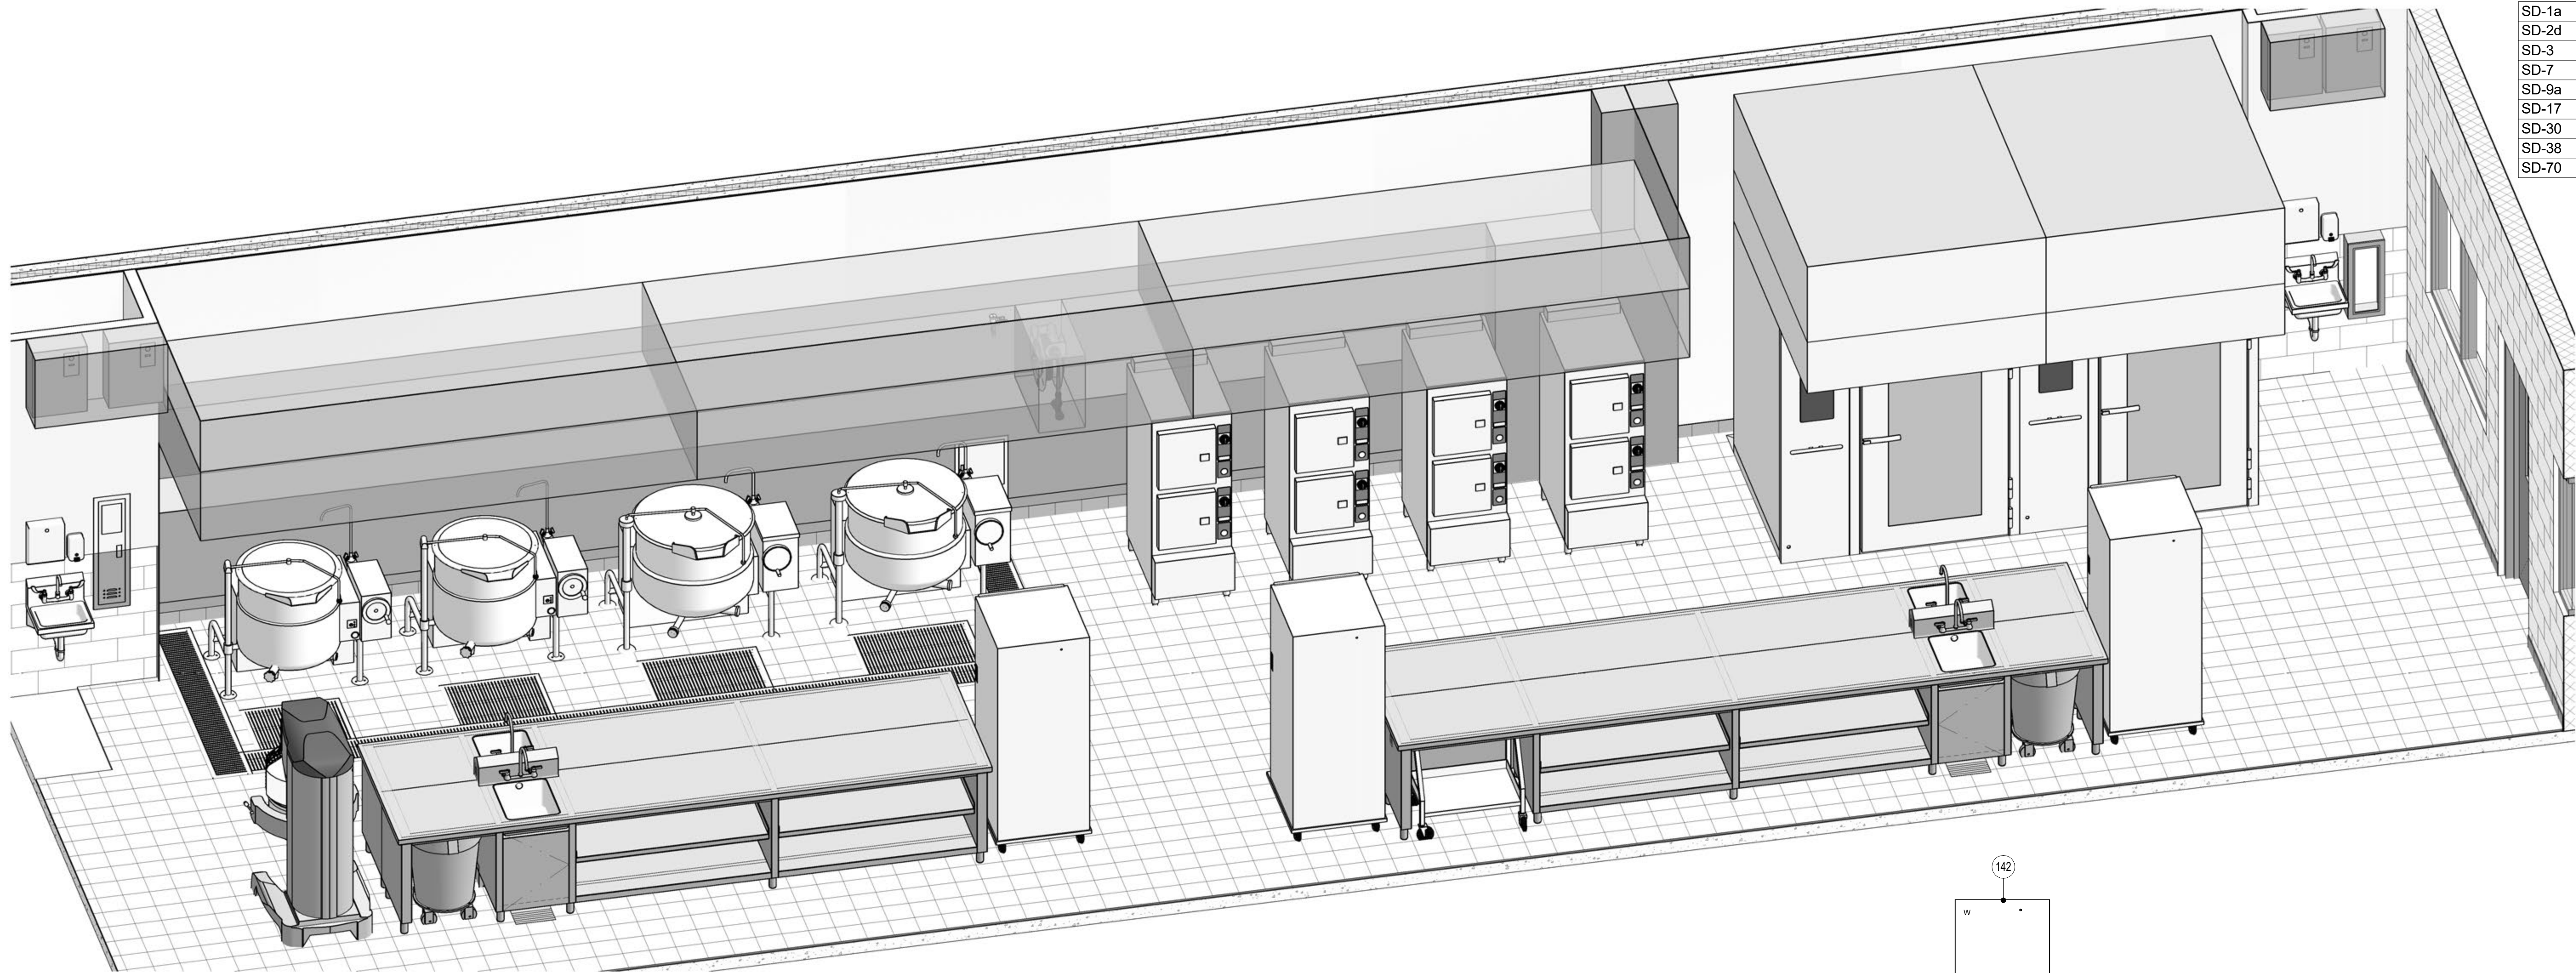


HOT FOOD PREP


RRA KEYNOTE LEGEND	
KEYNOTE	KEYNOTE TEXT
SD-1a	TABLE EDGE - TURN DOWN
SD-2d	BACKSPLASH - COMMON
SD-3	FRAMEWORK
SD-7	CABINET CONSTRUCTION
SD-9a	GENERAL USE 16"x20"x10" DP.
SD-17	HINGED SOLID DOOR - INTEGRAL PULL
SD-30	UTILITY CURB
SD-38	STAINLESS STEEL WALL PANEL
SD-70	SHEET PAN DOLLY

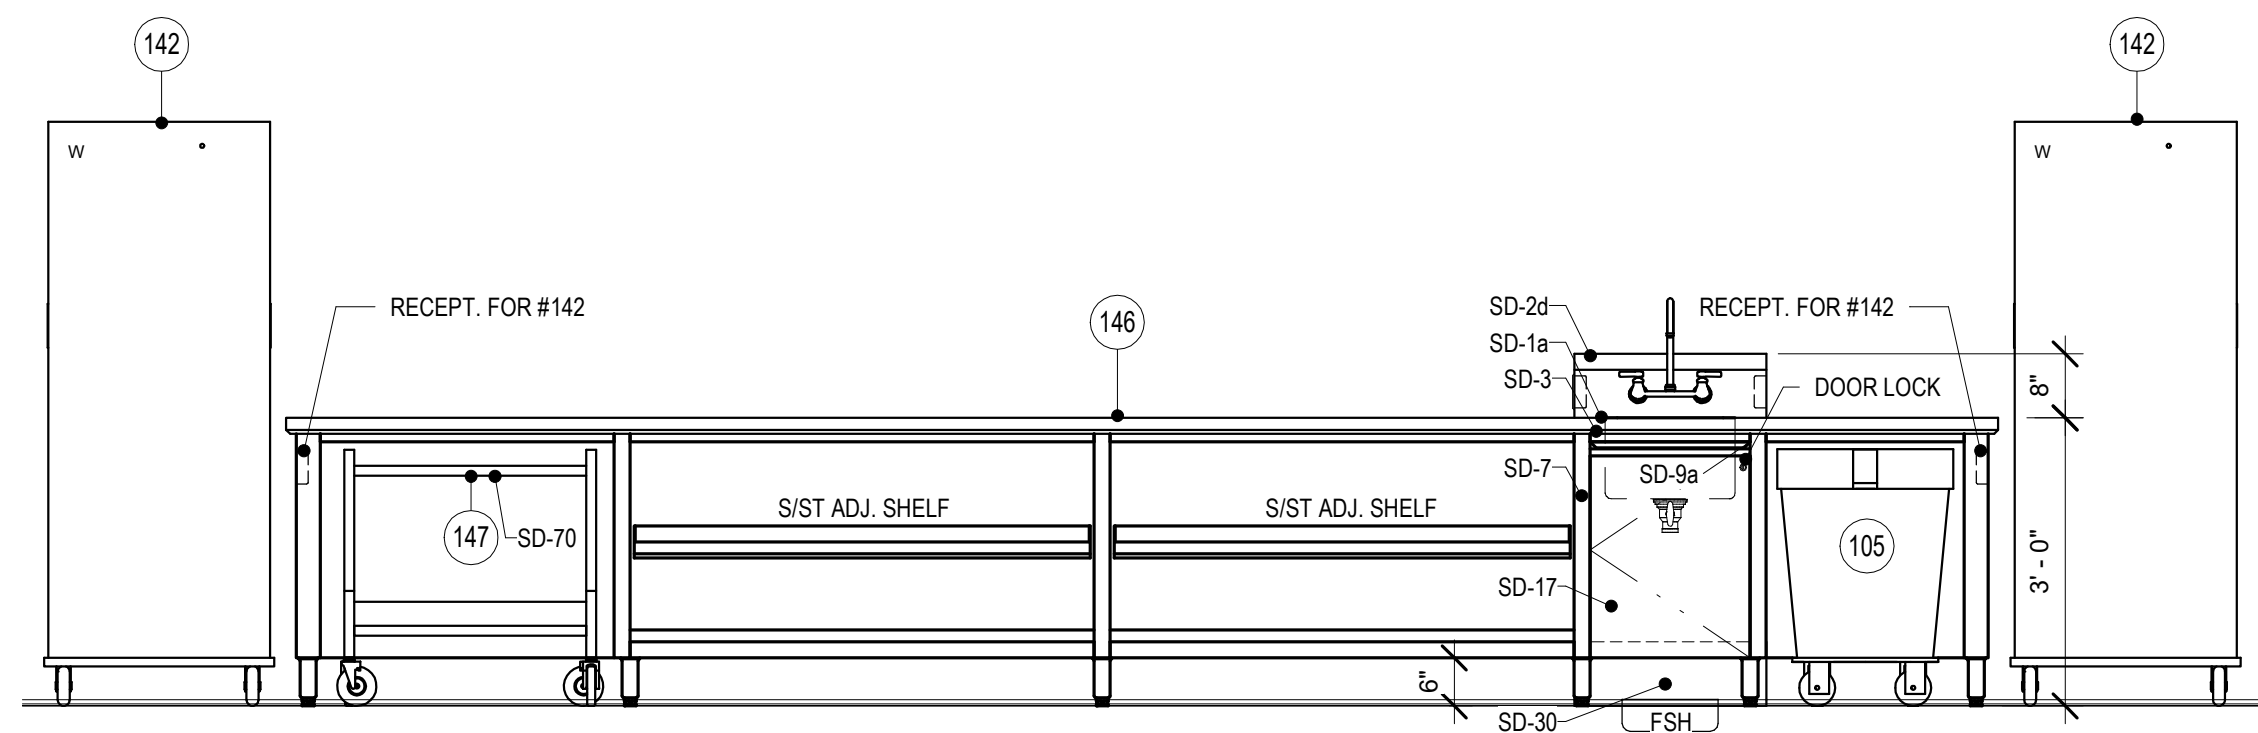


3 ITEM 146 - WORKCOUNTER W/ SINKS 1
1/2" = 1'-0"

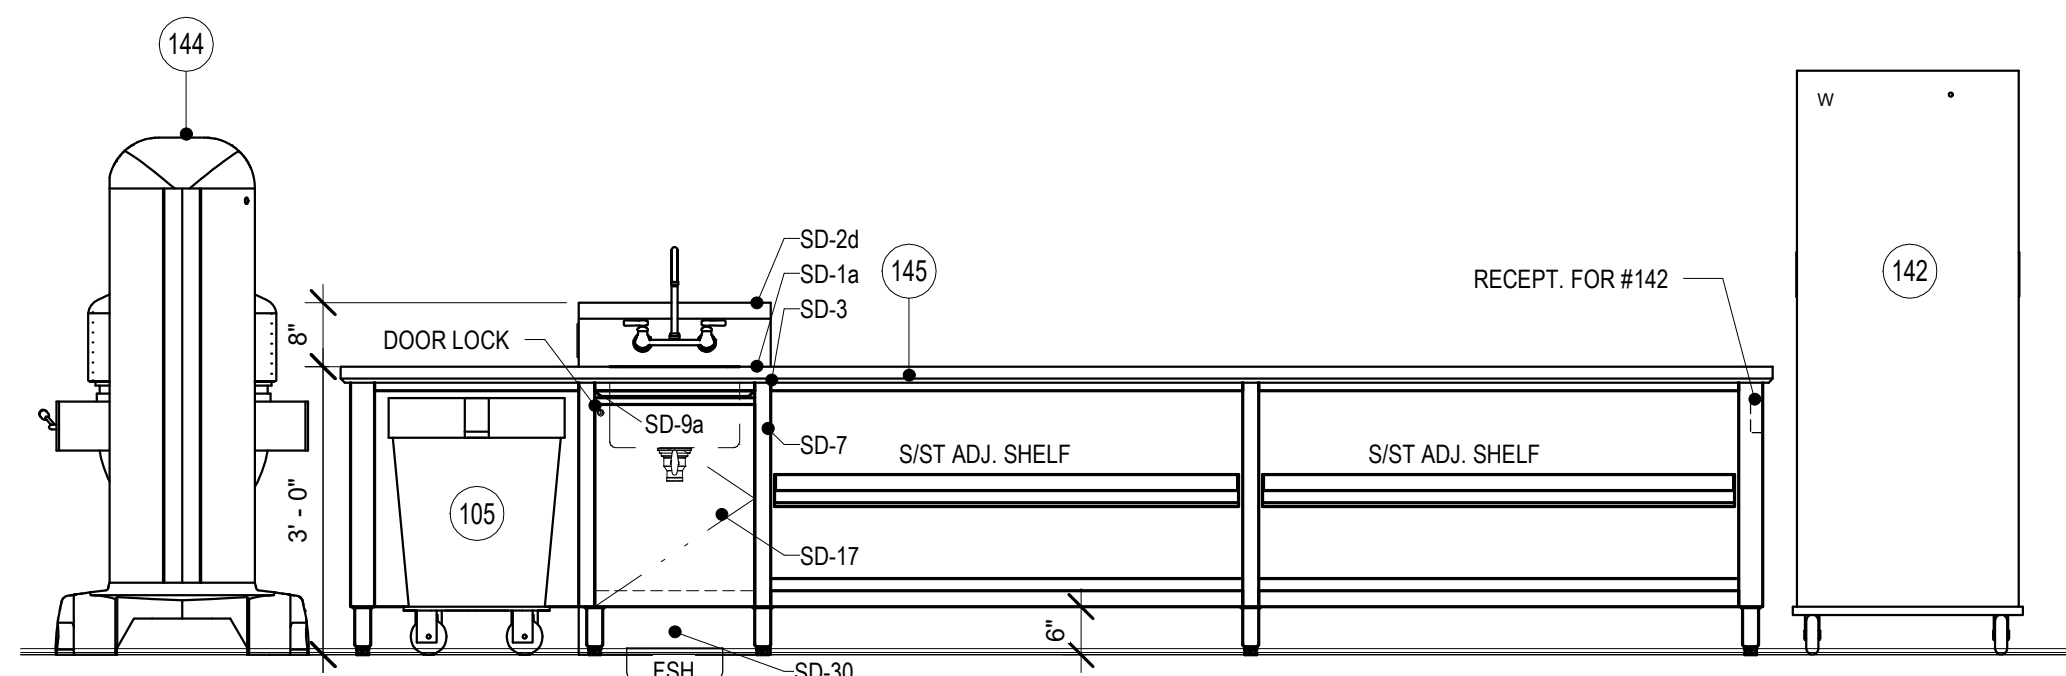


1 ITEM 145 - WORKCOUNTER W/ SINKS 1
1/2" = 1'-0"

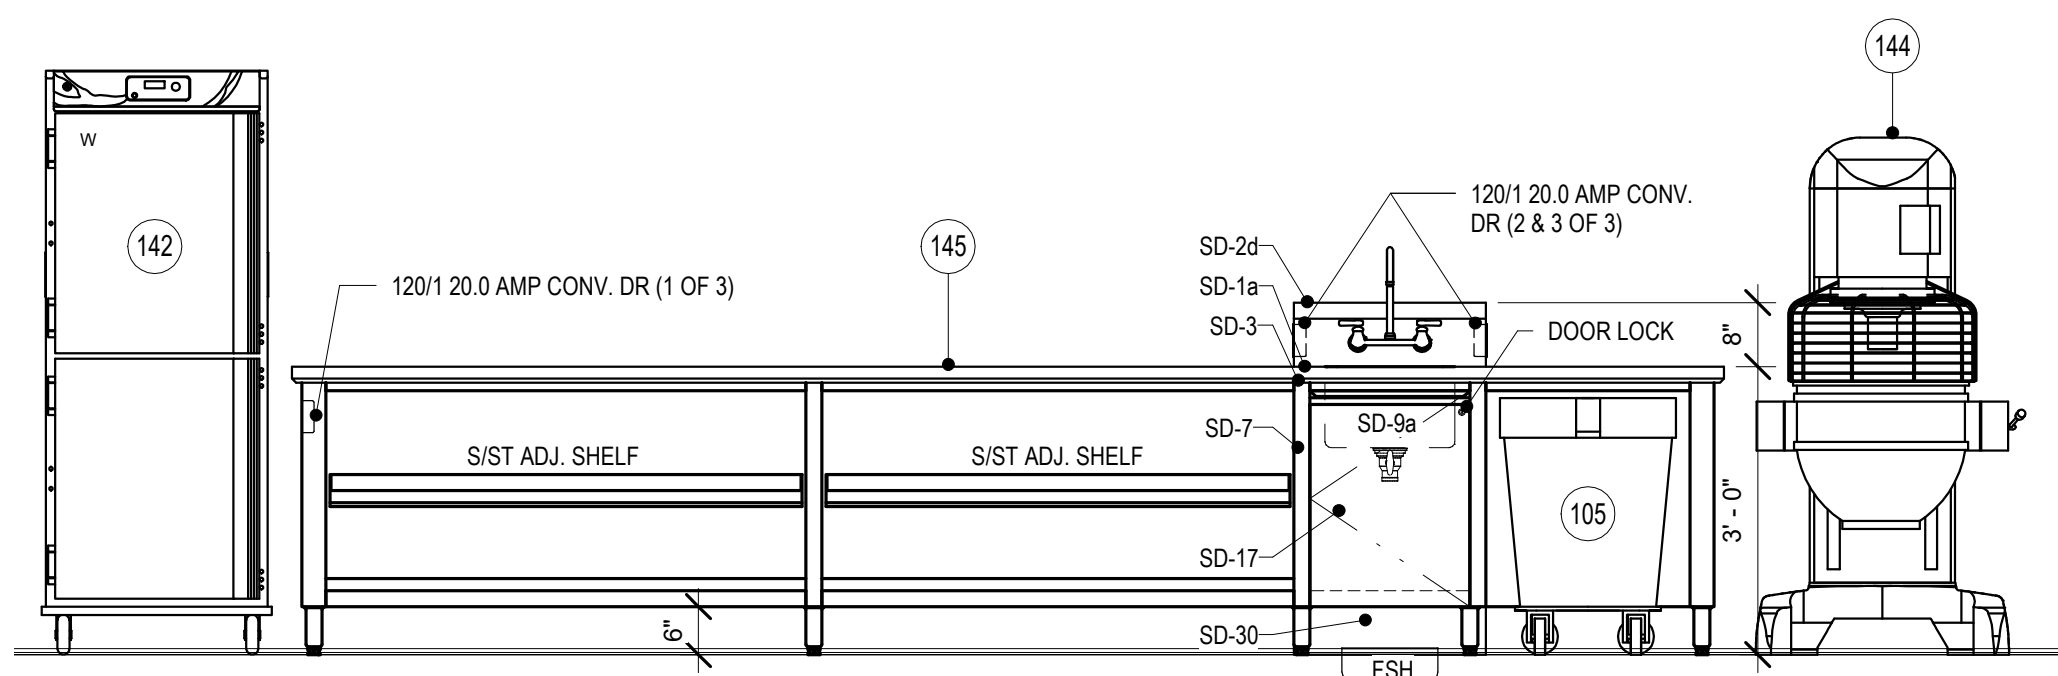

2 ITEM 145 - WORKCOUNTER W/ SINKS 2
1/2" = 1'-0"

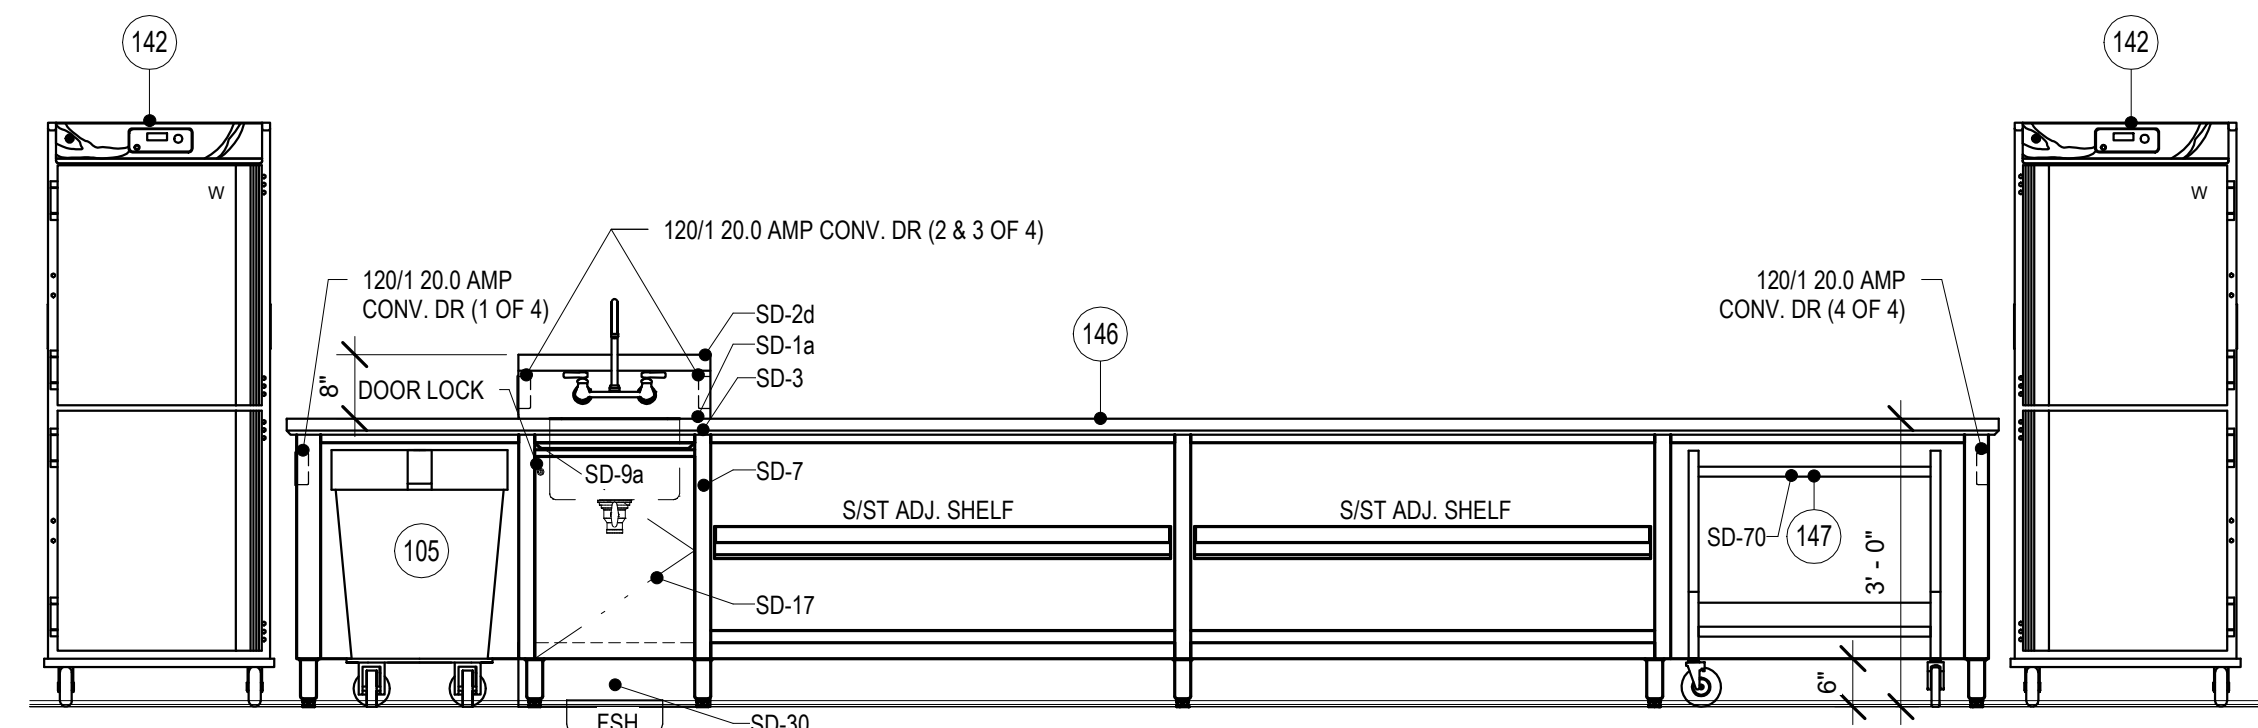

4 ITEM 146 - WORKCOUNTER W/ SINKS 2
1/2" = 1'-0"

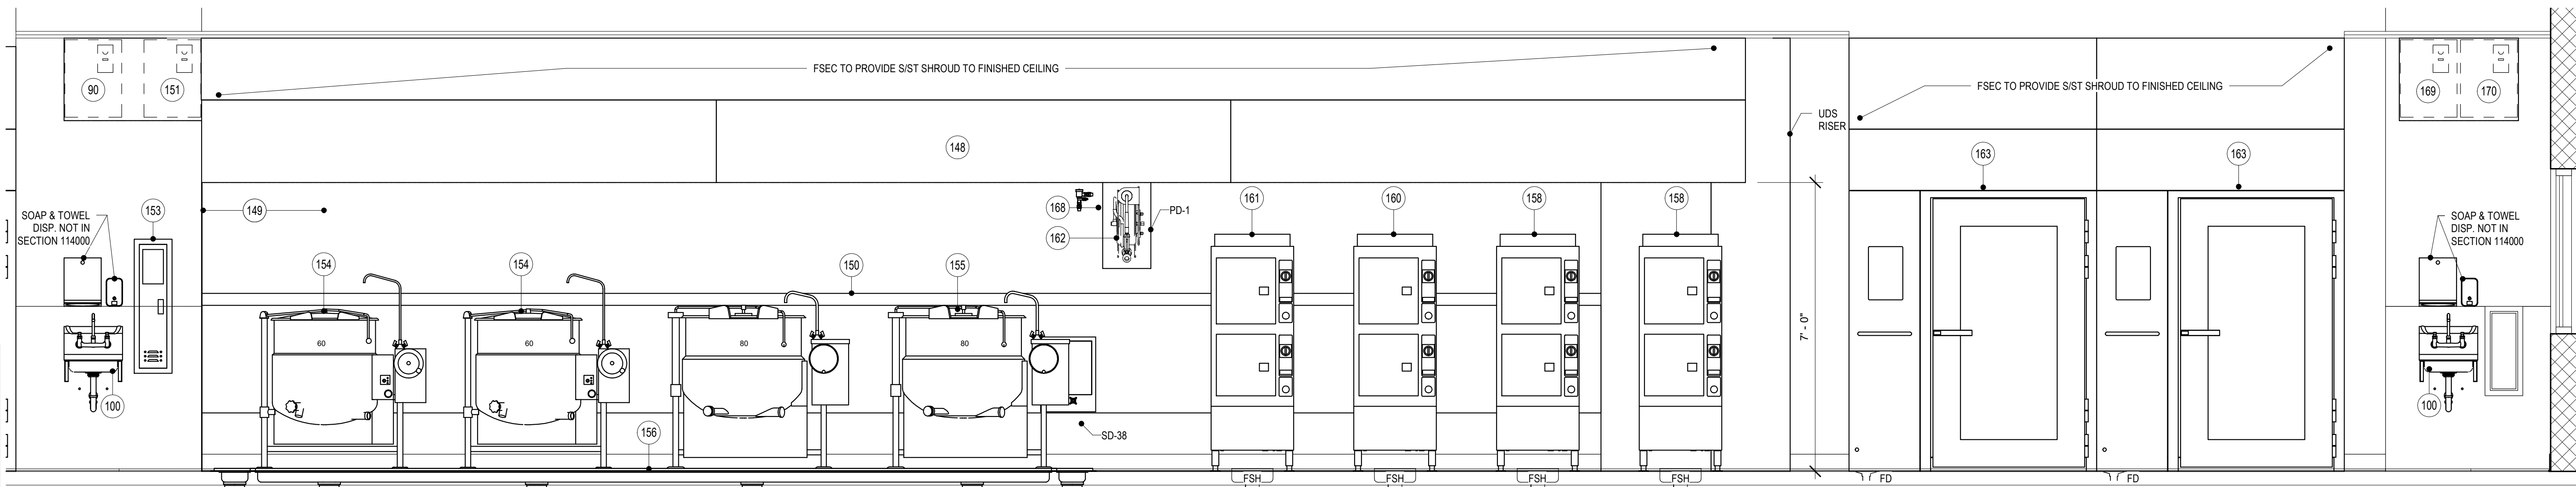

5 ITEM 148 - EXHAUST HOOD (TYPE I)
1/2" = 1'-0"

BID SET

PROJECT:
STATE OF IOWA DEPARTMENT
OF CORRECTIONS

**CLARINDA
CORRECTIONAL
FACILITY - KITCHEN &
LAUNDRY ADDITION**

2000 N 16TH ST, CLARINDA, IA
51632

DATE: 02/09/2024

DESIGNED: EG/TP

DRAWN: MM/BB


REVIEWED: EG/RB

SHEET TITLE:
**FOODSERVICE
EQUIPMENT
ELEVATIONS AND
SECTIONS**


SHEET NUMBER:

FS201


PROJECT NO.: 0240202.00
RFB922300-02

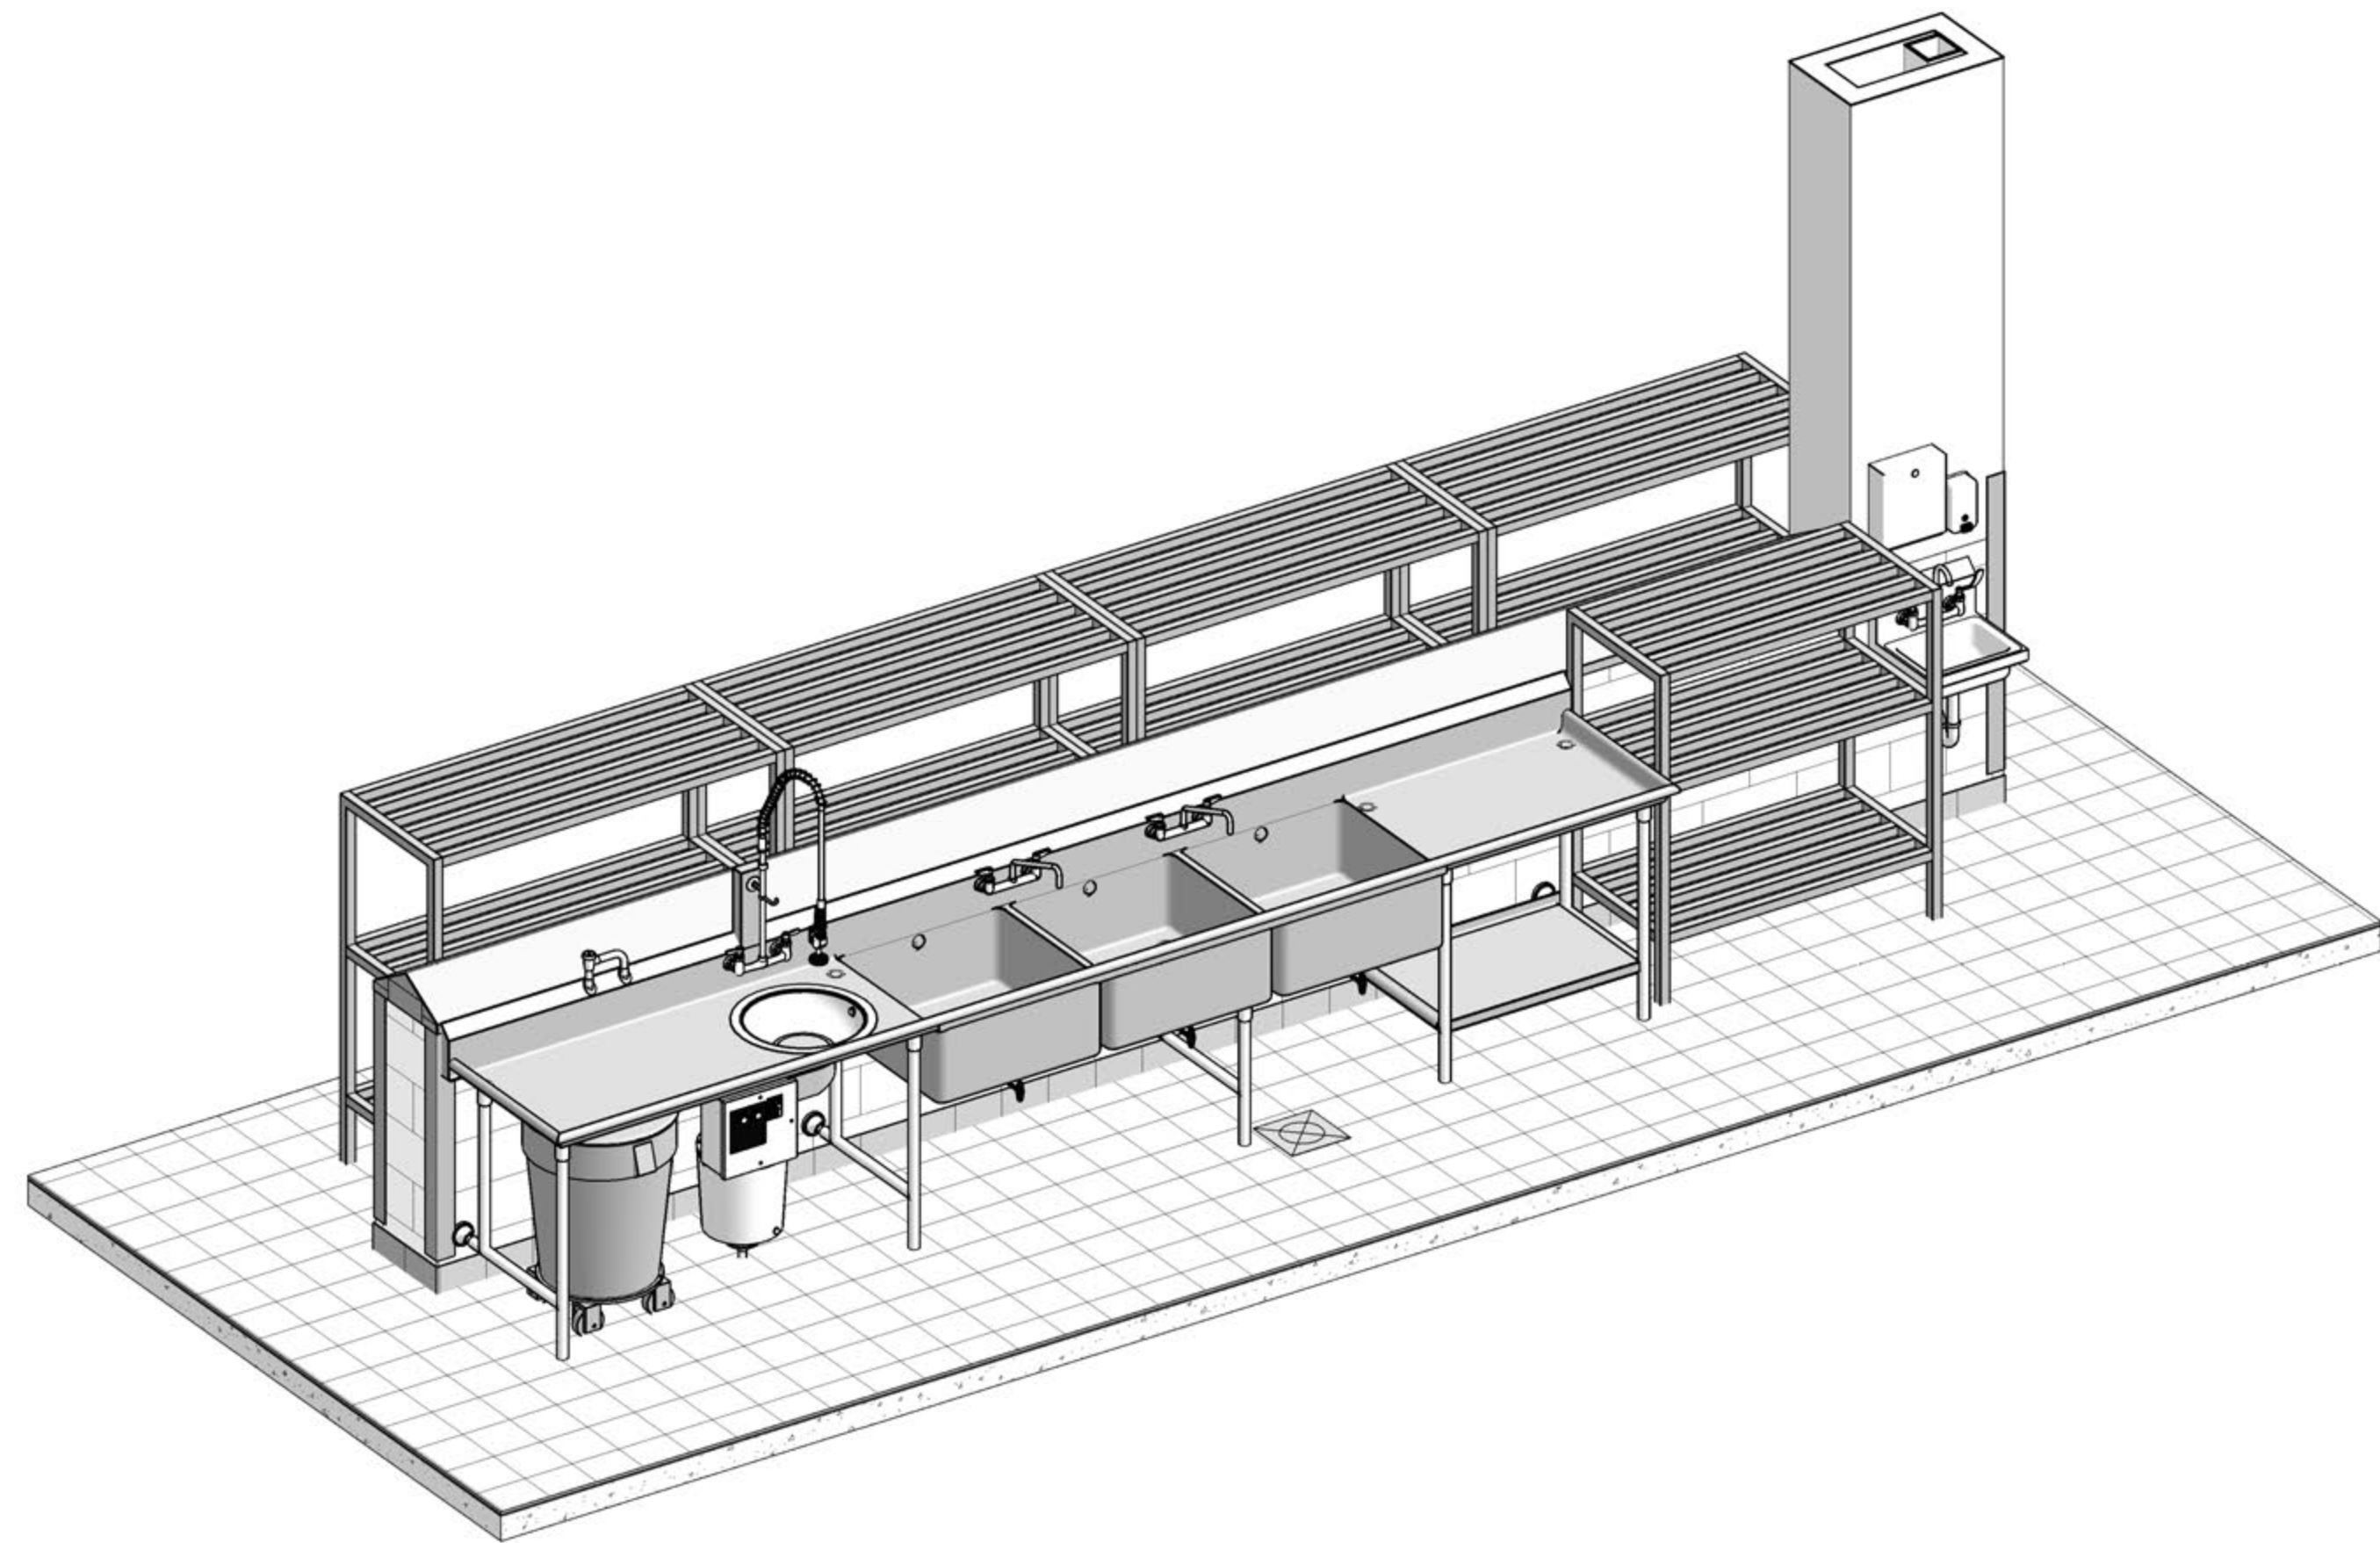


POT AND PAN WASH

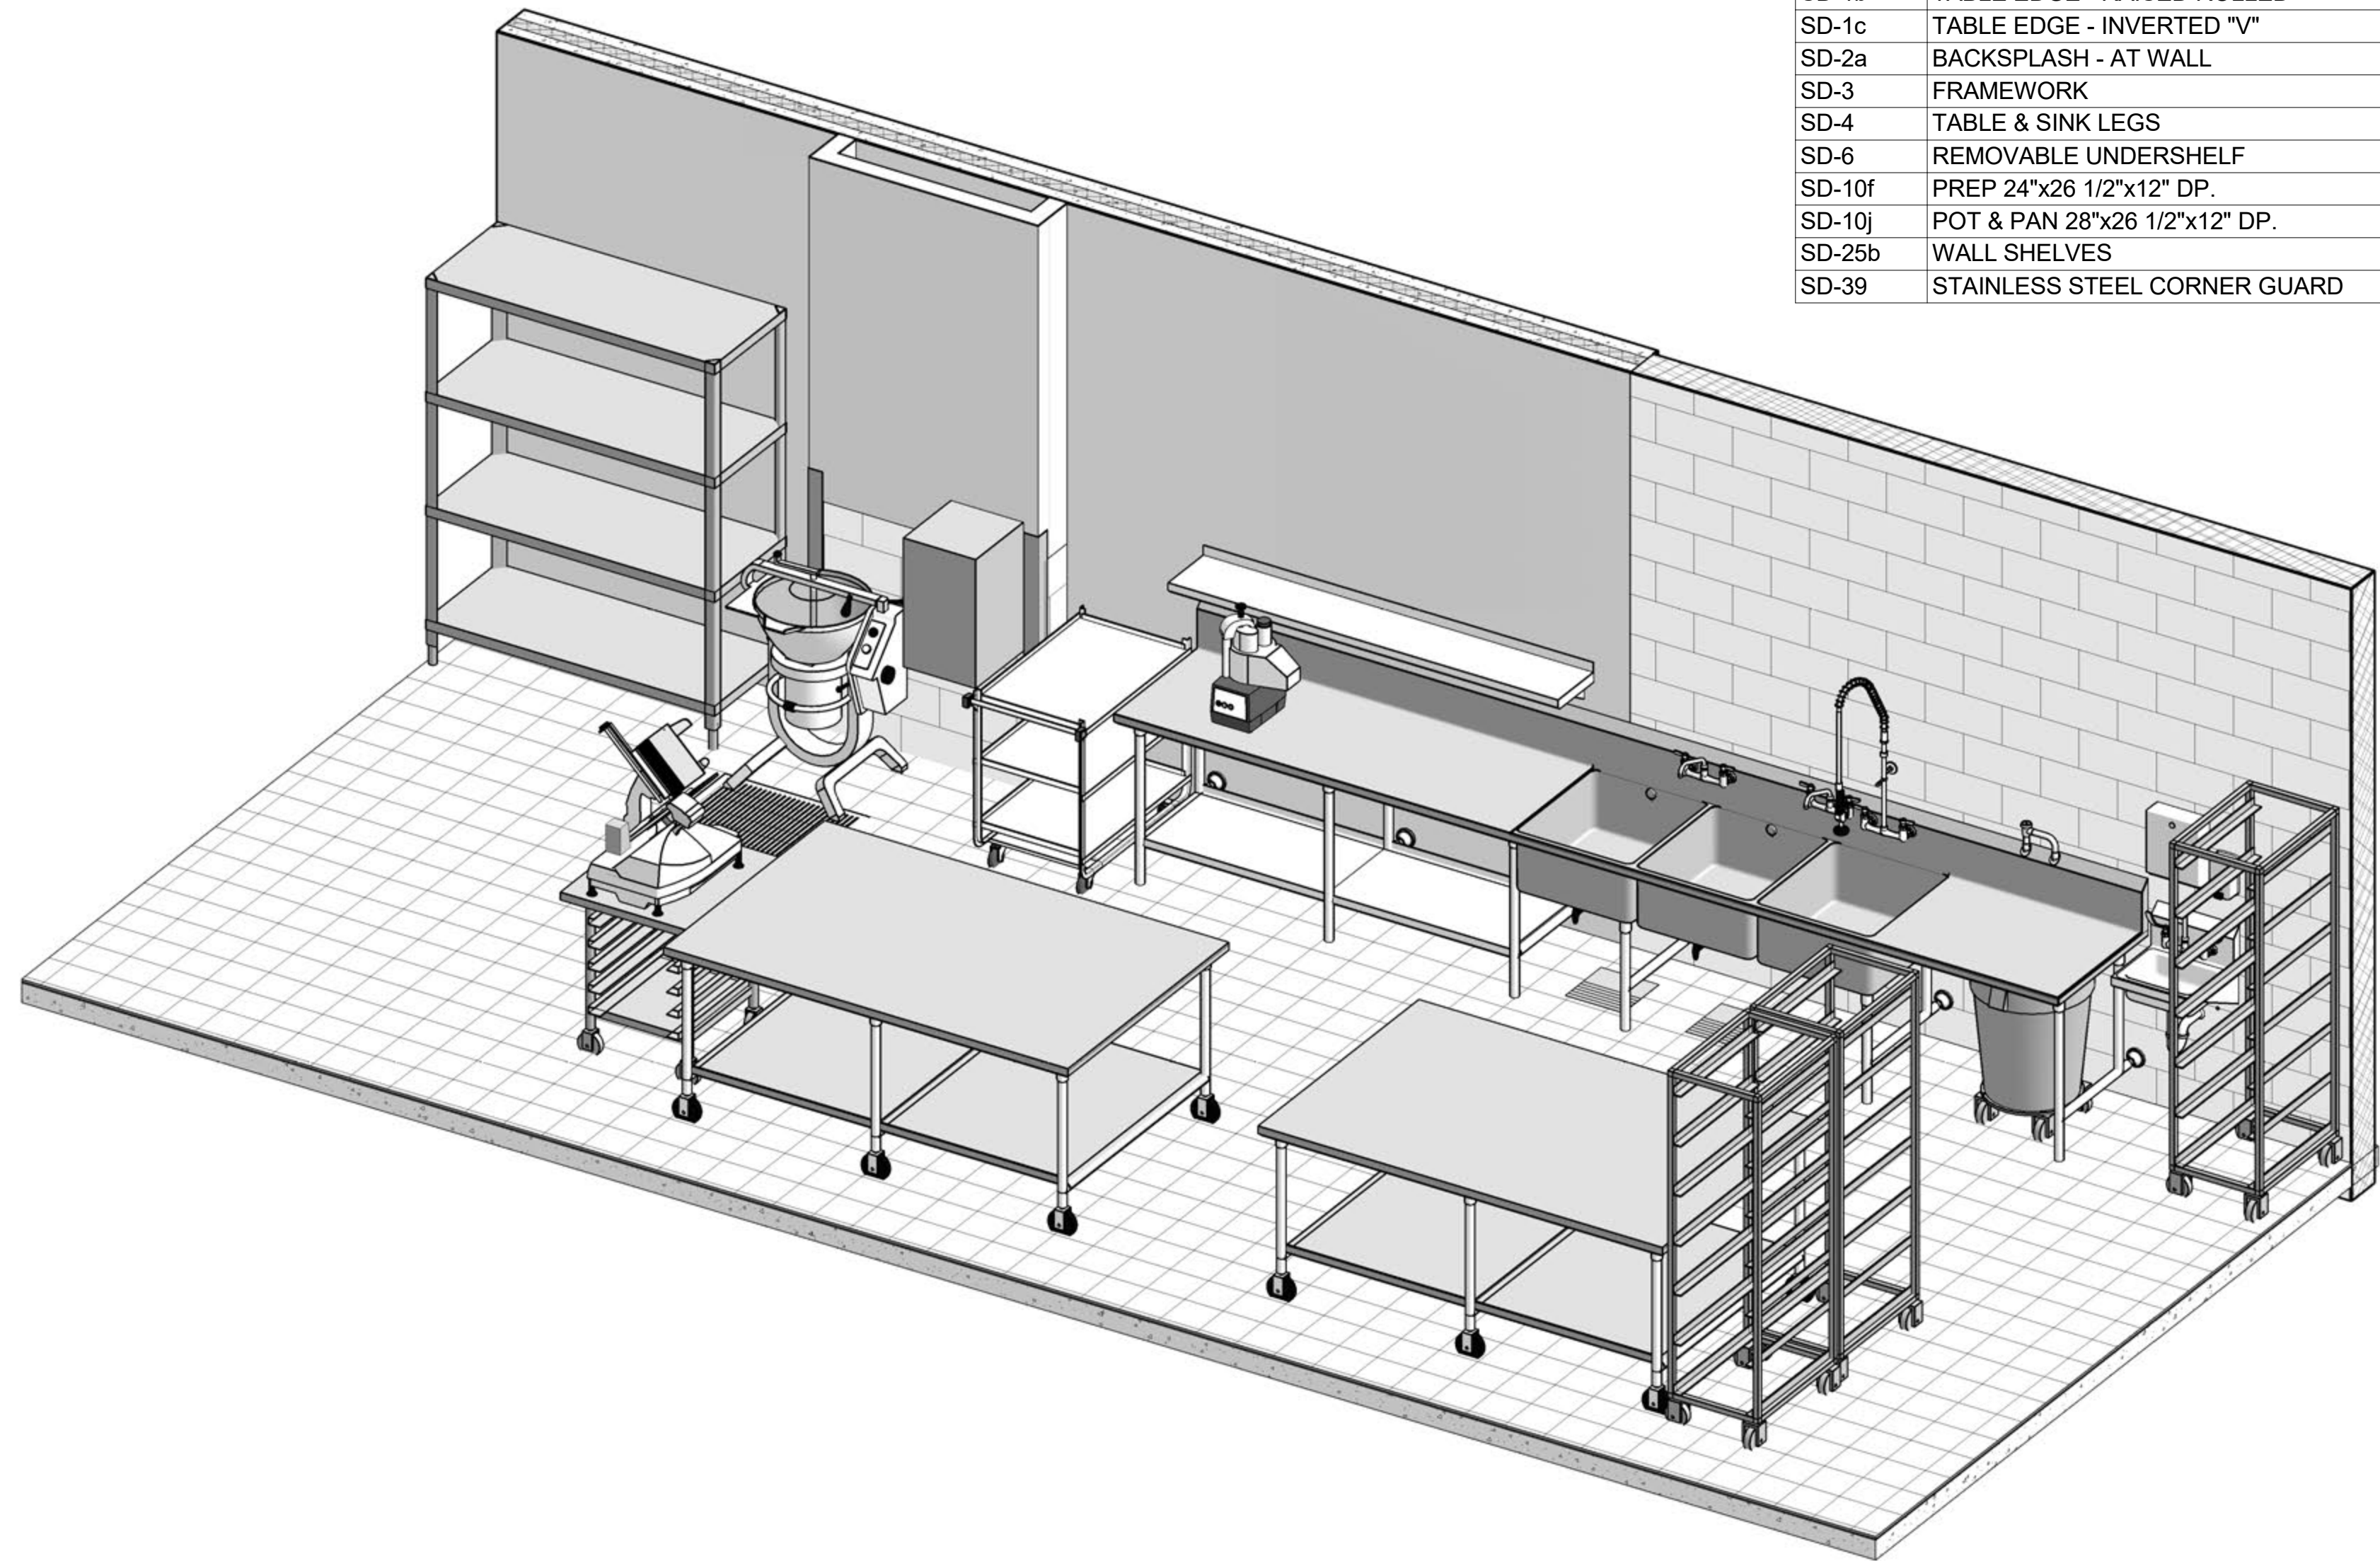


COLD FOOD PREP

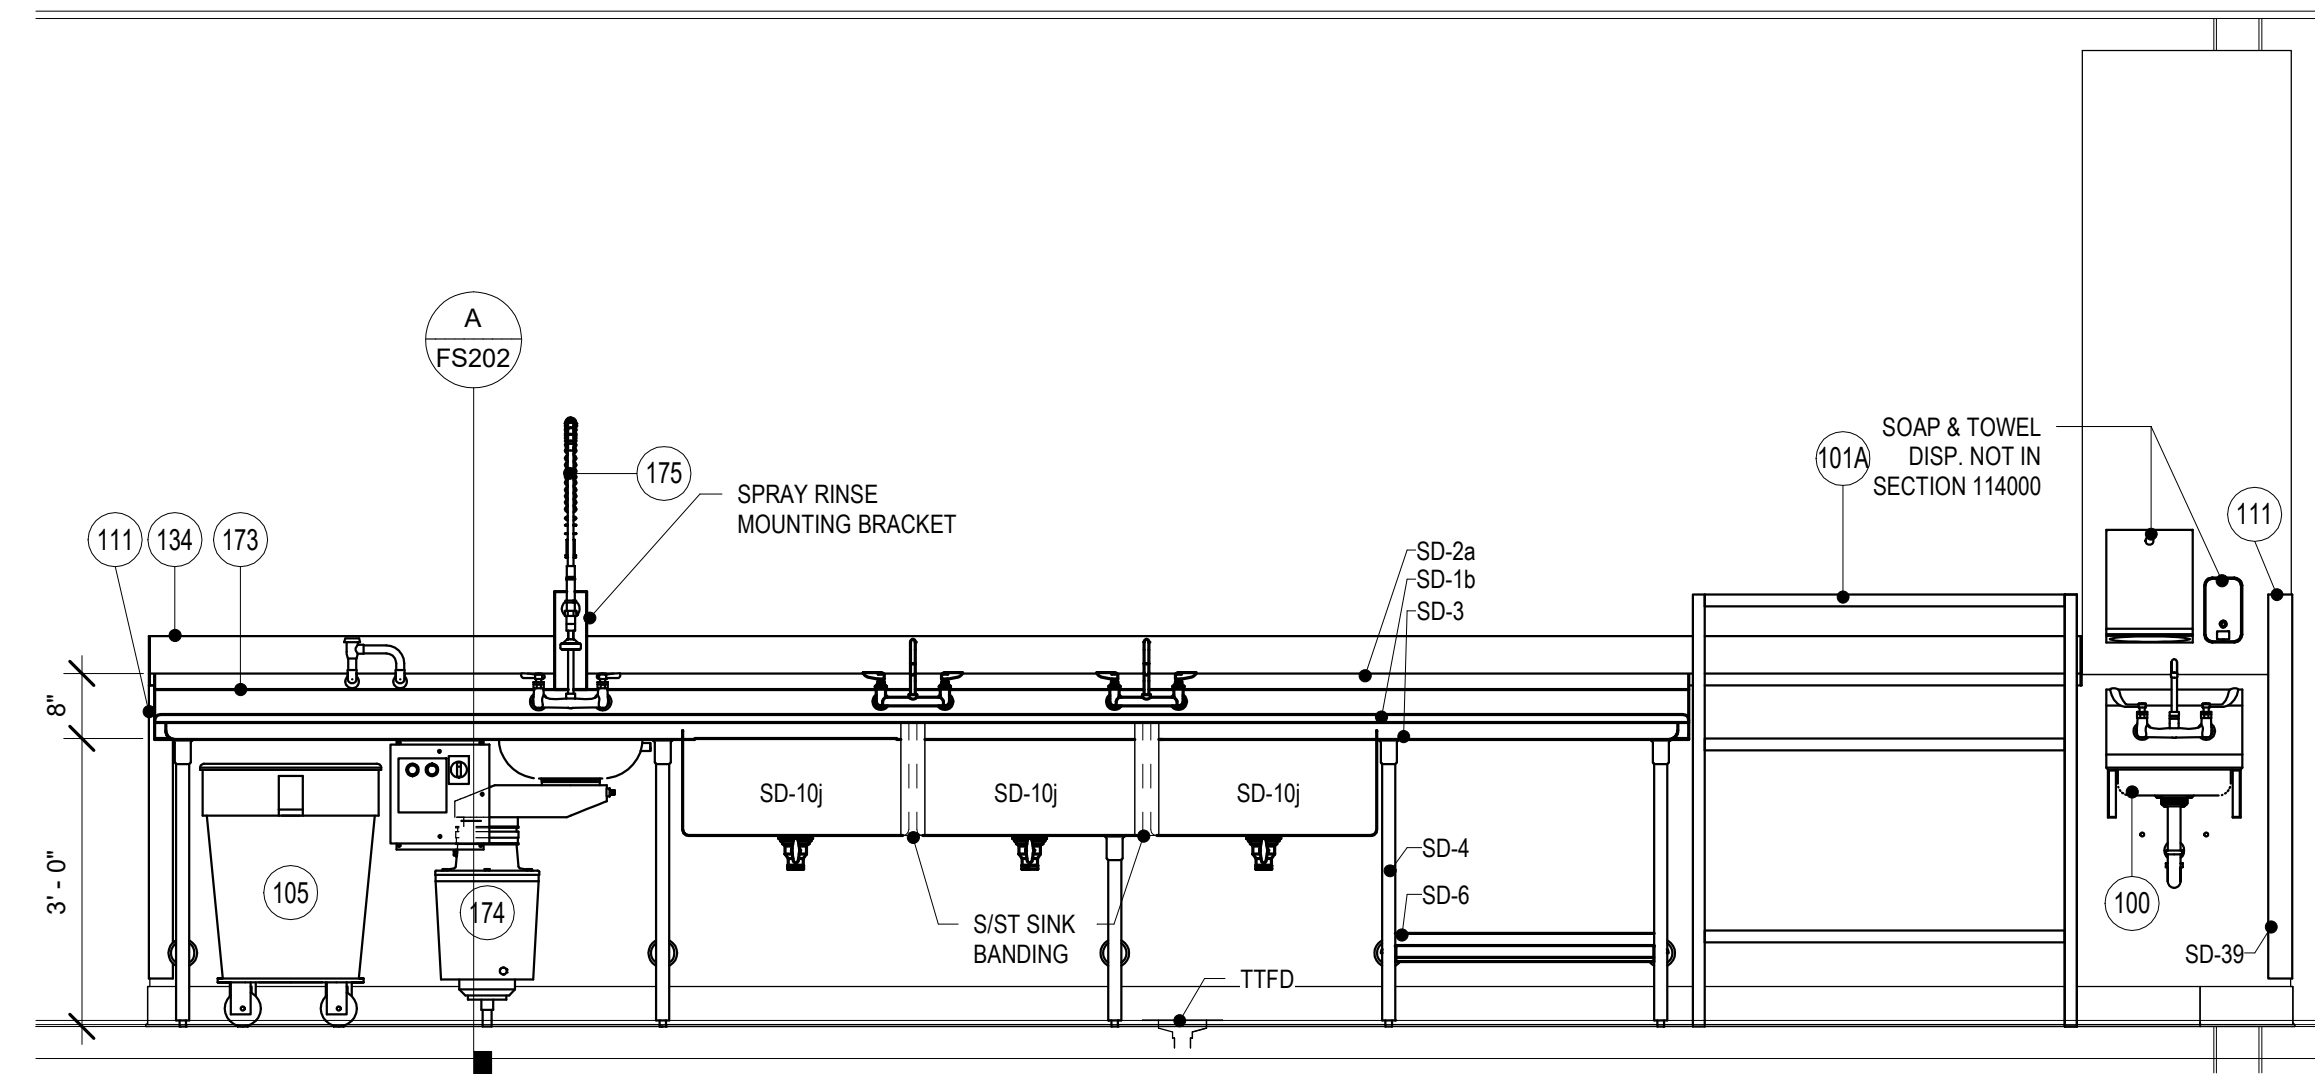


1 ITEM 173 - POT & PAN SINK
1/2" = 1'-0"

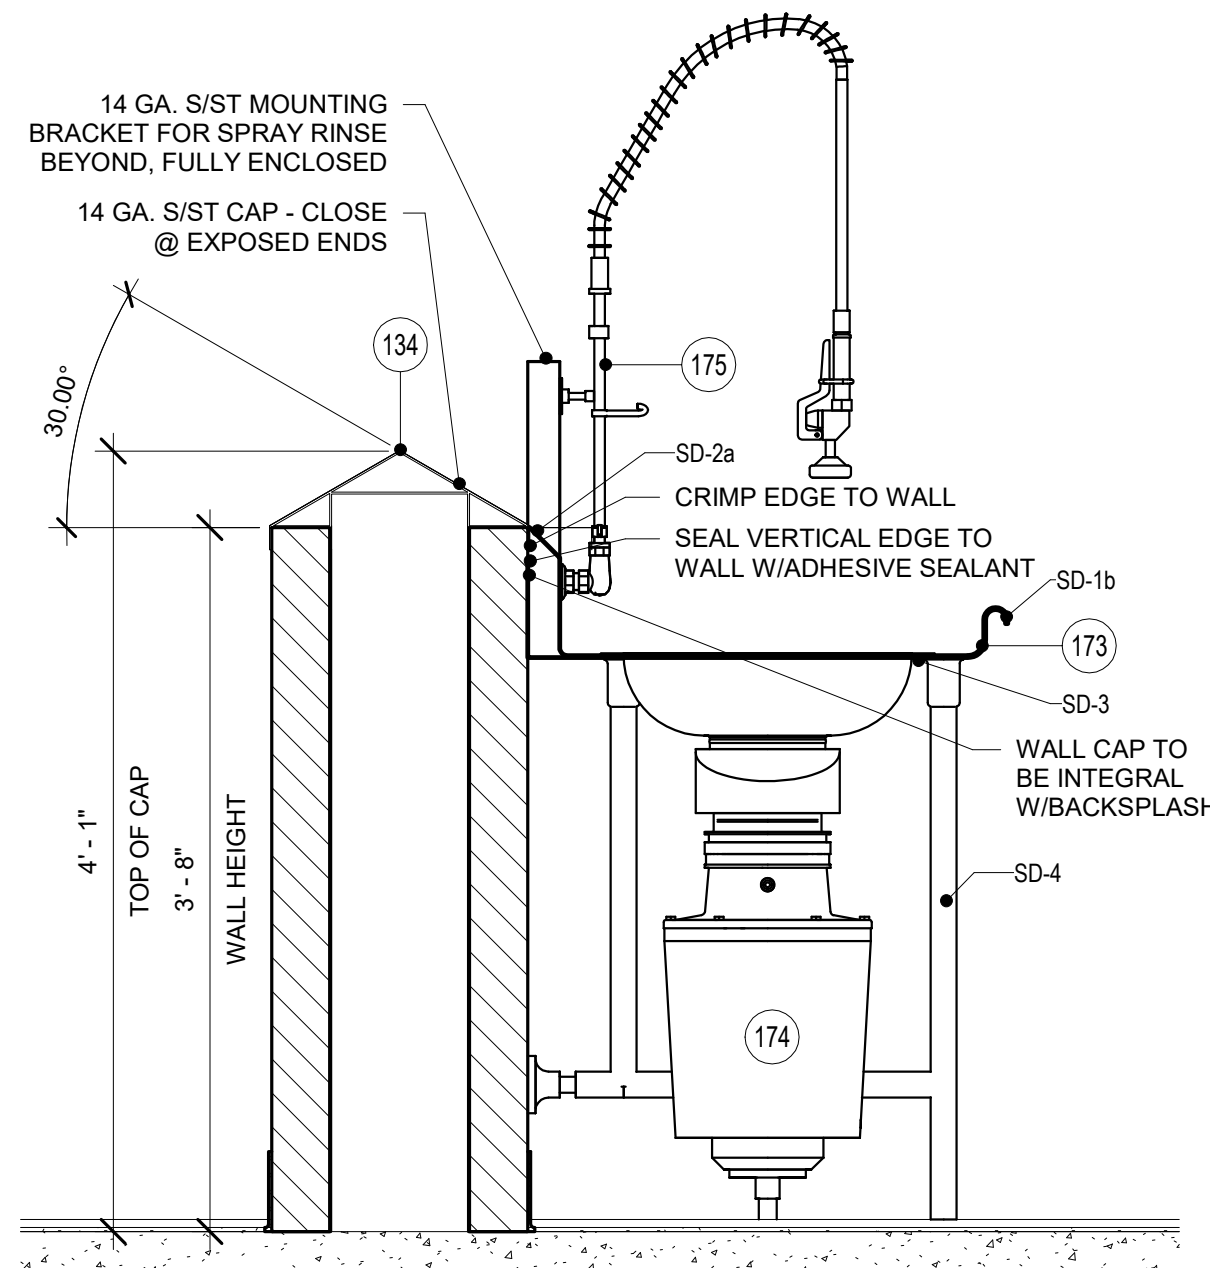

A SECTION THRU WALL CAP 1
1" = 1'-0"

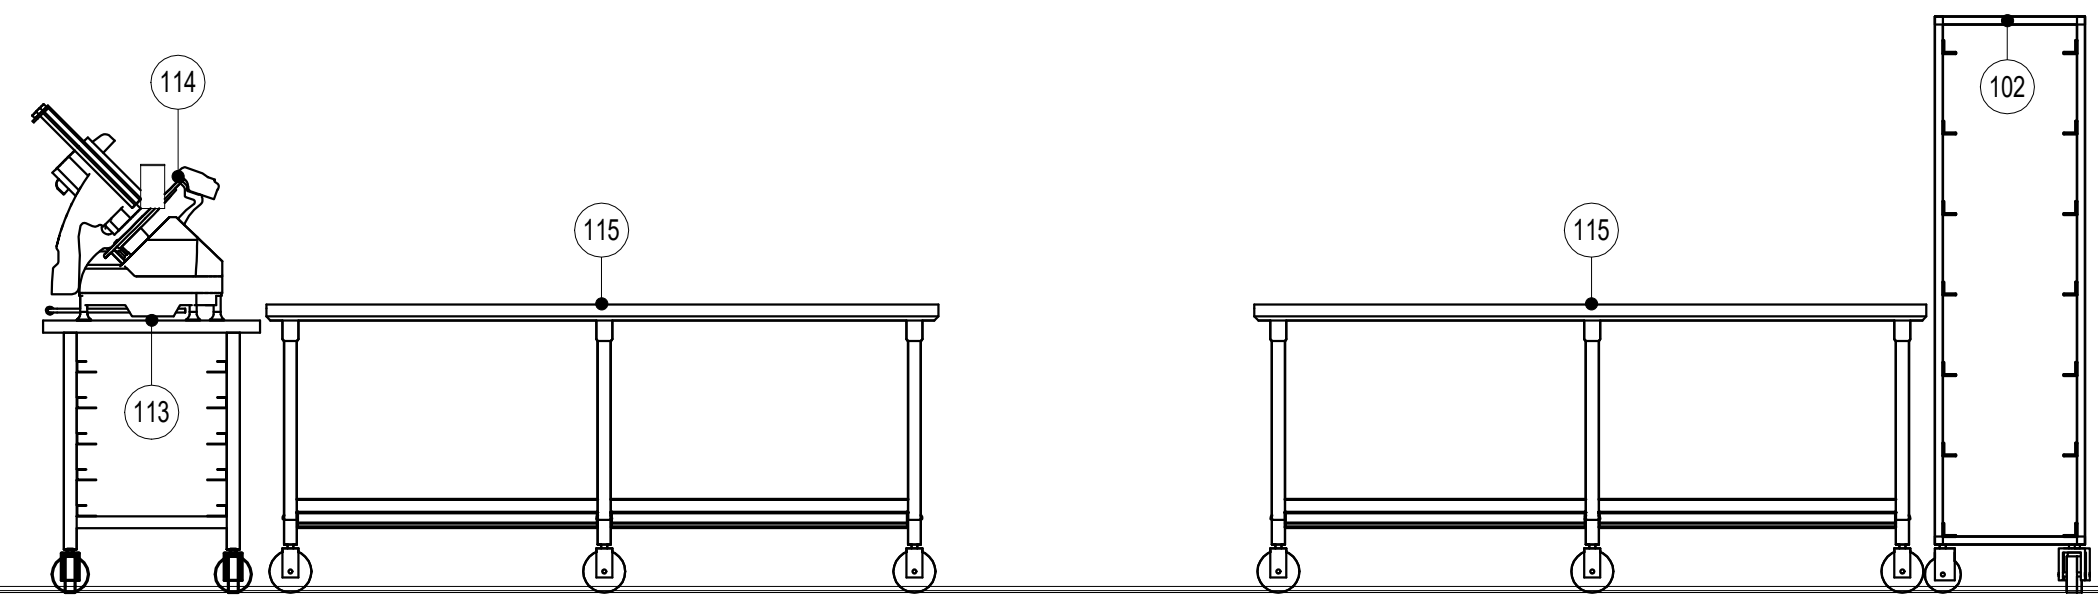


2 ITEM 115 - WORKCOUNTERS
1/2" = 1'-0"

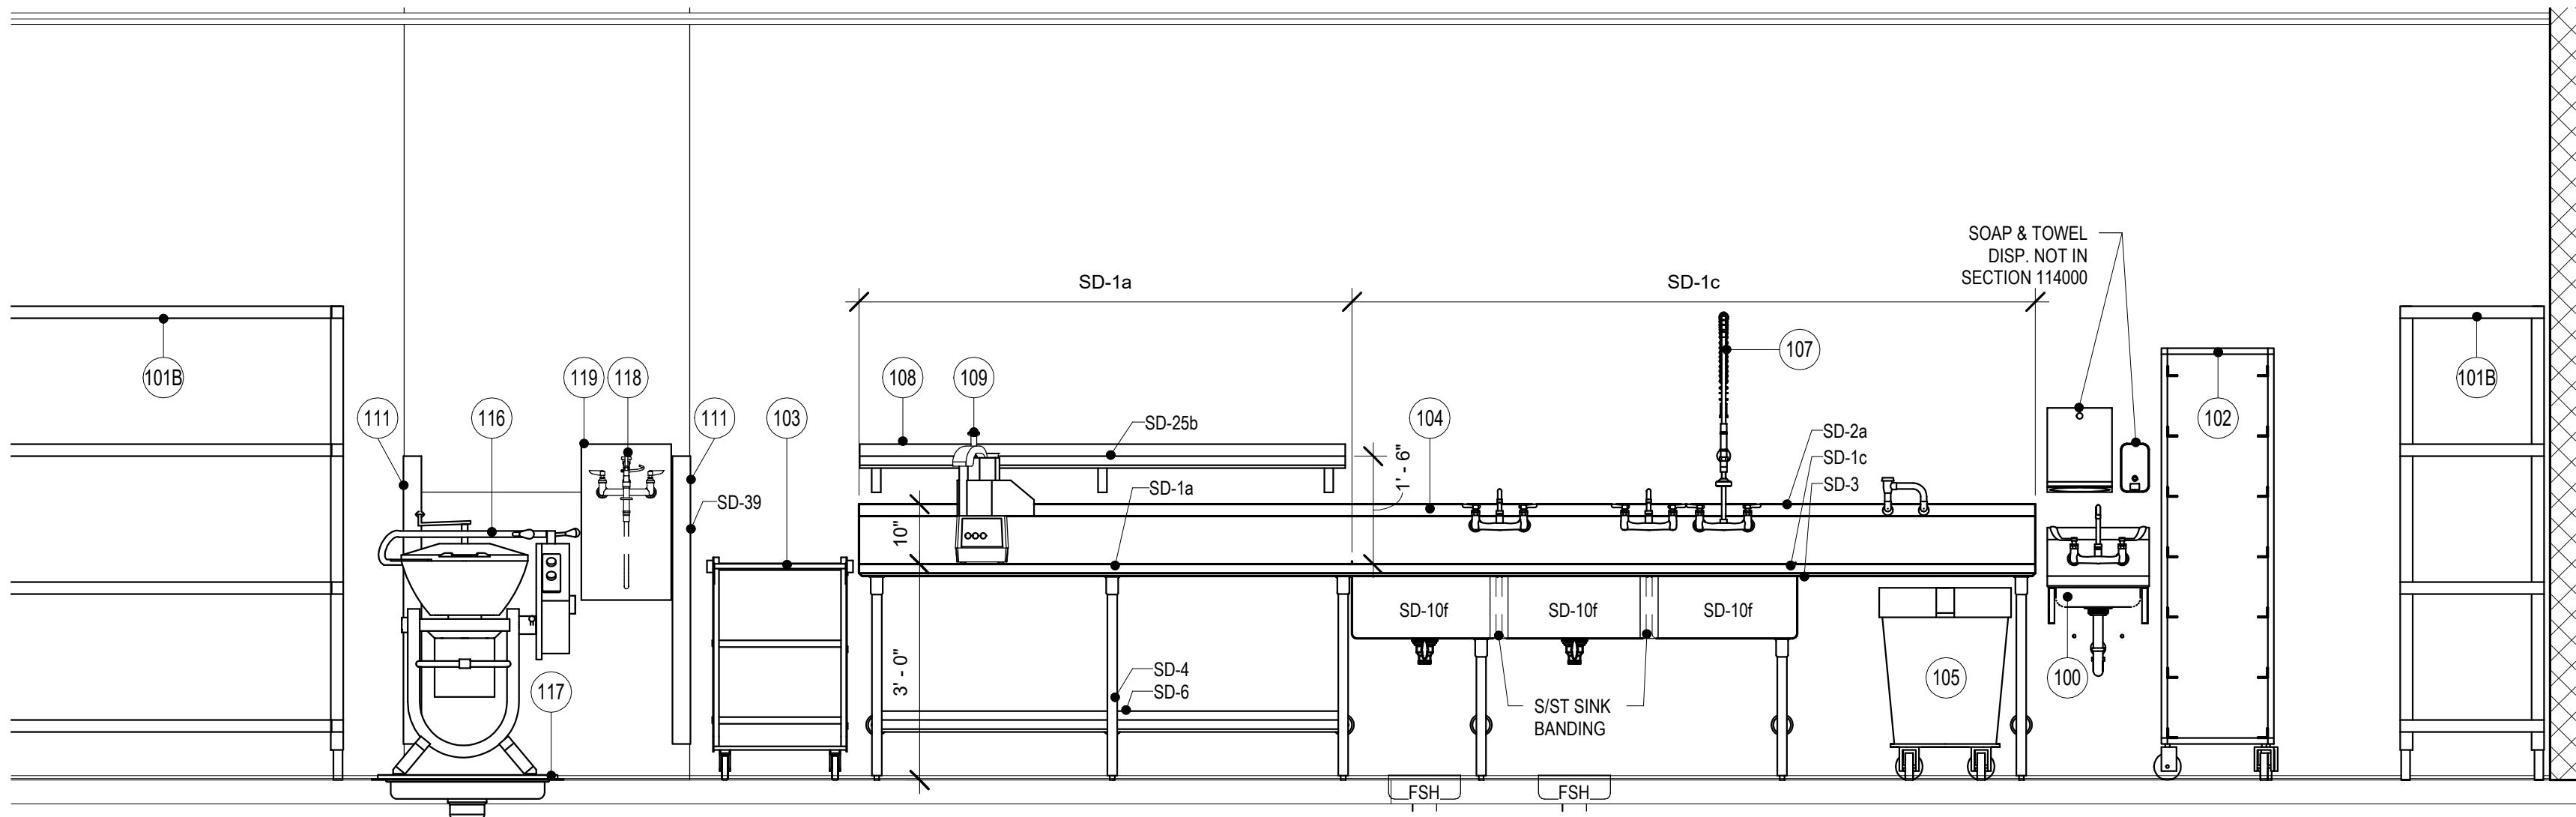

3 ITEM 104 - WORKCOUNTER W/ SINKS
1/2" = 1'-0"

RRA KEYNOTE LEGEND	
KEYNOTE	KEYNOTE TEXT
SD-1a	TABLE EDGE - TURN DOWN
SD-1b	TABLE EDGE - RAISED ROLLED
SD-1c	TABLE EDGE - INVERTED "V"
SD-2a	BACKSPLASH - AT WALL
SD-3	FRAMEWORK
SD-4	TABLE & SINK LEGS
SD-6	REMOVABLE UNDERSHELF
SD-10f	PREP 24"x26 1/2"x12" DP.
SD-10j	POT & PAN 28"x26 1/2"x12" DP.
SD-25b	WALL SHELVES
SD-39	STAINLESS STEEL CORNER GUARD

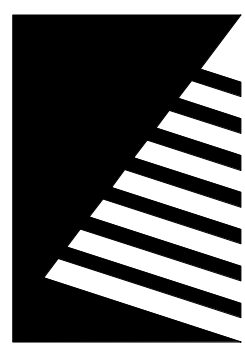

Farnsworth
GROUP

14225 UNIVERSITY AVENUE, SUITE 110
WALKEE, IOWA 50263
(515) 225-3469 / info@f-w.com

www.f-w.com
Engineers | Architects | Surveyors | Scientists

RIPPE ASSOCIATES
FOODSERVICE DESIGN + CONSULTING

kpff

IMEG

Bishop Engineering

ISSUE:
DATE: DESCRIPTION:

BID SET

PROJECT:
STATE OF IOWA DEPARTMENT
OF CORRECTIONS

CLARINDA
CORRECTIONAL
FACILITY - KITCHEN &
LAUNDRY ADDITION

2000 N 16TH ST, CLARINDA, IA
51632

DATE: 02/09/2024

DESIGNED: EG/TP

DRAWN: MM/BB


REVIEWED: EG/RB

SHEET TITLE:
FOODSERVICE
EQUIPMENT
ELEVATIONS AND
SECTIONS


SHEET NUMBER:

FS202


PROJECT NO.: 0240202.00
RFB922300-02

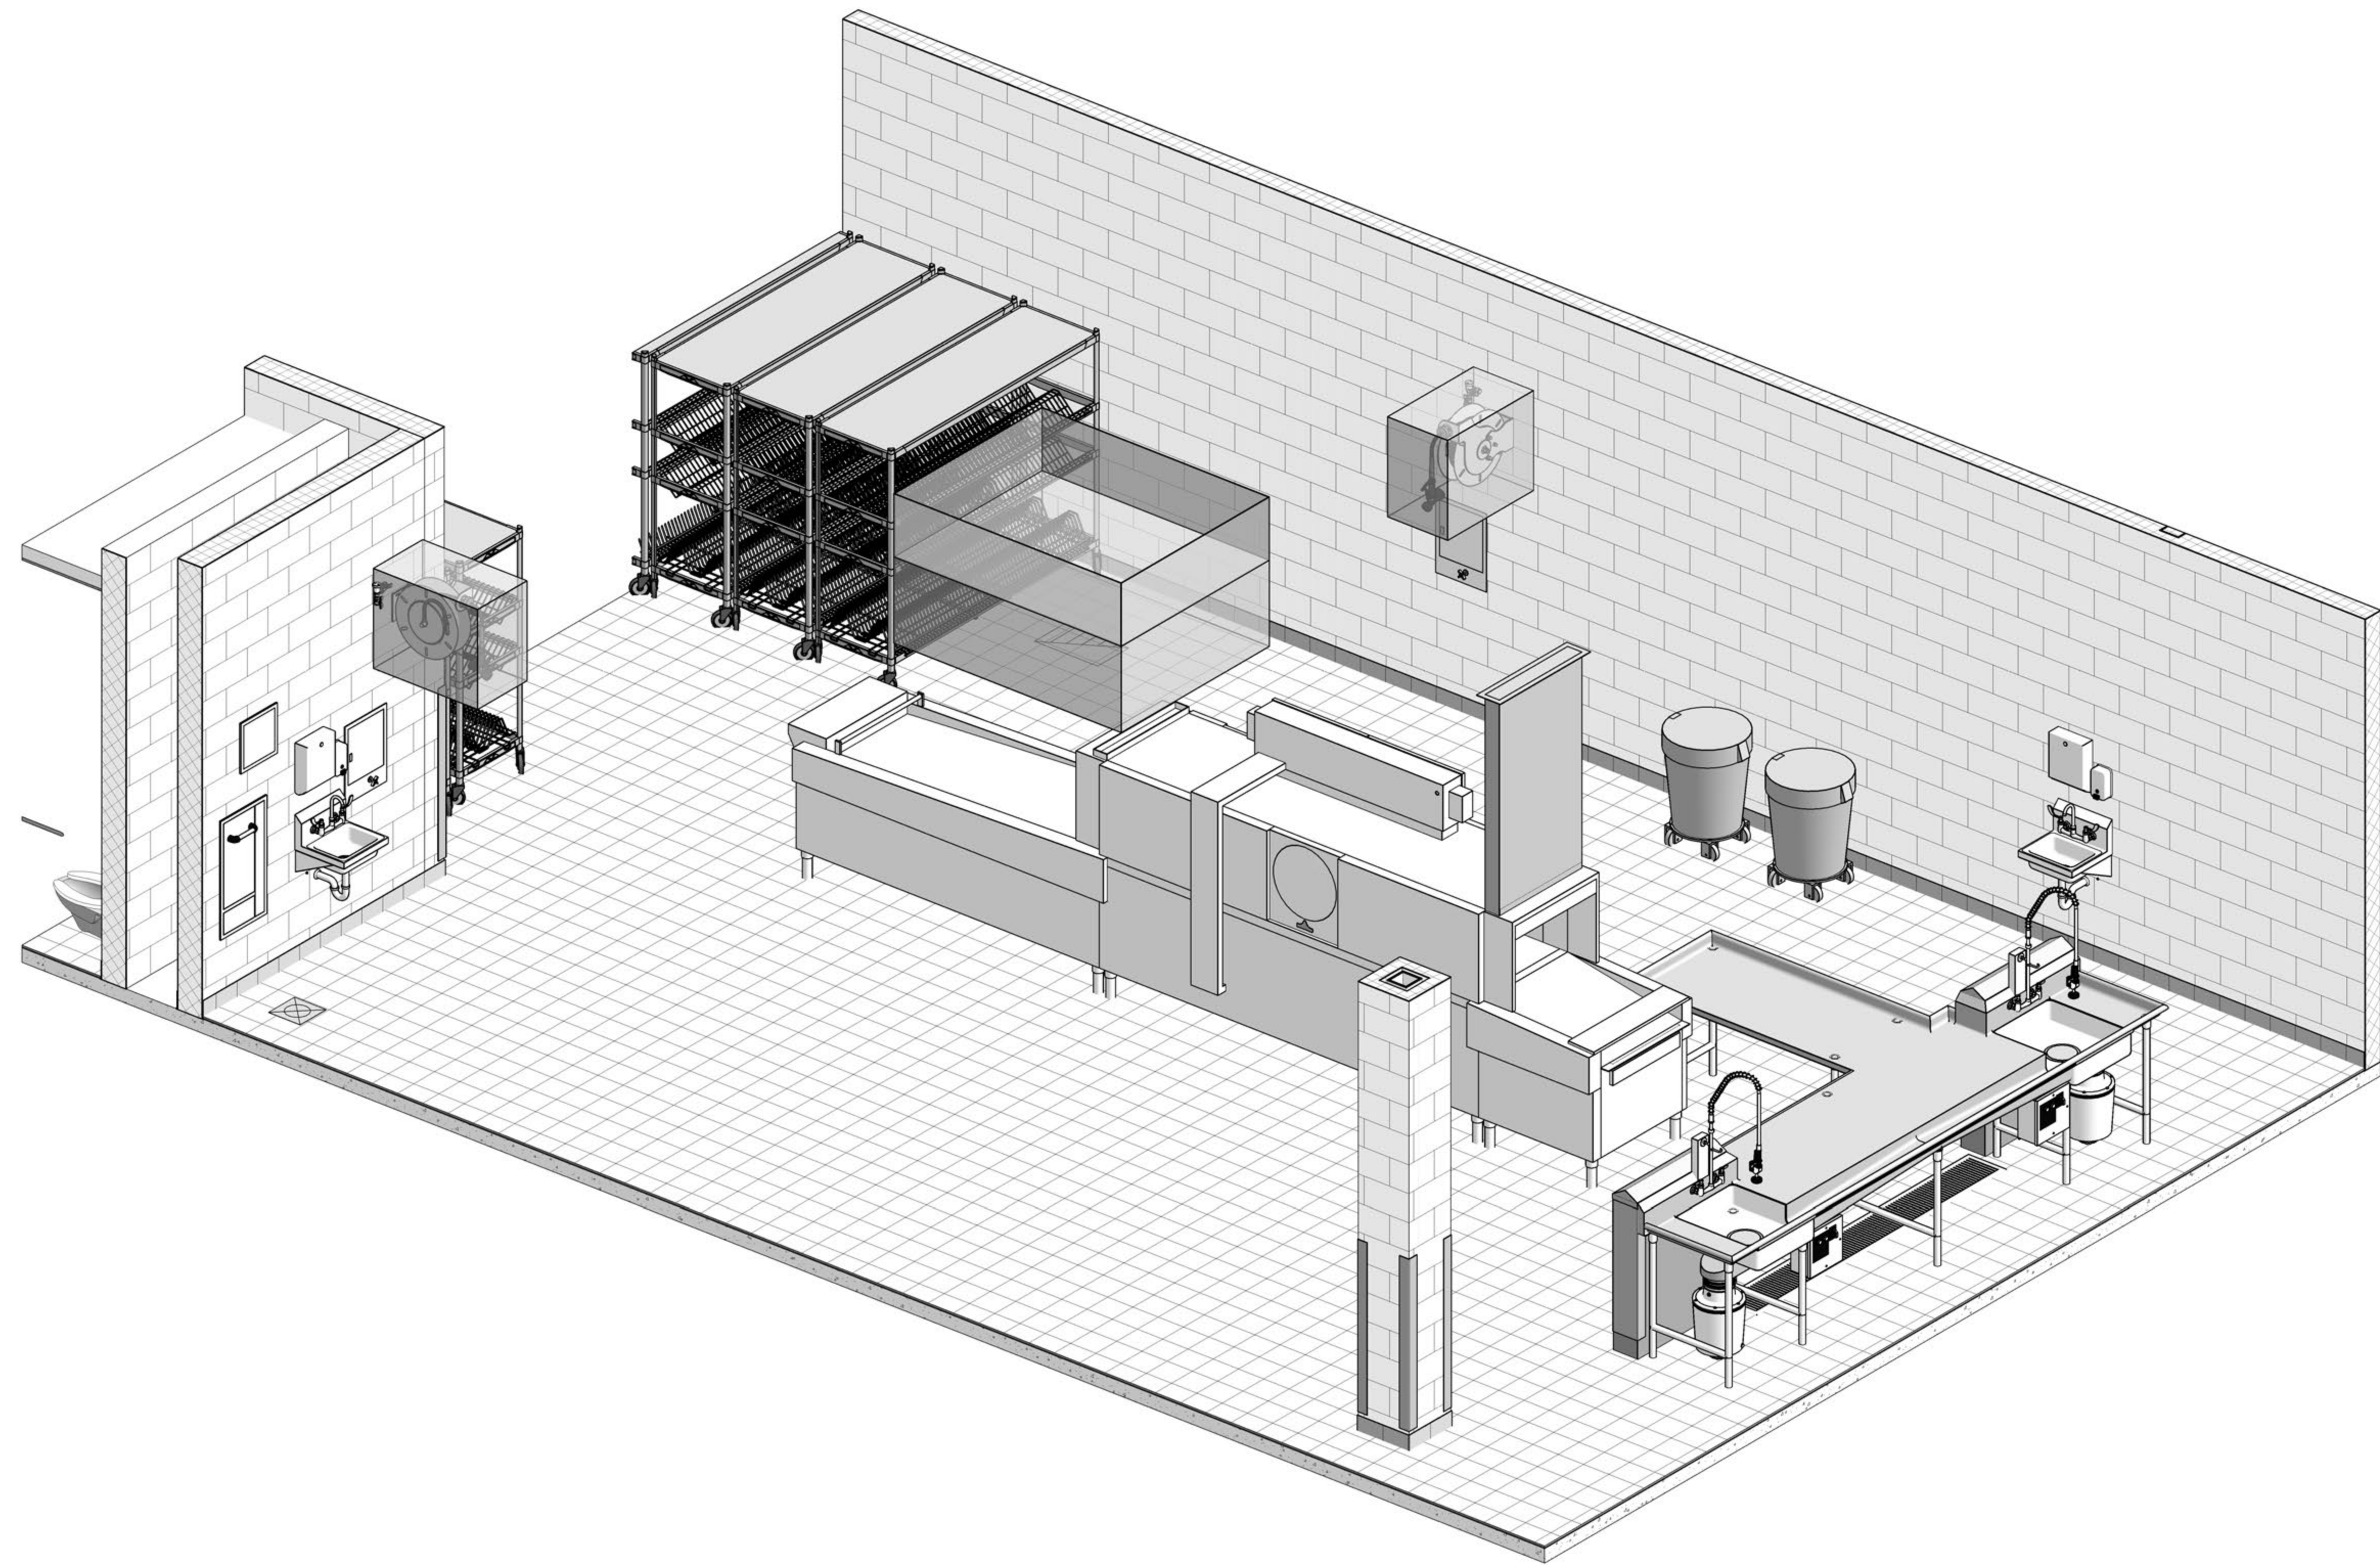


DISHROOM

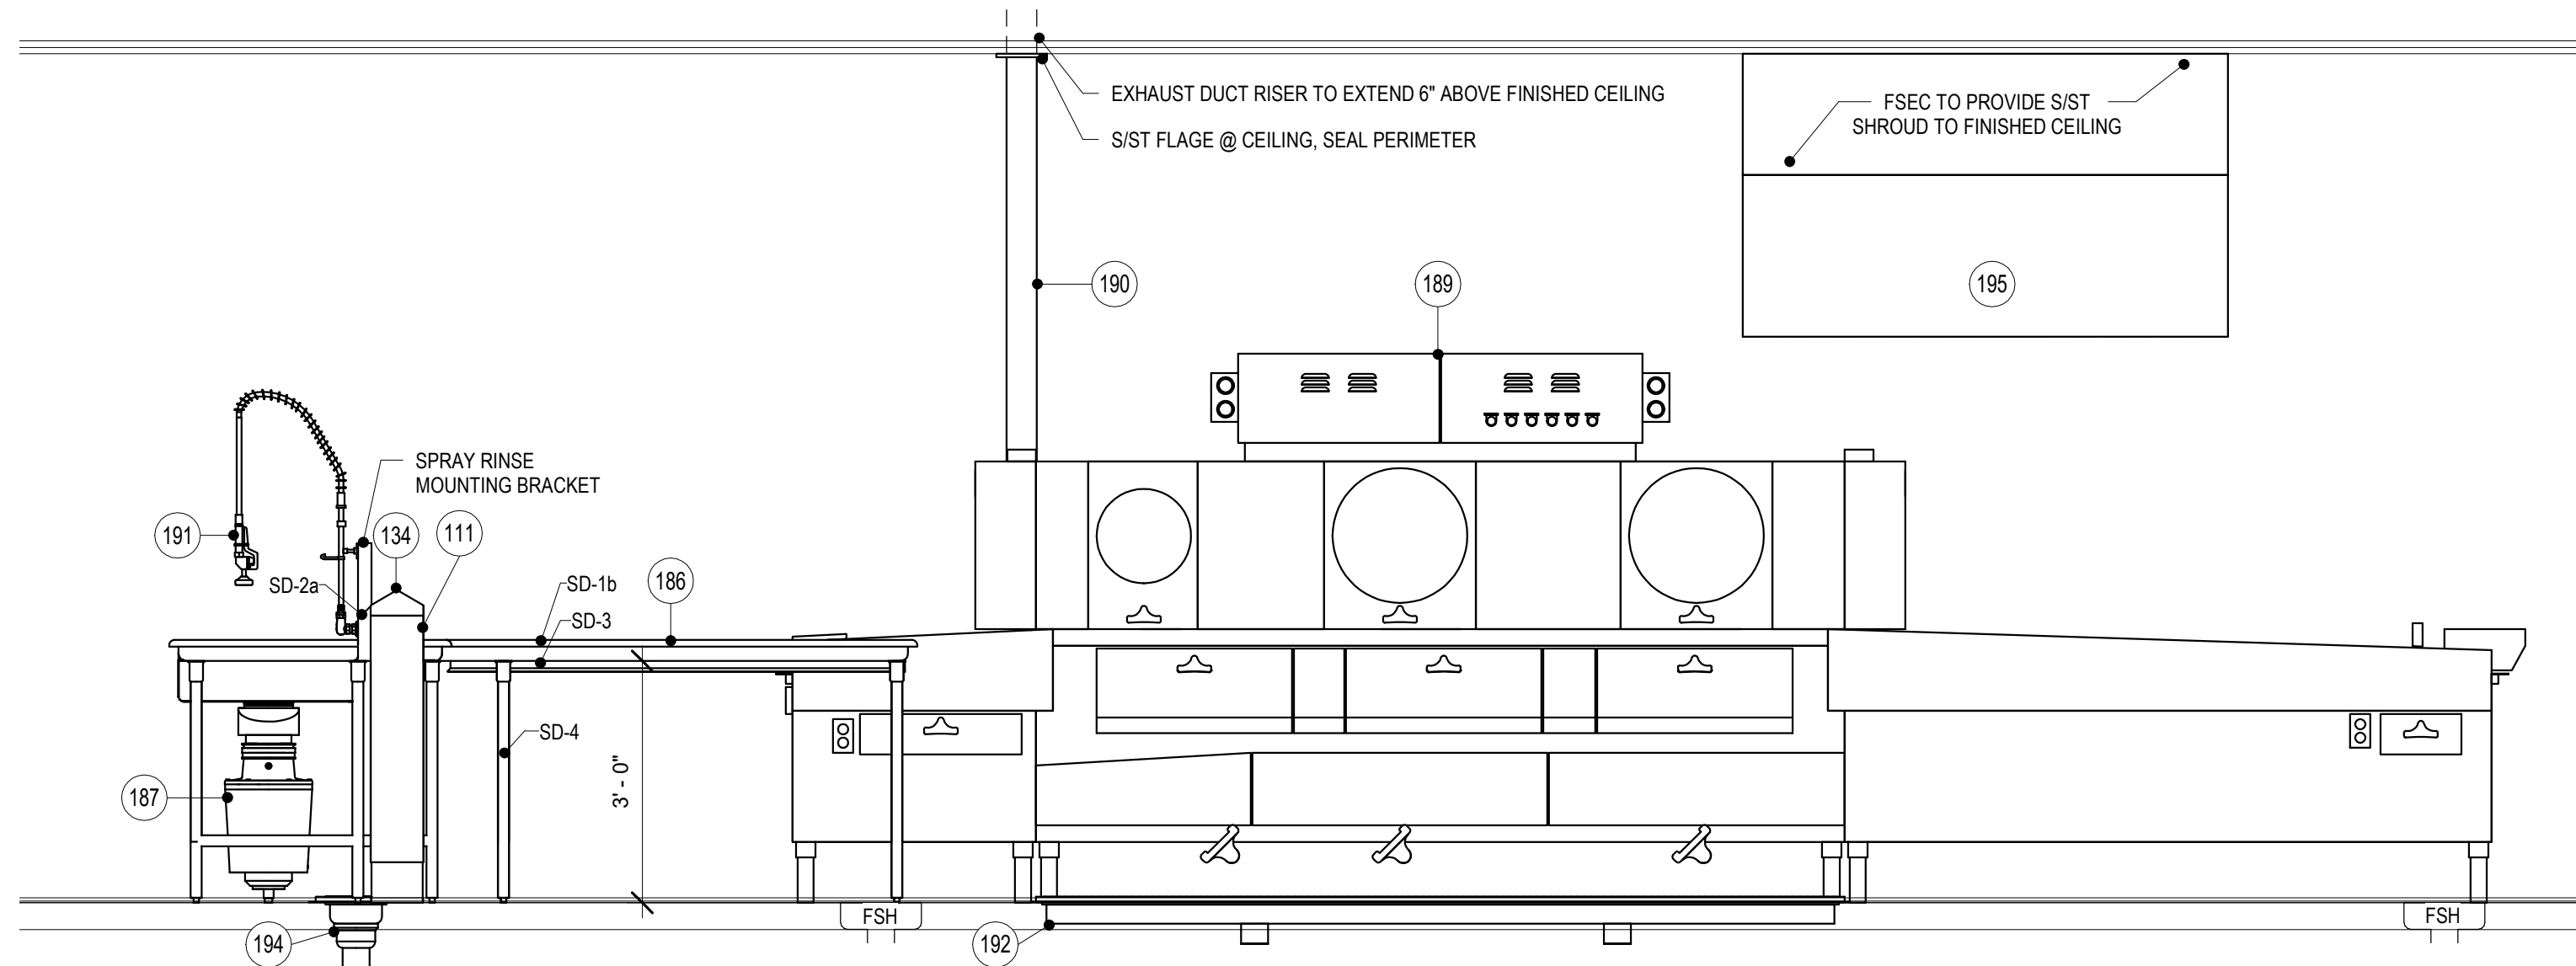

1 ITEM 186 - WORKCOUNTER W/ SINK & VENT DUCT RISERS
1/2" = 1'-0"

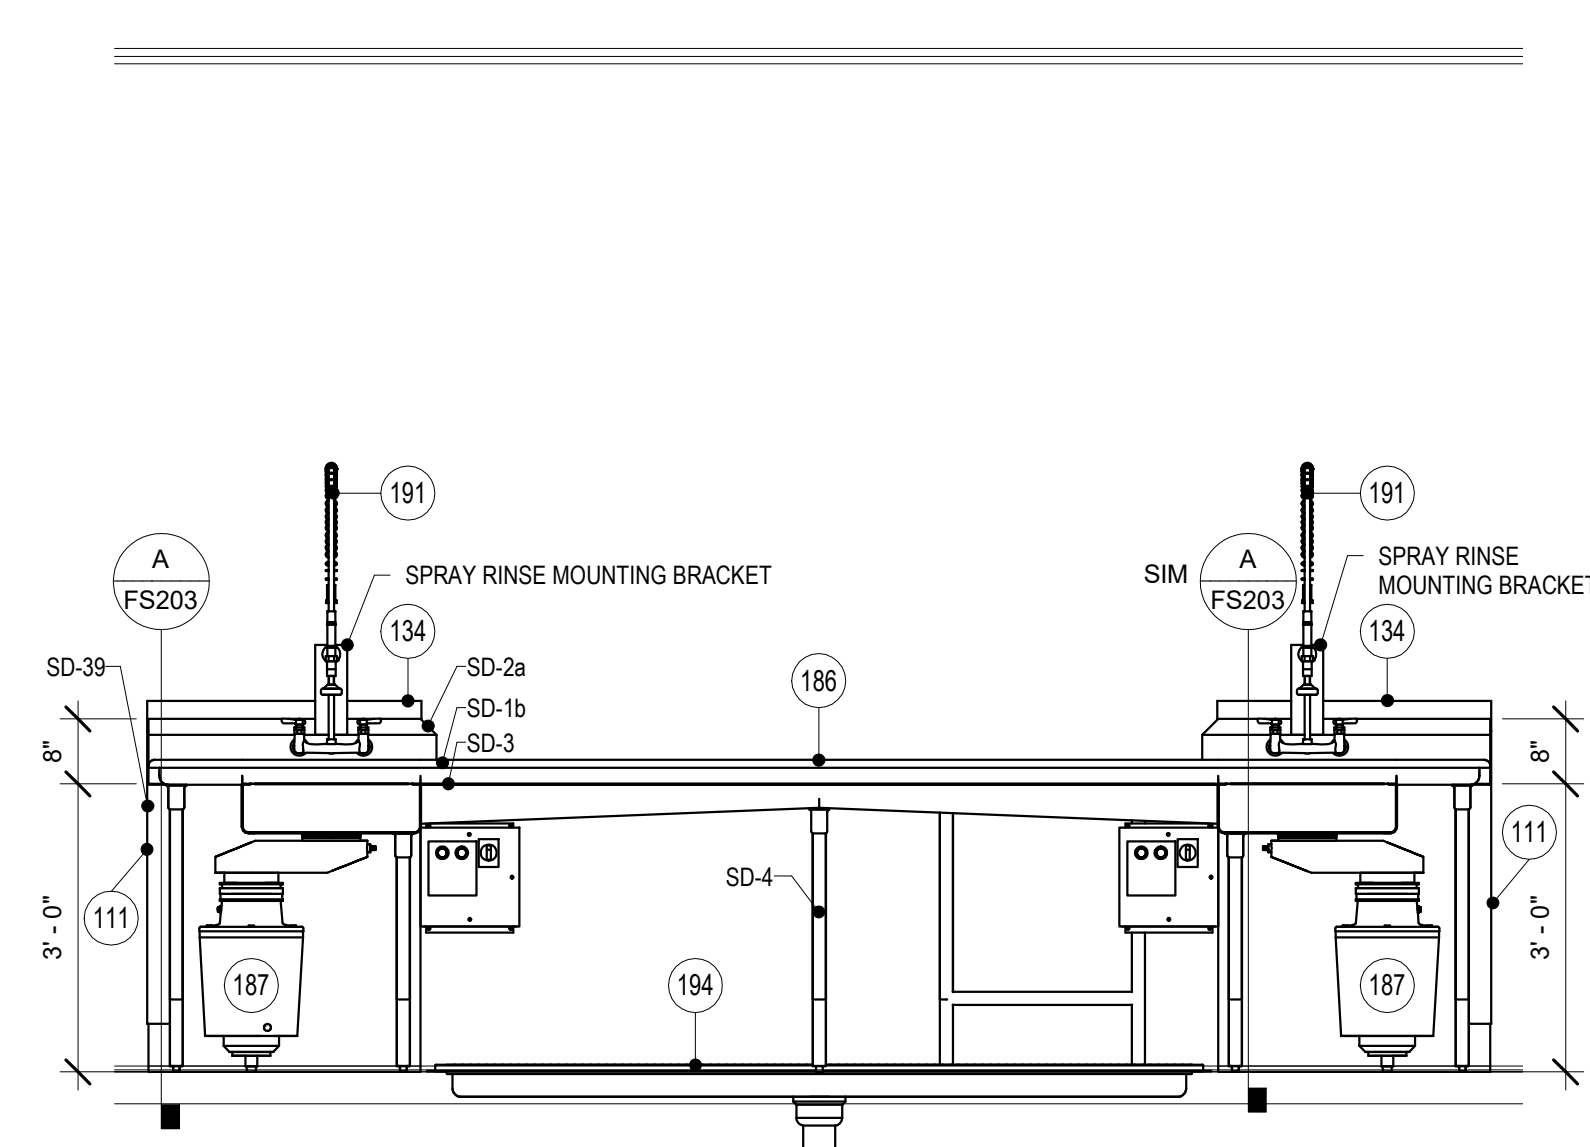


2 ITEM 186 - WORKCOUNTER W/ SINK
1/2" = 1'-0"

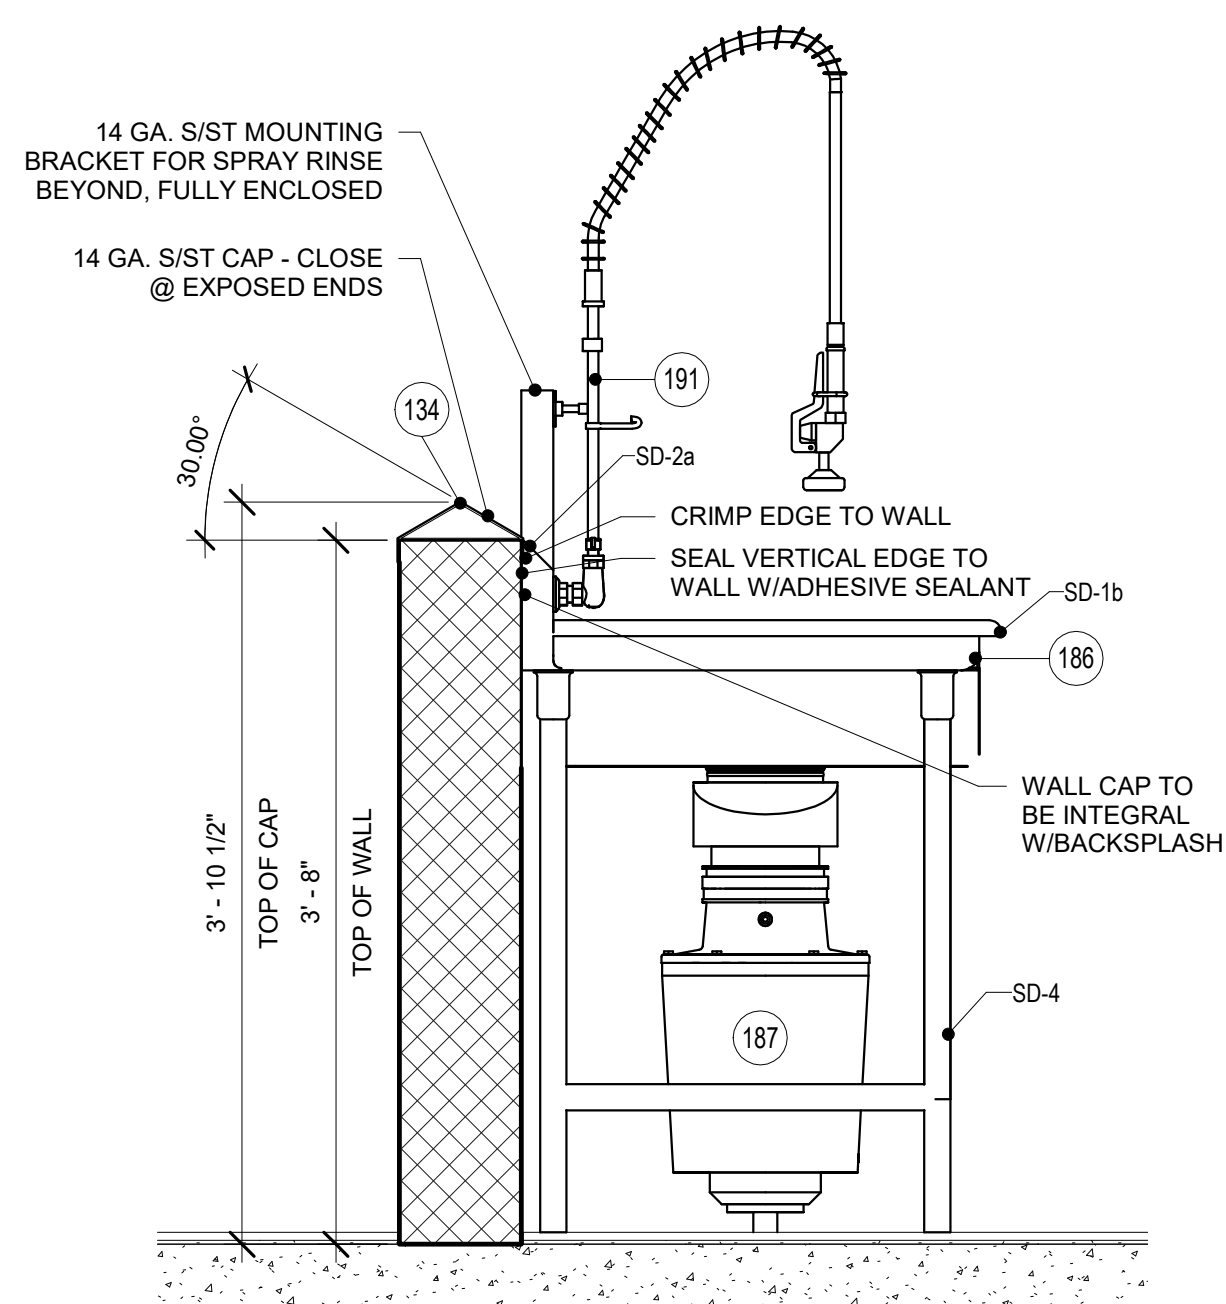

A SECTION THRU WALL CAP 2
1" = 1'-0"

RRA KEYNOTE LEGEND	
KEYNOTE	KEYNOTE TEXT
SD-1b	TABLE EDGE - RAISED ROLLED
SD-2a	BACKSPLASH - AT WALL
SD-3	FRAMEWORK
SD-4	TABLE & SINK LEGS
SD-39	STAINLESS STEEL CORNER GUARD

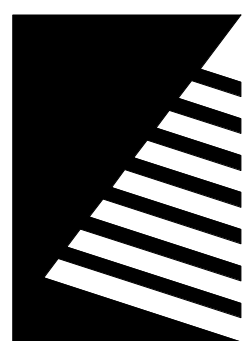

Farnsworth
GROUP

14225 UNIVERSITY AVENUE, SUITE 110
WALKEE, IOWA 50263
(515) 225-3469 / info@f-w.com

www.f-w.com
Engineers | Architects | Surveyors | Scientists

RIPPE ASSOCIATES
FOODSERVICE DESIGN + CONSULTING

kpff

IMEG

Bishop Engineering

ISSUE:
DATE: DESCRIPTION:

BID SET

PROJECT:
STATE OF IOWA DEPARTMENT
OF CORRECTIONS

CLARINDA
CORRECTIONAL
FACILITY - KITCHEN &
LAUNDRY ADDITION

2000 N 16TH ST, CLARINDA, IA
51632

DATE: 02/09/2024

DESIGNED: EG/TP

DRAWN: MM/BB


REVIEWED: EG/RB

SHEET TITLE:
FOODSERVICE
EQUIPMENT
ELEVATIONS AND
SECTIONS

SHEET NUMBER:

FS203

PROJECT NO.: 0240202.00
RFB922300-02

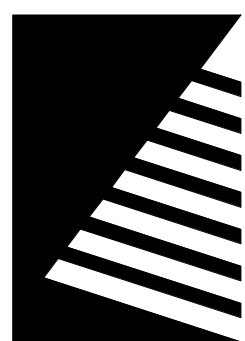

Farnsworth
GROUP

14225 UNIVERSITY AVENUE, SUITE 110
WALKEE, IOWA 50263
(515) 225-3469 / info@f-w.com

www.f-w.com
Engineers | Architects | Surveyors | Scientists

RIPE ASSOCIATES
FOODSERVICE DESIGN + CONSULTING

kpff

IMEG

Bishop Engineering

ISSUE:
DATE: DESCRIPTION:

BID SET

PROJECT:
STATE OF IOWA DEPARTMENT
OF CORRECTIONS

CLARINDA
CORRECTIONAL
FACILITY - KITCHEN &
LAUNDRY ADDITION

2000 N 16TH ST, CLARINDA, IA
51632

DATE: 02/09/2024

DESIGNED: EG/TP

DRAWN: MM/BB

REVIEWED: EG/RB

SHEET TITLE:

FOODSERVICE
EQUIPMENT SPECIAL
CONDITIONS DETAILS
AND PLAN - AREA 1

SHEET NUMBER:

FS300

PROJECT NO.: 0240202.00
RFB922300-02

NOTE:
DIMENSIONS SHOWN ARE
OUTSIDE DIMENSIONS OF
RECESSED CABINET - ALLOW
TOLERANCE TO SLIDE
CABINET INTO WALL CAVITY

OFFSET VALVE CABINET AS
SHOWN TO ALLOW
PLUMBING SUPPLY LINE TO
LINE UP WITH INLET IN EYE
WASH CABINET

PLYWOOD OR 12 GA.
WALL BACKING NOT IN
SECTION 114000

MINIMUM INSIDE
WALL DEPTH TO
HOUSE CABINET

NOTE:
ROUGH-IN WIDTH FOR
CABINET TO BE 14 1/4"

STUD @ TOP &
BOTTOM FOR
SUPPORT

CONDENSING UNITS LOCATED ON ROOF -
VERIFY EXACT LOCATION WITH ARCHITECT

* FSEC TO COORDINATE
THIS DIMENSION

WEATHER PROOFING OF
ROOF OPENINGS FOR
REFRIGERATION/ELECTRICAL
LINES NOT IN SECTION 114000

TREATED WOOD BLOCKING,
SIZE AS REQUIRED, NOT IN
SECTION 114000

FLASHING AND ROOFING PER
ARCHITECTURAL DETAILS

CANT STRIP NOT IN
SECTION 114000

ROOF RAIL PLAN VIEW

ROOF RAIL SECTION

NOTES:
1. ROOF RAILS TO SUPPORT CONDENSING UNIT NOT IN SECTION 114000
2. SLEEVES, WEATHERPROOF SHROUDS AND SEALING OF ALL OPENINGS IN ROOF, CEILINGS AND
WALLS TO BE IN ACCORDANCE WITH LOCAL FIRE AND BUILDING CODES NOT IN SECTION 114000
3. TRADE CONTRACTORS TO COORDINATE ALL DIMENSIONS WITH FSEC SINCE SIZE, LOCATION
AND QUANTITIES OF CURBS WILL VARY

* FSEC TO COORDINATE
THIS DIMENSION

S/S'T FLASHING NOT IN 114000

ROOFING MEMBRANE
NOT IN 114000

ROOF DECK NOT IN 114000

FINISHED FLOOR, COORDINATE THICKNESS OF
FINISHED FLOOR WITH TRADE CONTRACTORS SO
THAT TOP OF FLOOR GRATE DRAIN IS FLUSH WITH
FINISHED FLOOR

TROUGH SIZE

3"

1 1/2"

3"

4"

3 1/4"

5"

3"

1 1/2"

3"

4"

3"

4"

NOTE:
FLOOR TROUGHS BY MECHANICAL TRADES
LOCATED IN THE FOODSERVICE AREAS
SHOULD BE CONSTRUCTED IDENTICALLY.

SPECIAL CONDITIONS LEGEND

WALL BACKING

CHANNEL BASE

DEPRESSED FLOOR (SEE DETAIL)

DEPRESSED FLOOR WITH IN FLOOR HEAT (SEE DETAIL)

C.G. 4'-0" HIGH CORNER GUARD (NOT BY FSEC)

K.P. KICKPLATE (NOT BY FSEC)

FSEC FOODSERVICE EQUIPMENT CONTRACTOR

NOTE:

1. DIMENSIONS SHOWN ARE APPROXIMATE. FSEC TO COORDINATE AND
VERIFY ALL DIMENSIONS IN THE FIELD WITH APPROPRIATE TRADES
PRIOR TO CONSTRUCTION.

2. THE WALK-IN REFRIGERATOR/FREEZER CONDENSING UNITS ARE
LOCATED APPROXIMATELY WHERE SHOWN ON PLAN. VERIFY THE EXACT
LOCATION WITH THE ARCHITECT/ENGINEER. ROOF CURBS/CONCRETE
PADS FOR CONDENSING UNITS & SLEEVED, SEALED PENETRATIONS IN
ROOFS, FLOORS, CEILINGS & WALLS FOR CONDENSING UNIT
REFRIGERATION & UTILITY LINES ARE NOT BY THE FSEC.

3. THE FSEC WILL FURNISH AND INSTALL THE REFRIGERATION LINES
BETWEEN THE CONDENSING UNITS AND SPECIFIED REFRIGERATED
EQUIPMENT. IT IS THE FSEC'S RESPONSIBILITY TO COORDINATE THE
EXACT ROUTE TO EACH ITEM WITH THE APPROPRIATE TRADES.

4 RECESSED EYE/FACE WASH - GUARDIAN
1" = 1'-0"


5 ROOF RAIL
1" = 1'-0"

6 FLOOR TROUGH
3" = 1'-0"

3 RECESSED HOSE REEL CABINET
1" = 1'-0"

2 FOODSERVICE SPECIAL CONDITIONS PLAN - ROOF
1/4" = 1'-0"

1 FOODSERVICE SPECIAL CONDITIONS PLAN - AREA 1
1/4" = 1'-0"

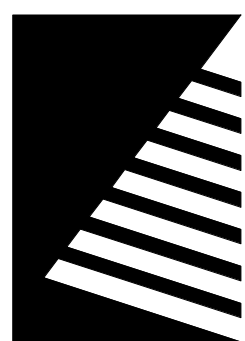

Farnsworth
GROUP

14225 UNIVERSITY AVENUE, SUITE 110
WALKEE, IOWA 50263
(515) 225-3469 / info@f-w.com

www.f-w.com
Engineers | Architects | Surveyors | Scientists

RIPPE ASSOCIATES
FOODSERVICE DESIGN + CONSULTING

kpff

IMEG

Bishop Engineering

ISSUE:
DATE: DESCRIPTION:

BID SET

PROJECT:
STATE OF IOWA DEPARTMENT
OF CORRECTIONS

CLARINDA
CORRECTIONAL
FACILITY - KITCHEN &
LAUNDRY ADDITION

2000 N 16TH ST, CLARINDA, IA
51632

DATE: 02/09/2024

DESIGNED: EG/TP

DRAWN: MM/BB

REVIEWED: EG/RB


SHEET TITLE:

FOODSERVICE
EQUIPMENT SPECIAL
CONDITIONS PLAN -
AREA 2

SHEET NUMBER:

FS301

PROJECT NO.: 0240202.00
RFB922300-02

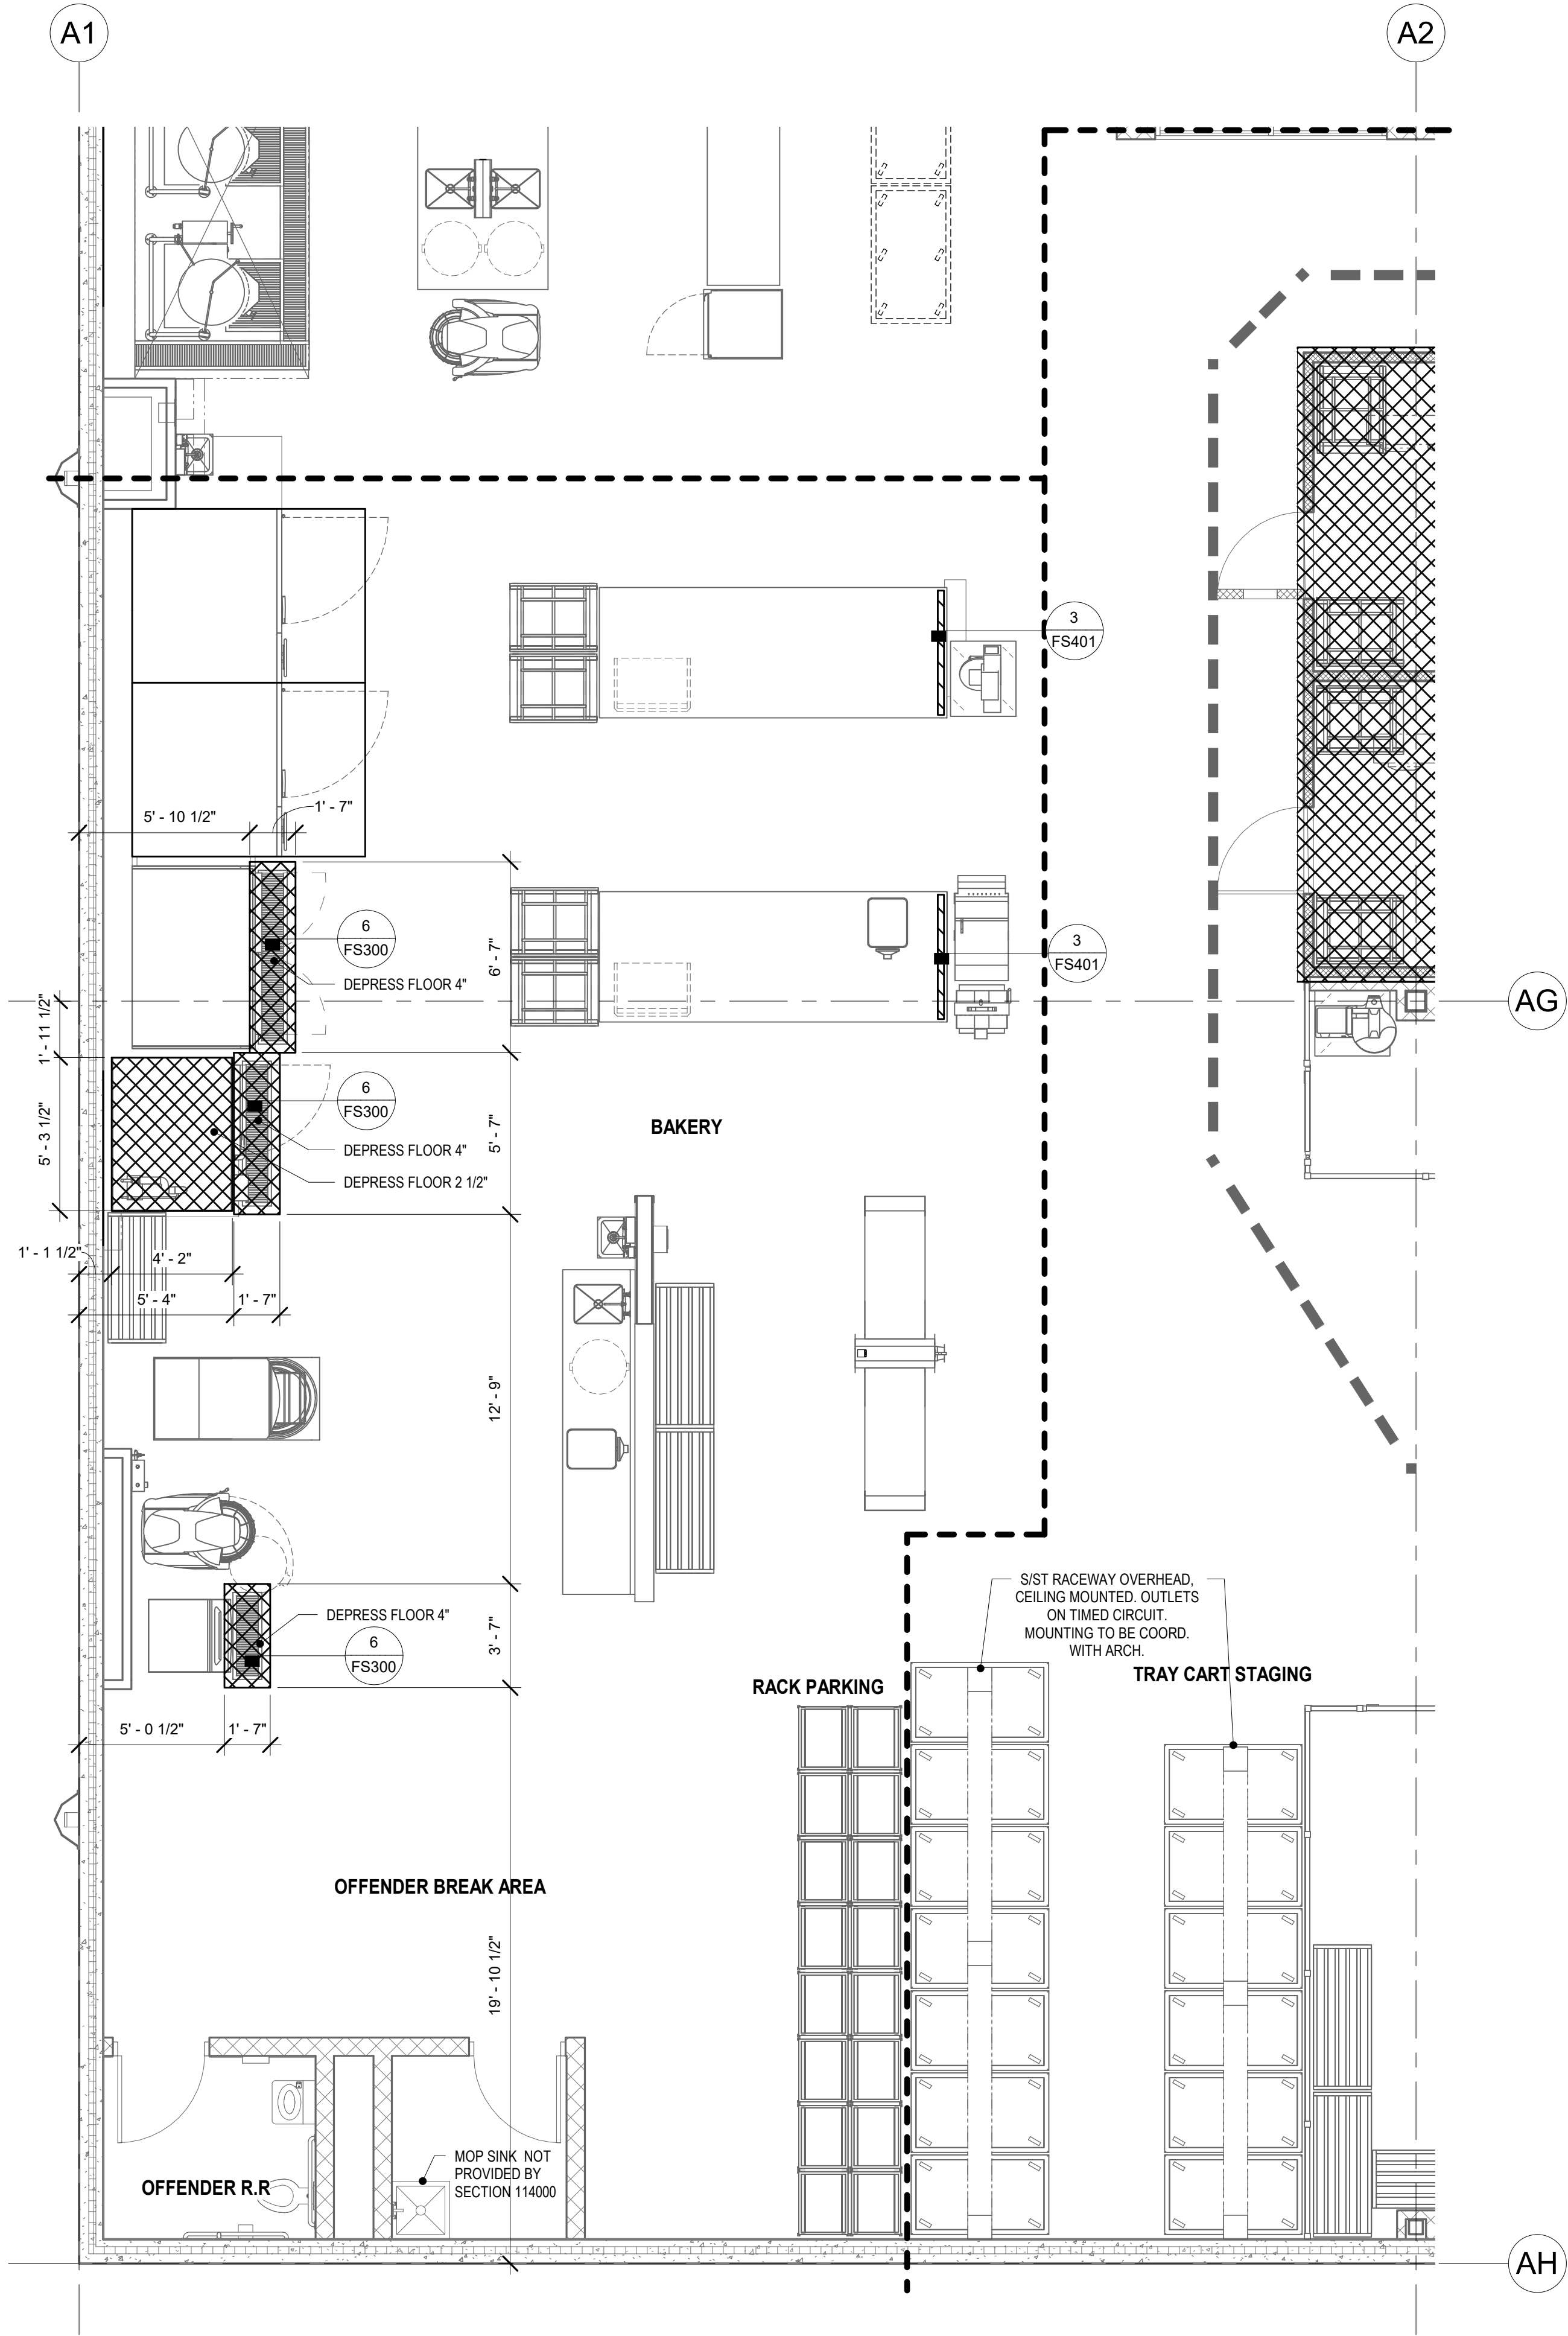


SPECIAL CONDITIONS LEGEND

	WALL BACKING
	CHANNEL BASE
	DEPRESSED FLOOR (SEE DETAIL)
	DEPRESSED FLOOR WITH IN FLOOR HEAT (SEE DETAIL)

C.G.	4'-0\"/>
K.P.	KICKPLATE (NOT BY FSEC)
FSEC	FOODSERVICE EQUIPMENT CONTRACTOR

- NOTE:
- DIMENSIONS SHOWN ARE APPROXIMATE. FSEC TO COORDINATE AND VERIFY ALL DIMENSIONS IN THE FIELD WITH APPROPRIATE TRADES PRIOR TO CONSTRUCTION.
 - THE WALK-IN REFRIGERATOR/FREEZER CONDENSING UNITS ARE LOCATED APPROXIMATELY WHERE SHOWN ON PLAN. VERIFY THE EXACT LOCATION WITH THE ARCHITECT/ENGINEER. ROOF CURBS/CONCRETE PADS FOR CONDENSING UNITS & SLEEVES, SEALED PENETRATIONS IN ROOFS, FLOORS/ CEILINGS & WALLS FOR CONDENSING UNIT REFRIGERATION & UTILITY LINES ARE NOT BY THE FSEC.
 - THE FSEC WILL FURNISH AND INSTALL THE REFRIGERATION LINES BETWEEN THE CONDENSING UNITS AND SPECIFIED REFRIGERATED EQUIPMENT. IT IS THE FSEC'S RESPONSIBILITY TO COORDINATE THE EXACT ROUTE TO EACH ITEM WITH THE APPROPRIATE TRADES.

1 FOODSERVICE SPECIAL CONDITIONS PLAN - AREA 2
1/4" = 1'-0"

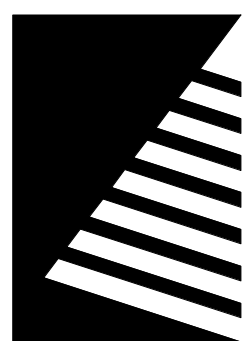

Farnsworth
GROUP

14225 UNIVERSITY AVENUE, SUITE 110
WALKEE, IOWA 50263
(515) 225-3469 / info@f-w.com

www.f-w.com
Engineers | Architects | Surveyors | Scientists

RIPPE ASSOCIATES
FOODSERVICE DESIGN + CONSULTING

kpff

IMEG

Bishop Engineering

ISSUE:
DATE: DESCRIPTION:

BID SET

PROJECT:
STATE OF IOWA DEPARTMENT
OF CORRECTIONS

CLARINDA
CORRECTIONAL
FACILITY - KITCHEN &
LAUNDRY ADDITION

2000 N 16TH ST, CLARINDA, IA
51632

DATE: 02/09/2024

DESIGNED: EG/TP

DRAWN: MM/BB

REVIEWED: EG/RB


SHEET TITLE:

FOODSERVICE
EQUIPMENT SPECIAL
CONDITIONS PLAN -
AREA 3

SHEET NUMBER:

FS302





PROJECT NO.: 0240202.00
RFB922300-02

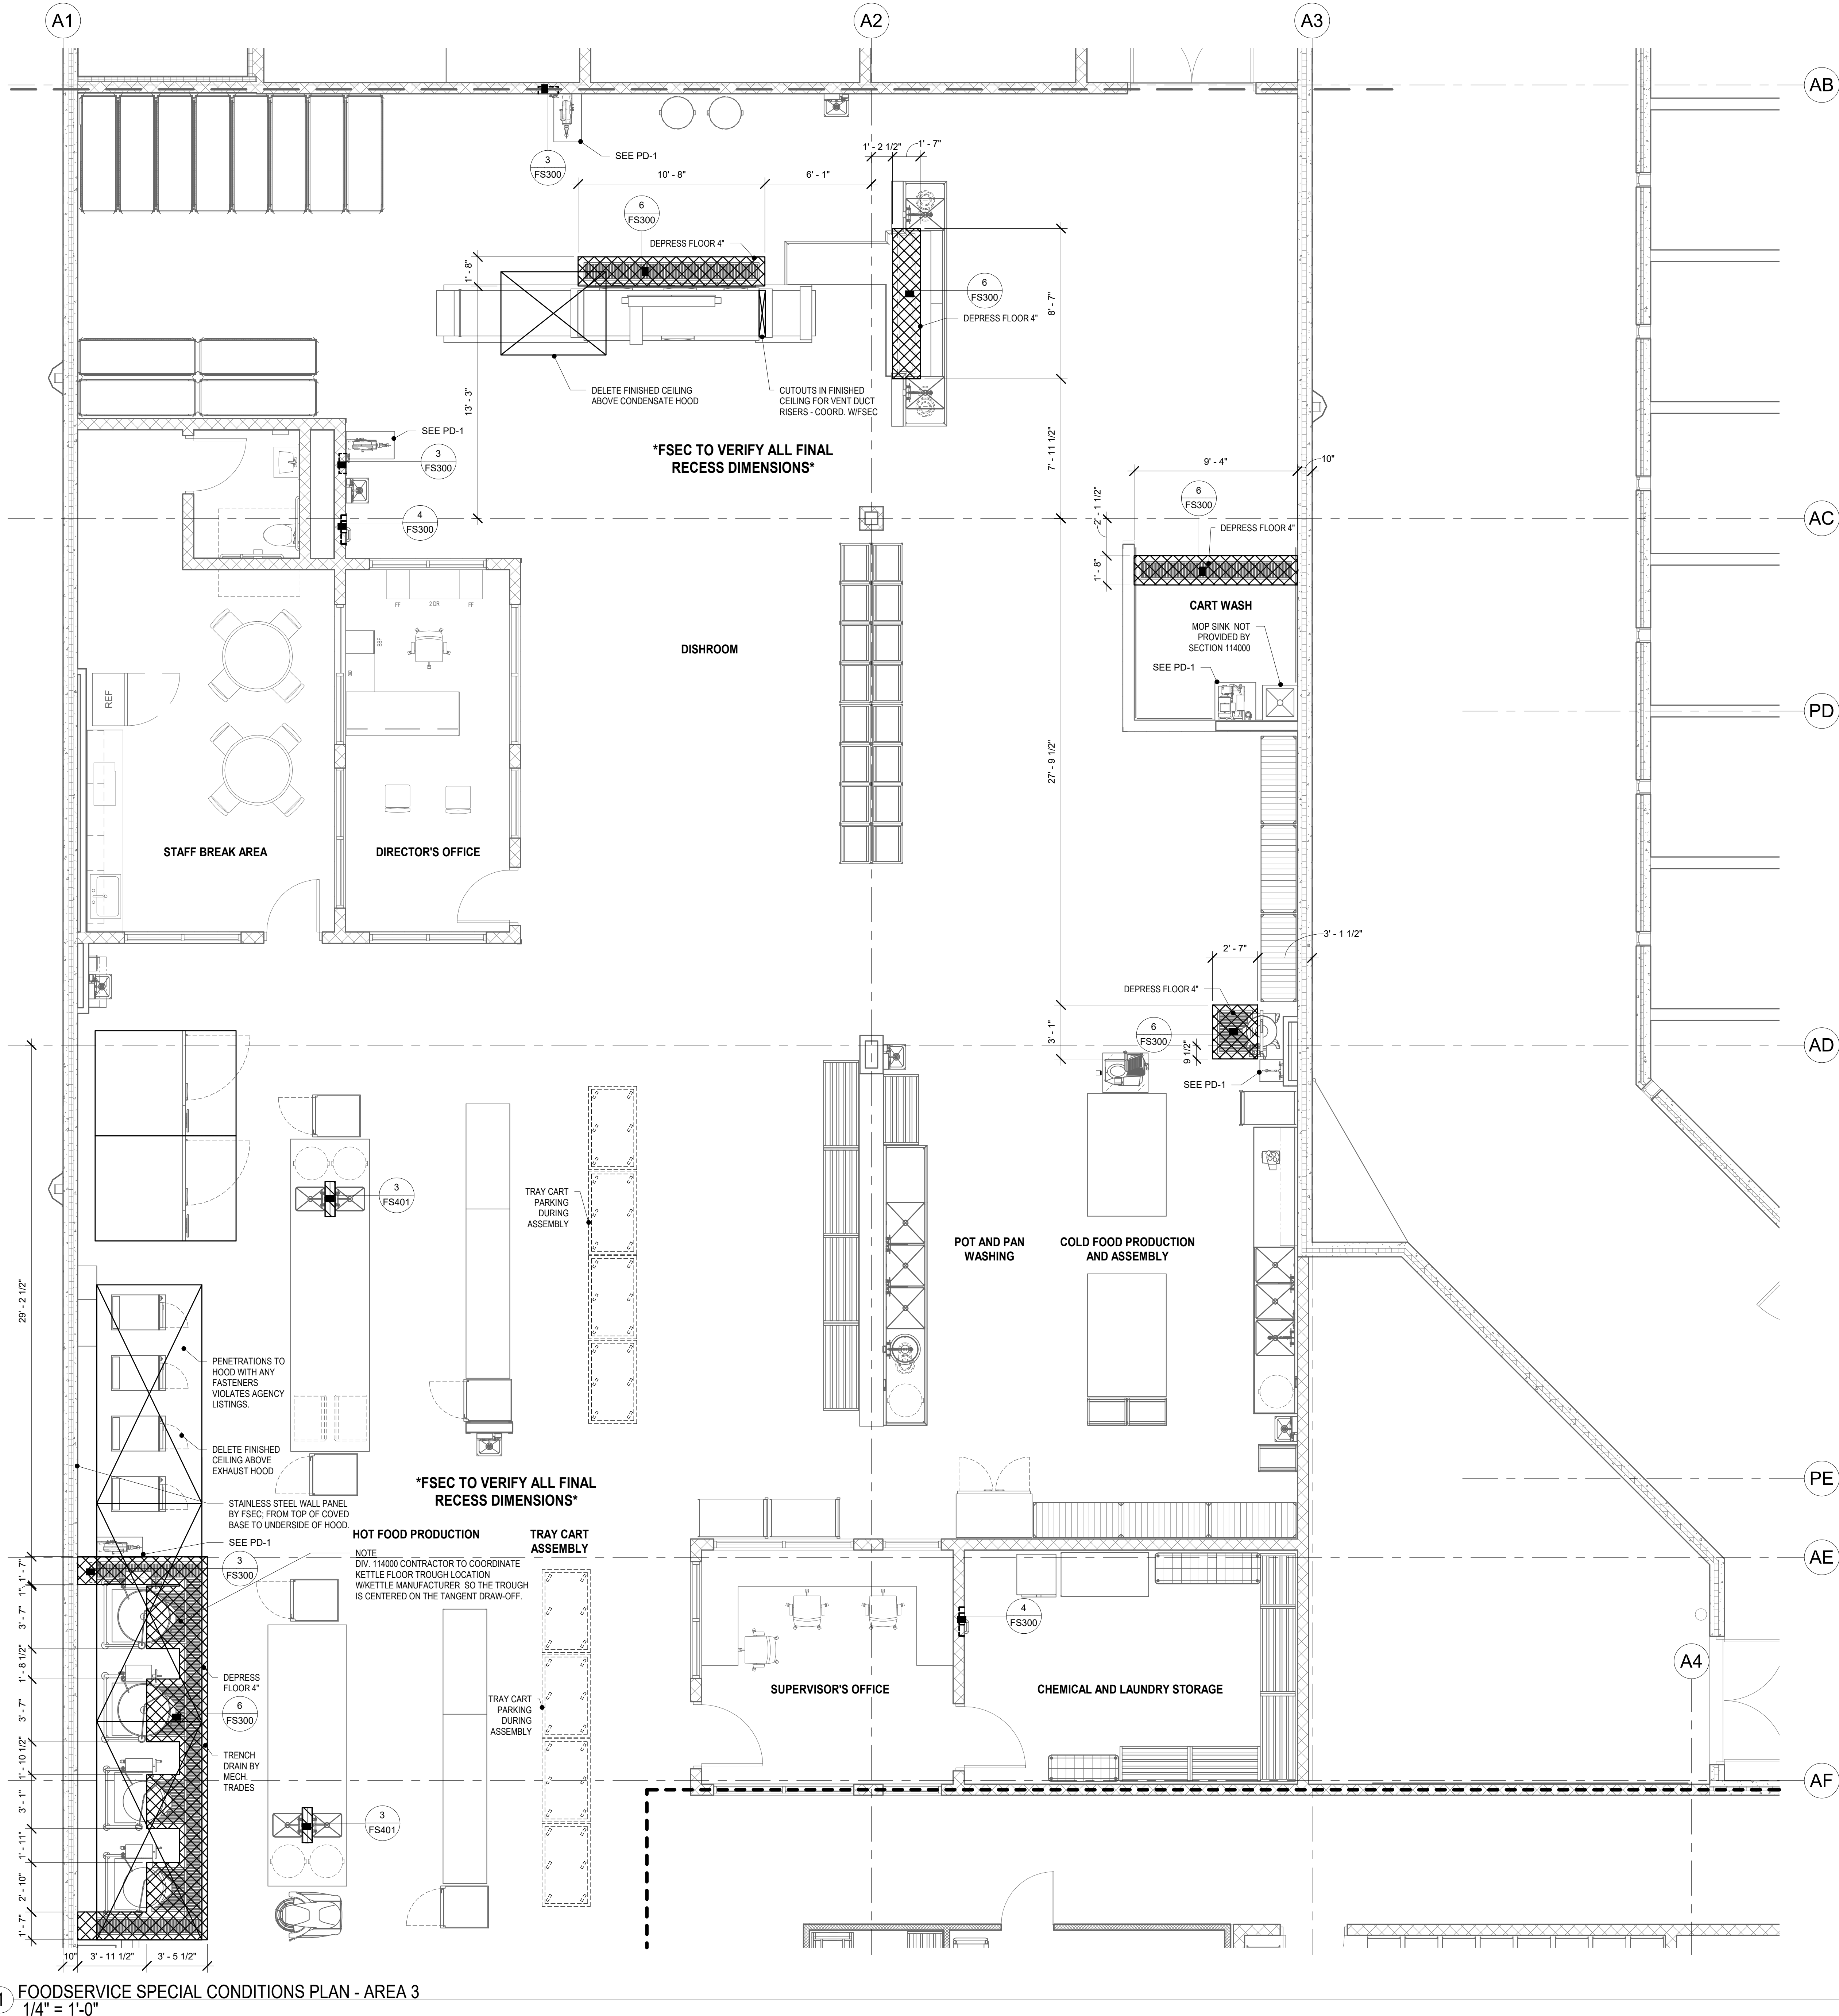


SPECIAL CONDITIONS LEGEND	
	WALL BACKING
	CHANNEL BASE
	DEPRESSED FLOOR (SEE DETAIL)
	DEPRESSED FLOOR WITH IN FLOOR HEAT (SEE DETAIL)
C.G.	4'-0" HIGH CORNER GUARD (NOT BY FSEC)
K.P.	KICKPLATE (NOT BY FSEC)
FSEC	FOODSERVICE EQUIPMENT CONTRACTOR

- NOTE:
- DIMENSIONS SHOWN ARE APPROXIMATE. FSEC TO COORDINATE AND VERIFY ALL DIMENSIONS IN THE FIELD WITH APPROPRIATE TRADES PRIOR TO CONSTRUCTION.
 - THE WALK-IN REFRIGERATOR/FREEZER CONDENSING UNITS ARE LOCATED APPROXIMATELY WHERE SHOWN ON PLAN. VERIFY THE EXACT LOCATION WITH THE ARCHITECT/ENGINEER. ROOF CURBS/CONCRETE PADS FOR CONDENSING UNITS & SLEEVED, SEALED PENETRATIONS IN ROOFS, FLOORS, CEILINGS & WALLS FOR CONDENSING UNIT REFRIGERATION & UTILITY LINES ARE NOT BY THE FSEC.
 - THE FSEC WILL FURNISH AND INSTALL THE REFRIGERATION LINES BETWEEN THE CONDENSING UNITS AND SPECIFIED REFRIGERATED EQUIPMENT. IT IS THE FSEC'S RESPONSIBILITY TO COORDINATE THE EXACT ROUTE TO EACH ITEM WITH THE APPROPRIATE TRADES.

 1 FOODSERVICE SPECIAL CONDITIONS PLAN - AREA 3
1/4" = 1'-0"

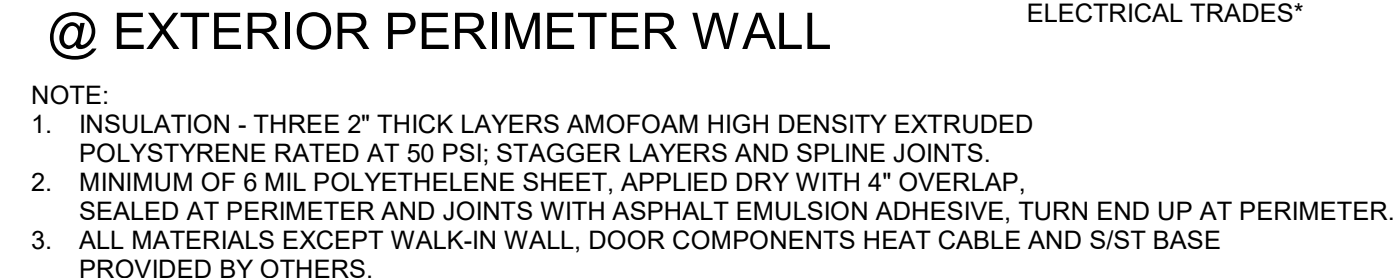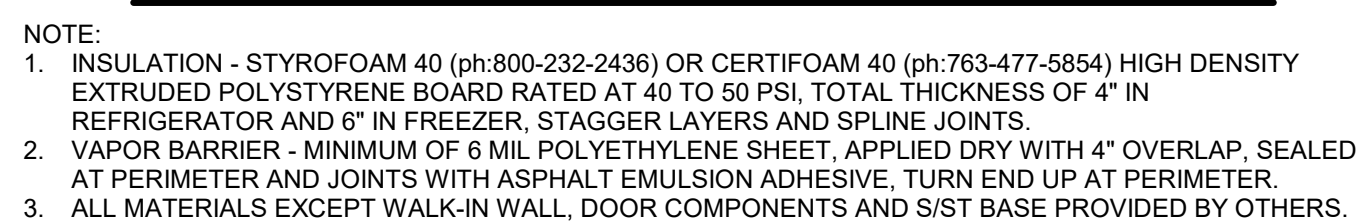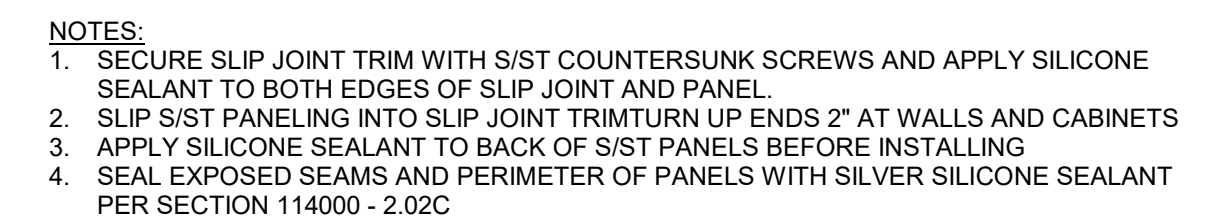

RFB922300-02

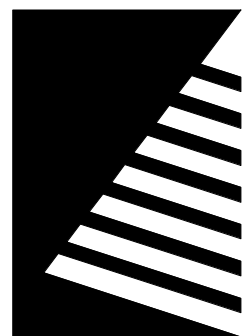

Farnsworth
GROUP

14225 UNIVERSITY AVENUE, SUITE 110
WALKEE, IOWA 50263
(515) 225-3469 / info@f-w.com

www.f-w.com
Engineers | Architects | Surveyors | Scientists

RIPPE ASSOCIATES
FOODSERVICE DESIGN + CONSULTING

kpff

IMEG

Bishop Engineering

ISSUE:
DATE: DESCRIPTION:

BID SET

PROJECT:
STATE OF IOWA DEPARTMENT
OF CORRECTIONS

CLARINDA
CORRECTIONAL
FACILITY - KITCHEN &
LAUNDRY ADDITION

2000 N 16TH ST, CLARINDA, IA
51632


DATE: 02/09/2024
DESIGNED: EG/TP
DRAWN: MM
REVIEWED: EG/RB

SHEET TITLE:
FOODSERVICE
EQUIPMENT
STANDARD DETAILS

SHEET NUMBER:

FS402

PROJECT NO.: 0240202.00
RFB922300-02

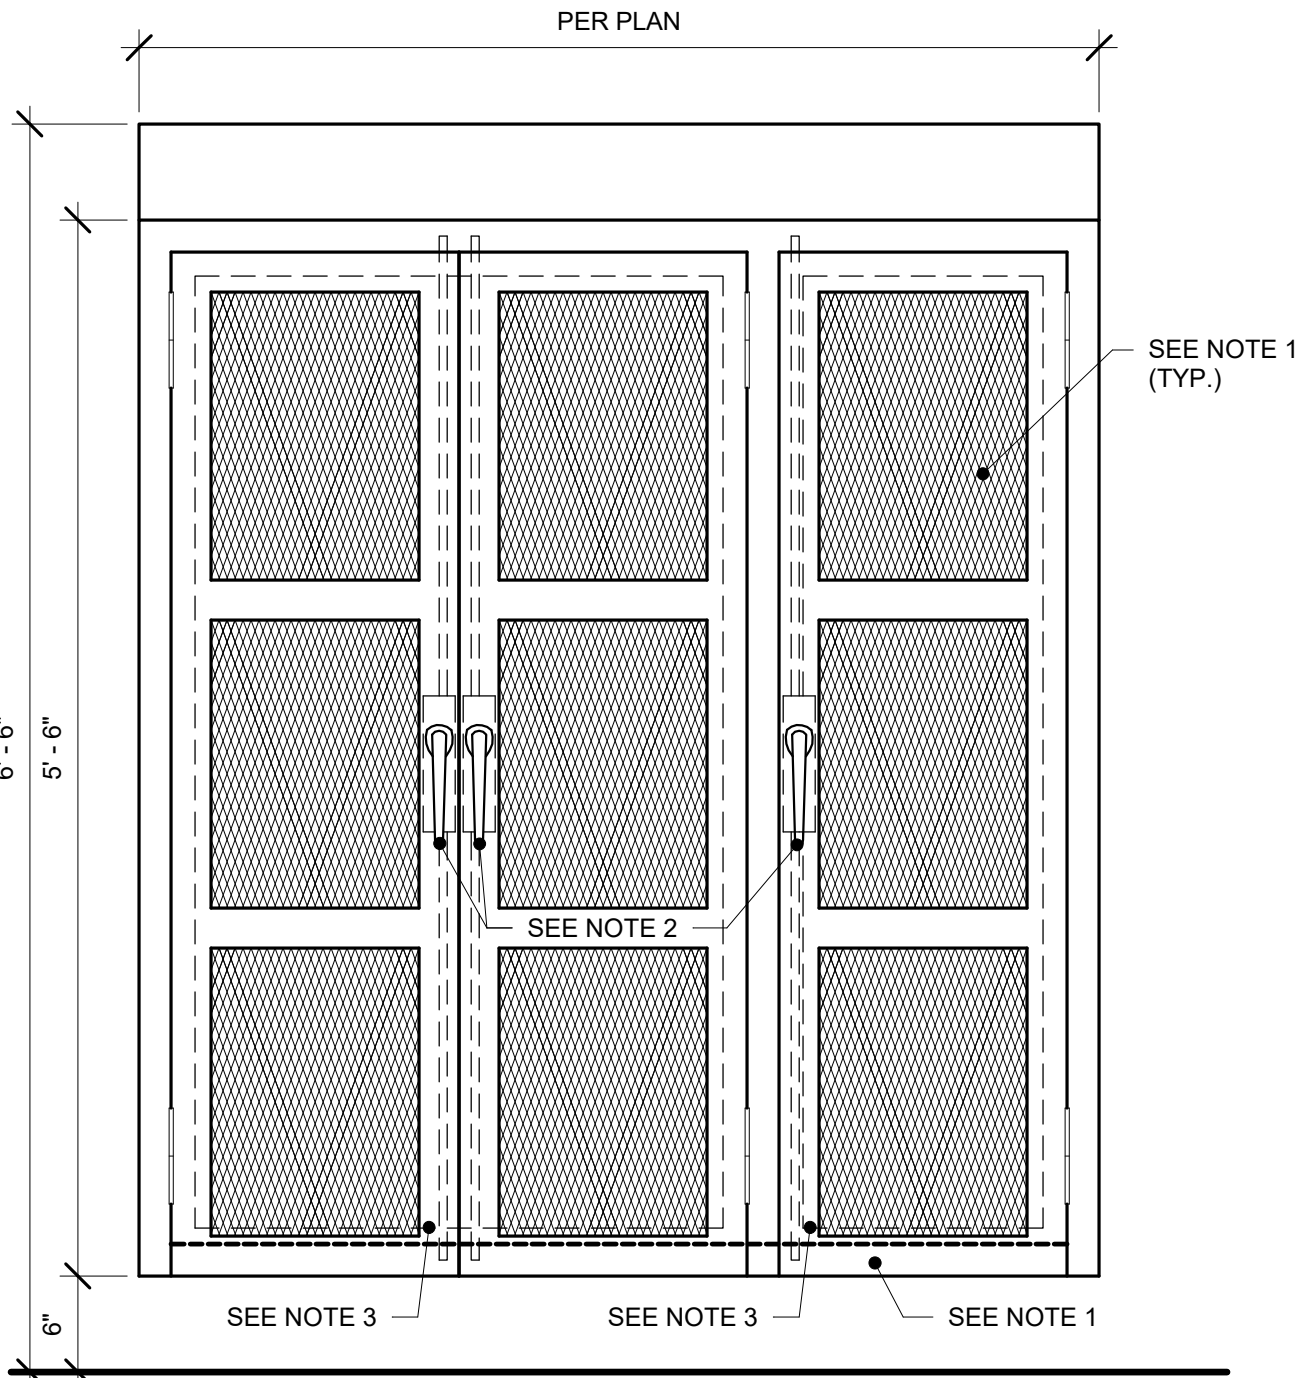

- NOTES:
1. CABINET CONSTRUCTION SIMILAR TO SD-26 DOORS SIMILAR TO SD-17 BUT WITH HEAVY-DUTY 5/16" EXPANDED MESH FRONTS AS SHOWN
 2. McMASTER-CARR LATCHES W/PADLOCK HASP - PROVIDE PADLOCKS KEYED TO MATCH
 3. SHADOW BOARD W/HANGER PINS FOR TOOL & BAKERY EQUIP. STORAGE - VERIFY EXACT REQUIREMENTS WITH OWNER

PD-2 SHADOW BOX SECURITY CABINET

FOODSERVICE EQUIPMENT ELECTRICAL SCHEDULE										
ITEM #	DESCRIPTION	VOLTS	PHASE	AMPS	WATTS	HP	CONN. TYPE	RI HEIGHT	REMARKS	
7A	WALK-IN REFRIGERATOR/FREEZER COMPLEX	120 V	1	20.0 A			DIRECT	114"	DFA / NOTE W / SEE DETAIL SD-191	
7B	FREEZER FLOOR HEAT	A 208 V	1				DIRECT	48"	DFA / COOK'S ISSUANCE FLOOR HEAT / NOTE W / SEE DETAIL SD-188 / 30 AMP BREAKER / (1) CIRCUIT	
7B	FREEZER FLOOR HEAT	B 208 V	1				DIRECT	48"	DFA / MAIN FREEZER FLOOR HEAT / NOTE W / SEE DETAIL SD-188 / 30 AMP BREAKER / (3) CIRCUITS ON ONE CONTACTOR	
8A	RACKED REFRIGERATION SYSTEM	A 208 V	3	138.9 A			DIRECT	0"	NOTE D & W / MAX FUSE SIZE 175.0 AMPS / MIN CIRCUIT AMPACITY 148.4 AMPS	
8B	REFRIGERATION SYSTEM COIL - PRODUCE REFRIGERATOR	B 120 V	1	1.8 A			DIRECT	96"	NOTE W / (2) COILS @ 1.8 AMPS EACH	
8C	REFRIGERATION SYSTEM COIL - MEAT & DAIRY REFRIGERATOR	C 120 V	1	1.8 A			DIRECT	96"	NOTE W / (2) COILS @ 1.8 AMPS EACH	
8D	REFRIGERATION SYSTEM COIL - TEMPERING REFRIGERATOR	D 208 V	1	13.7 A			DIRECT	96"	NOTE W	
8E	FREEZER SYSTEM COIL - MAIN FREEZER	E 208 V	1	22.8 A			DIRECT	96"	NOTE W / (2) COILS @ 22.8 AMPS EACH	
8F	FREEZER SYSTEM COIL - BAKERY FREEZER	F 208 V	1	9.1 A			DIRECT	96"	NOTE W	
8G	REFRIGERATION SYSTEM COIL - BAKERY REFRIGERATOR	G 120 V	1	1.8 A			DIRECT	96"	NOTE W	
11	HEATED AIR CURTAIN	A 480 V	3	22.0 A		1/2, 1/2	DIRECT	96"	PROVIDE 30 AMP CIRCUIT	
11	HEATED AIR CURTAIN	B 480 V	3	28.3 A		1/2, 1/2	DIRECT	96"	PROVIDE 35 AMP CIRCUIT	
12	AIR CURTAIN	120 V	1	3.4 A		1/5, 1/5	DIRECT	96"	PROVIDE 15 AMP CIRCUIT	
13	MANUAL SLIDING DOOR (FRZ)	120 V	1	3.0 A			DIRECT	86"	ELECTRICAL TRADES TO PROVIDE AND INSTALL FROSTOP DISCONNECT KEYSWITCH / FINAL CONNECTIONS BY ELECTRICAL TRADES	
26	BENCH SCALE	120 V	1				RECEPT.	18"	AC ADAPTER W/INTERNAL BATTERY	
34	FOOD CUTTER	120 V	1	13.0 A		1	RECEPT.	60"	NOTE X / INTERCHANGEABLE PLUG IN LOCATION W/ITEM #114 / VFY. UTILITIES W/OWNER	
40	MOBILE HOT/COLD TRANSPORT CART	120 V	1				RECEPT.	0"	NOTE X / VFY. UTILITIES W/OWNER / (13) CIRCUITS SERVICED THRU #41A & B	
41A	UTILITY DISTRIBUTION SYSTEM	120 V	1				DIRECT	126"	(6) 20.0 AMP CIRCUITS TO SERVICE (6) #40 / FSEC TO PREWIRE RECEPTACLES IN UDS / FINAL CONNECTIONS BY ELECTRICAL TRADES / SEE SHEET FSE101	
41B	UTILITY DISTRIBUTION SYSTEM	120 V	1				DIRECT	126"	(7) 20.0 AMP CIRCUITS TO SERVICE (7) #40 / FSEC TO PREWIRE RECEPTACLES IN UDS / FINAL CONNECTIONS BY ELECTRICAL TRADES / SEE SHEET FSE102	
62	WORKCOUNTER W/SINK	120 V	1				DIRECT	10"	NOTE A / STUB UP THRU ADJACENT WALL / (3) 20.0 AMP CIRCUITS TO SERVICE (1) #71 & (2) CONV. DRS	
63	140 QUART MIXER	208 V	3	14.8 A		5	DIRECT	60"	ADD ALTERNATE / ELECTRICAL TRADES TO ROUGH-IN AND CAP AS NEEDED	
64	WATER METER W/TEMPERATURE RANGE	120 V	1	5.0 A			RECEPT.	54"	ADD ALTERNATE / ELECTRICAL TRADES TO ROUGH-IN AND CAP AS NEEDED	
67	SPIRAL MIXER	208 V	3	32.0 A		15	DIRECT	48"	ADD ALTERNATE / ELECTRICAL TRADES TO ROUGH-IN AND CAP AS NEEDED	
69	SHEETER	120 V	1	8.3 A			RECEPT.	60"	ADD ALTERNATE / ELECTRICAL TRADES TO ROUGH-IN AND CAP AS NEEDED	
71	DIGITAL BENCH SCALE	A 120 V	1				DUPLEX	0"	AC ADAPTER W/INTERNAL BATTERY	
71	DIGITAL BENCH SCALE	B 120 V	1				DUPLEX	0"	SERVICED THRU #77A / ADD ALTERNATE / ELECTRICAL TRADES TO ROUGH-IN AND CAP AS NEEDED / AC ADAPTER W/INTERNAL BATTERY	
74	ROLL-IN PROOFER, 2 DOUBLE RACKS	208 V	3		5000 W		DIRECT	90"	NEUTRAL WIRE CIRCUITRY NEEDED TO PROVIDE 120V CONTROL / ADD ALTERNATE / ELECTRICAL TRADES TO ROUGH IN AND CAP AS NEEDED	
77	BAKERY WORKCOUNTER W/RICHLITE TOP	A 120 V	1				DIRECT	10"	NOTE A / STUB UP THRU CURB / (4) 20.0 AMP CIRCUITS TO SERVICE (2) CONV. DRS & #71B & 79	
77	BAKERY WORKCOUNTER W/RICHLITE TOP	AA 120 V	1				DIRECT	10"	NOTE A / STUB UP THRU CURB / (4) 20.0 AMP CIRCUITS TO SERVICE (3) CONV. DRS & (1) #83	
77	BAKERY WORKCOUNTER W/RICHLITE TOP	B 208 V	3				DIRECT	10"	NOTE A / STUB UP THRU CURB / (1) 20.0 AMP CIRCUIT TO SERVICE #78	
78	DIVIDER ROUNDER	208 V	3	10.0 A		3/4	DIRECT	0"	SERVICED THRU #77B / ADD ALTERNATE / ELECTRICAL TRADES TO ROUGH-IN AND CAP AS NEEDED	
79	BREAD SLICER	120 V	1	7.0 A		1/2	RECEPT.	0"	SERVICED THRU #77A / ADD ALTERNATE / ELECTRICAL TRADES TO ROUGH-IN AND CAP AS NEEDED	
83	BUN SLICER	120 V	1	6.8 A	816 W	1/3	RECEPT.	0"	SERVICED THRU #77AA / ADD ALTERNATE / ELECTRICAL TRADES TO ROUGH-IN AND CAP AS NEEDED	
85	ROLL-IN BLAST CHILLER	A 208 V	3	10.6 A	3400 W		DIRECT	106"		
85	BLAST CHILLER REMOTE CONDENSING UNIT	B 208 V	3	53.3 A	16400 W	9	DIRECT	0"		
87	RACK OVEN, 2-SEC.	120/208 V	3		1800 W		DIRECT	90"	NOTE I, L & X	
89	FIRE PROTECTION SYSTEM	A 120 V	1				DIRECT		NOTE J, K & L / AT CEILING / WIRING FOR CONTROLS / SEE DETAIL / TO SERVE (1) #87	
89	ELECTRIC GAS VALVE	B 120 V	1				DIRECT	120"	DFA, DEDICATED, NON-INTERRUPTED CIRCUIT	
90	FIRE PROTECTION SYSTEM	A 120 V	1				DIRECT		NOTE J, K & L / AT CEILING / WIRING FOR CONTROLS / SEE DETAIL / TO SERVE (1) #87	
90	ELECTRIC GAS VALVE	B 120 V	1				DIRECT	120"	DFA / DEDICATED, NON-INTERRUPTED CIRCUIT	
91	ICE MAKER	208 V	1	4.2 A			RECEPT.	66"		
109	FOOD PROCESSOR	120 V	1	12.0 A		1.5	RECEPT.	52"	NOTE X / VFY UTILITIES W/OWNER	
112	REACH-IN REFRIGERATOR, 2-SEC.	120 V	1	10.7 A		1/3	RECEPT.	84"	NOTE X / VFY UTILITIES W/OWNER	
114	SLICER	120 V	1	6.0 A	720 W	1/2	RECEPT.	60"	NOTE X / INTERCHANGEABLE PLUG IN LOCATION W/ITEM #34 / VFY. UTILITIES W/OWNER	
116	HORIZONTAL CUTTERMIXER	208 V	3	22.0 A		5	RECEPT.	18"	PROVIDE 30 AMP CIRCUIT / ADD ALTERNATE / ELECTRICAL TRADES TO ROUGH IN AND CAP AS NEEDED	
132	STACKED WASHER/DRYER	A 120 V	1			.9	RECEPT.	30"	PROVIDE 15 AMP CIRCUIT	
132	STACKED WASHER/DRYER	B 120 V	1			1/3	RECEPT.	30"	PROVIDE 15 AMP CIRCUIT	
142	MOBILE WARMING CABINET	A 120 V	1	12.0 A	1500 W		RECEPT.	0"	(1) SERVICED THRU #145 A (2) SERVICED THRU #146	
142	MOBILE WARMING CABINET	B 120 V	1	12.0 A	1500 W		RECEPT.	30"		
144	80 QUART MIXER	208 V	3	12.0 A		3	DIRECT	0"	NOTE X / VFY UTILITIES W/OWNER / SERVICED THRU #145 B	
145	WORKCOUNTER W/SINKS	A 120 V	1				DIRECT	10"	NOTE A / STUB UP THRU CURB / (4) 20.0 AMP CIRCUITS TO SERVICE (3) CONV. DRS & (1) #142A	
145	WORKCOUNTER W/SINKS	B 208 V	3				DIRECT	10"	NOTE A / STUB UP THRU CURB / (1) 20.0 AMP CIRCUIT TO SERVICE #144	
146	WORKCOUNTER W/SINKS	120 V	1				DIRECT	10"	NOTE A / STUB UP THRU CURB / (6) 20.0 AMP CIRCUITS TO SERVICE (4) CONV. DRS & (2) #142	
148	EXHAUST HOOD (TYPE I)	A 120 V	1		400 W		DIRECT	108"	DFA / NOTE I / SEE DETAIL	
148	EXHAUST HOOD (TYPE I)	B 120 V	1		400 W		DIRECT	108"	DFA / NOTE I / SEE DETAIL	
148	EXHAUST HOOD (TYPE I)	C 120 V	1		400 W		DIRECT	108"	DFA / NOTE I / SEE DETAIL	
150	UTILITY DISTRIBUTION SYSTEM	120/208 V	3	20.0 A			DIRECT	110"	DFA / NOTE Y	
151	FIRE PROTECTION SYSTEM	A 120 V	1				DIRECT		NOTE J, K & L / AT CEILING / WIRING FOR CONTROLS / SEE DETAIL / TO SERVE #148 A, B & C	
151	ELECTRIC GAS VALVE	B 120 V	1				DIRECT	120"	DFA / DEDICATED, NON-INTERRUPTED CIRCUIT	
153	DEMAND CONTROL VENTILATION SYSTEM	120 V	1	15.0 A			DIRECT	36"	SEE DETAIL / TO SERVICE HOOD #148	
154	60 GALLON KETTLE	120 V	1	10.0 A			RECEPT.	0"	NOTE L / SERVICED THRU #150	
155	80 GALLON KETTLE	120 V	1	10.0 A			RECEPT.	0"	NOTE L / SERVICED THRU #150	
158	STEAMER, 2-SEC.	A 120 V	1	2.0 A			DIRECT	0"	NOTE L & X / SERVICED THRU #150 / FLEXIBLE CONDUIT	
160	STEAMER, 2-SEC.	A 120 V	1	2.0 A			DIRECT	0"	NOTE L & X / SERVICED THRU #150 / FLEXIBLE CONDUIT	
161	STEAMER, 2-SEC.	A 120 V	1	2.0 A			DIRECT	0"	NOTE L / SERVICED THRU #150 / FLEXIBLE CONDUIT	
163	RACK OVEN, 2-SEC.	120/208 V	3		1800 W		DIRECT	90"	NOTE I & L	
169	FIRE PROTECTION SYSTEM	A 120 V	1				DIRECT		NOTE J, K & L / AT CEILING / WIRING FOR CONTROLS / SEE DETAIL / TO SERVE (1) #163	
169	ELECTRIC GAS VALVE	B 120 V	1				DIRECT	120"	DFA / DEDICATED, NON-INTERRUPTED CIRCUIT	
170	FIRE PROTECTION SYSTEM	A 120 V	1				DIRECT		NOTE J, K & L / AT CEILING / WIRING FOR CONTROLS / SEE DETAIL / TO SERVE (1) #163	
170	ELECTRIC GAS VALVE	B 120 V	1				DIRECT	120"	DFA / DEDICATED, NON-INTERRUPTED CIRCUIT	
174	DISPOSER	208 V	3	8.8 A		3	DIRECT	18"	NOTE C / SEE DETAIL	
182	HOSE STATION	120 V	1			2	RECEPT.	84"		
187	DISPOSER	208 V	3	8.8 A		3	DIRECT	18"	NOTE C / SEE DETAIL	
189	FLIGHT-TYPE DISHMACHINE W/DRYER	A 480 V	3	86.3 A			DIRECT	80"	DFA / NOTE I	

GENERAL NOTES - ELECTRICAL

NOTE: GENERAL NOTES REFER TO GENERAL CONDITIONS. ALL CONDITIONS MAY NOT EXIST ON THIS PROJECT.

- THESE DRAWINGS ARE FOR USE BY THE PROJECT ENGINEERS IN PREPARING THEIR DRAWINGS. THESE DRAWINGS ARE INCIDENTAL TO OUR SERVICES AND MUST BE REVIEWED AND APPROVED BY A PROPERLY LICENSED DESIGN PROFESSIONAL BEFORE BEING USED FOR ANY OTHER PURPOSES. RIPPE ASSOCIATES IS NOT LICENSED AS A DESIGN PROFESSIONAL AND DOES NOT HOLD ITSELF OUT AS SUCH.
- SERVICES SHOWN ON THIS PLAN ARE EQUIPMENT REQUIREMENTS FOR FOODSERVICE EQUIPMENT ONLY. LOCATIONS, SIZES AND HEIGHTS ABOVE FINISHED FLOOR ARE APPROXIMATELY AS REQUIRED BY EQUIPMENT TO BE FURNISHED. SINCE MULTIPLE SOURCES FOR THE EQUIPMENT MAY BE SPECIFIED, SLIGHT VARIATIONS IN UTILITY LOADS, CONNECTION SIZES AND NEMA PLUG CONFIGURATIONS CAN OCCUR. DESIGN BUILDING UTILITY SYSTEM ACCORDINGLY AND ADD NOTES TO THE ELECTRICAL CONTRACT DOCUMENTS INDICATING SLIGHT VARIATIONS ARE TO BE INCLUDED IN ELECTRICAL TRADES WORK AT NO ADDITIONAL COST.
- THESE DRAWINGS ARE NOT TO BE USED TO ROUGH-IN AND/OR TO SET SLEEVES BY. SINCE REQUIRED ALLOWANCES MUST BE MADE FOR MULTIPLE EQUIPMENT SOURCES AND FOR VALVES, FITTINGS, DISCONNECTS, ETC. WHICH WILL BE FURNISHED UNDER ELECTRICAL TRADES. FSEC IS RESPONSIBLE FOR PREPARING DIMENSIONED ROUGH-IN AND SLEEVE LOCATION PLANS PER SPECIFICATIONS TO ACCOMMODATE THE EXACT EQUIPMENT BEING PROVIDED.
- ALL 120V DUPLEX RECEPTABLES TO BE MINIMUM 20 AMP. CIRCUIT AND MOUNTED VERTICALLY, UNLESS OTHERWISE NOTED ON PLAN.
- ELECTRICAL TRADES TO PROVIDE ALL NECESSARY DISCONNECT SWITCHES FOR EQUIPMENT INSTALLED AHEAD OF EQUIPMENT CONTROL OR SWITCH.
- THE FSEC IS RESPONSIBLE FOR SETTING THE EQUIPMENT IN PLACE. FINAL CONNECTION FOR THIS EQUIPMENT IS THE RESPONSIBILITY OF THE ELECTRICAL TRADES.
- HOLES IN FOODSERVICE EQUIPMENT FOR ELECTRICAL SERVICES PROVIDED BY FSEC.
- BUILDING POWER PANEL BREAKERS SERVING FOODSERVICE EQUIPMENT SHOULD BE EQUIPPED WITH GROUND FAULT INTERRUPT PROTECTION IN ACCORDANCE WITH NATIONAL ELECTRIC CODE FOLLOWED BY MUNICIPALITY AND/OR LOCAL CODE. DO NOT PROVIDE GROUND FAULT INTERRUPT RECEPTABLES AT THE EQUIPMENT UNLESS RECEPTACLE IS READILY ACCESSIBLE WITHOUT HAVING TO MOVE EQUIPMENT OR EMPLOY A STEP LADDER.
- UTILITY CONNECTIONS SHOWN ARE THOSE REQUIRED TO SERVICE FOOD SERVICE EQUIPMENT ONLY. MECHANICAL TRADES SHOULD VERIFY WITH OWNER WHETHER ADDITIONAL UTILITIES ARE REQUIRED FOR EXISTING, FUTURE OR VENDOR FURNISHED NON-FOODSERVICE EQUIPMENT LOCATED WITHIN THE AREA SHOWN ON THIS PLAN.
- DESIGN INCOMING UTILITY SERVICES TO ACCOMMODATE 100% OF THE LOADS INDICATED; DO NOT APPLY DIVERSITY FACTOR AS ALL EQUIPMENT CAN BE OPERATING SIMULTANEOUSLY DURING PEAK SERVICE PERIODS.

SCHEDULE NOTES - ELECTRICAL

NOTE: SCHEDULE NOTES PERTAIN TO INDIVIDUAL ITEMS AS INDICATED IN THE FOODSERVICE EQUIPMENT ELECTRICAL SCHEDULE.

- A THE FSEC WILL PROVIDE RECEPTABLES IN FABRICATED EQUIPMENT AS REQUIRED AND WILL PREWIRE ELECTRICAL COMPONENTS IN COUNTER TO JUNCTION BOXES IN COUNTER BASE FOR FINAL CONNECTION BY ELECTRICAL TRADES. INTERCONNECTIONS BETWEEN SECTIONS OF FABRICATED COUNTERS BY FSEC.
- C WIRE THRU TIME DELAY RELAY, SOLENOID VALVE AND CONTROL PANEL TO DISPOSER.
- D ALL REFRIGERATION SYSTEMS ARE LOCATED APPROXIMATELY WHERE SHOWN ON THE PLAN UNLESS OTHERWISE NOTED. THE FOLLOWING ITEMS ARE NOT BY THE FSEC: ROOF CURBS/CONCRETE PADS; SLEEVED & SEALED PENETRATIONS IN ROOFS/FLOORS/CEILINGS/WALLS. VERIFY EXACT LOCATON WITH ARCHITECT/ENGINEER.
- I ELECTRICAL TRADES TO WIRE AUTOMATIC CONTROLS OR INTERLOCK DEVICE BETWEEN EQUIPMENT AND EXHAUST FAN SO EXHAUST FAN TURNS ON ONCE EQUIPMENT IS OPERATIONAL.
- J ELECTRICAL TRADES TO INTERWIRE FIRE PROTECTION SYSTEM WITH BUILDING ALARM SYSTEM AND TO MAKE-UP AIR FAN SHUT-OFF.
- K FIRE PROTECTION SYSTEM REQUIRES 24 HOUR. EMERGENCY SEPARATE ELECTRICAL SERVICE. ELECTRICAL TRADES TO INTERWIRE FIRE PROTECTION SYSTEM WITH ELECTRICAL GAS SHUT-OFF VALVE FOR ALL COOKING EQUIPMENT BELOW HOODS. ELECTRICAL TRADES TO ALSO INTERWIRE FIRE PROTECTION SYSTEM WITH BUILDING ALARM SYSTEM.
- L ELECTRICAL TRADES TO INTERWIRE FIRE PROTECTION SYSTEM TO POWER SHUT-OFF DEVICE, SUPPLIED BY ELECTRICAL TRADES, SO THAT POWER TO ALL ELECTRIC COOKING EQUIPMENT AND CONVENIENCE RECEPTABLES BELOW HOODS IS SHUT OFF UPON ACTIVATION OF THE FIRE PROTECTION SYSTEM.
- W INTERCONNECT THIS EQUIPMENT WITH BUILDING EMERGENCY POWER.
- X THIS EQUIPMENT IS EXISTING. MECHANICAL/ELECTRICAL TRADES TO DISCONNECT, FSEC TO RELOCATE AND SET IN PLACE. FINAL RE-CONNECTION BY MECHANICAL/ELECTRICAL TRADES. MECHANICAL/ELECTRICAL TRADES TO COORDINATE UTILITY REQUIREMENTS WITH FSEC PRIOR TO ROUGH-IN.
- Y WHEN A UTILITY DISTRIBUTION SYSTEM IS SPECIFIED, ELECTRICAL TRADES SHALL:
1. INSTALL MAIN SERVICE FEEDERS AND OVERCURRENT PROTECTION DEVICES; INSTALL ELECTRICAL CONDUIT AND WIRING FROM ROUGH-IN LOCATION TO RACEWAY TERMINALS IN VERTICAL CHASE BY SYSTEM MANUFACTURER.
2. CONNECT UL LISTED POWER SUPPLY CORDS AND PREWIRED FLEXIBLE CONDUIT SET, ALL PROVIDED BY SYSTEM MANUFACTURER WITH APPROPRIATE EQUIPMENT ITEMS.
3. INTERCONNECT FIRE PROTECTION SYSTEM MICROSWITCH OR RELAY TO POWER SHUT-OFF DEVICE FOR MAIN SERVICE FEEDERS.
4. PROVIDE 24 VOLT POWER SUPPLY CIRCUIT FROM CONTROL BOX IN RISER TO AUTOMATIC STEAM SHUT-OFF VALVE. SEE DETAIL.
5. SPECIAL NOTE - NO MODIFICATION OF ANY MANUFACTURED RACEWAY SHALL BE UNDERTAKEN BY ANY ENTITY WITHOUT THE EXPRESS, WRITTEN APPROVAL AND/OR SUPERVISION OF THE RACEWAY MANUFACTURER.
- THE FSEC WILL:
1. INTERCONNECT FIELD JOINTS BY BOLTING BUSBAR AND/OR WIRING TOGETHER, ALL FITTINGS, BOLTS, ETC. SHALL BE PRE-FITTED AND FURNISHED BY THE SYSTEM MANUFACTURER. THE CONTROL WIRE FIELD JOINT WILL BE PROVIDED WITH A QUICK-DISCONNECT DEVICE.
2. INSPECT FOR LOOSE CONNECTIONS CAUSED BY SHIPPING AND TIGHTEN AS REQUIRED.

BID SET

PROJECT:

STATE OF IOWA DEPARTMENT OF CORRECTIONS

CLARINDA CORRECTIONAL FACILITY - KITCHEN & LAUNDRY ADDITION

2000 N 16TH ST, CLARINDA, IA 51632

DATE: 02/09/2024

DESIGNED: EG/TP

DRAWN: MM

REVIEWED: EG/RB

SHEET TITLE:


FOODSERVICE EQUIPMENT ELECTRICAL SCHEDULE & DETAILS

SHEET NUMBER:

FSE100

PROJECT NO.: 0240202.00

RF8922300-02

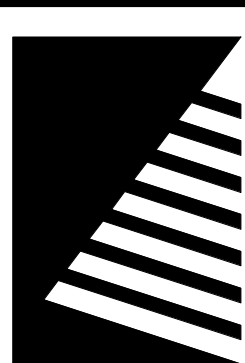

Farnsworth
GROUP

14225 UNIVERSITY AVENUE, SUITE 110
WALKEE, IOWA 50263
(515) 225-3469 / info@f-w.com

www.f-w.com
Engineers | Architects | Surveyors | Scientists


RIPPE ASSOCIATES
FOODSERVICE DESIGN + CONSULTING

kpf

IMEG

Bishop Engineering

ISSUE:
DATE: DESCRIPTION:

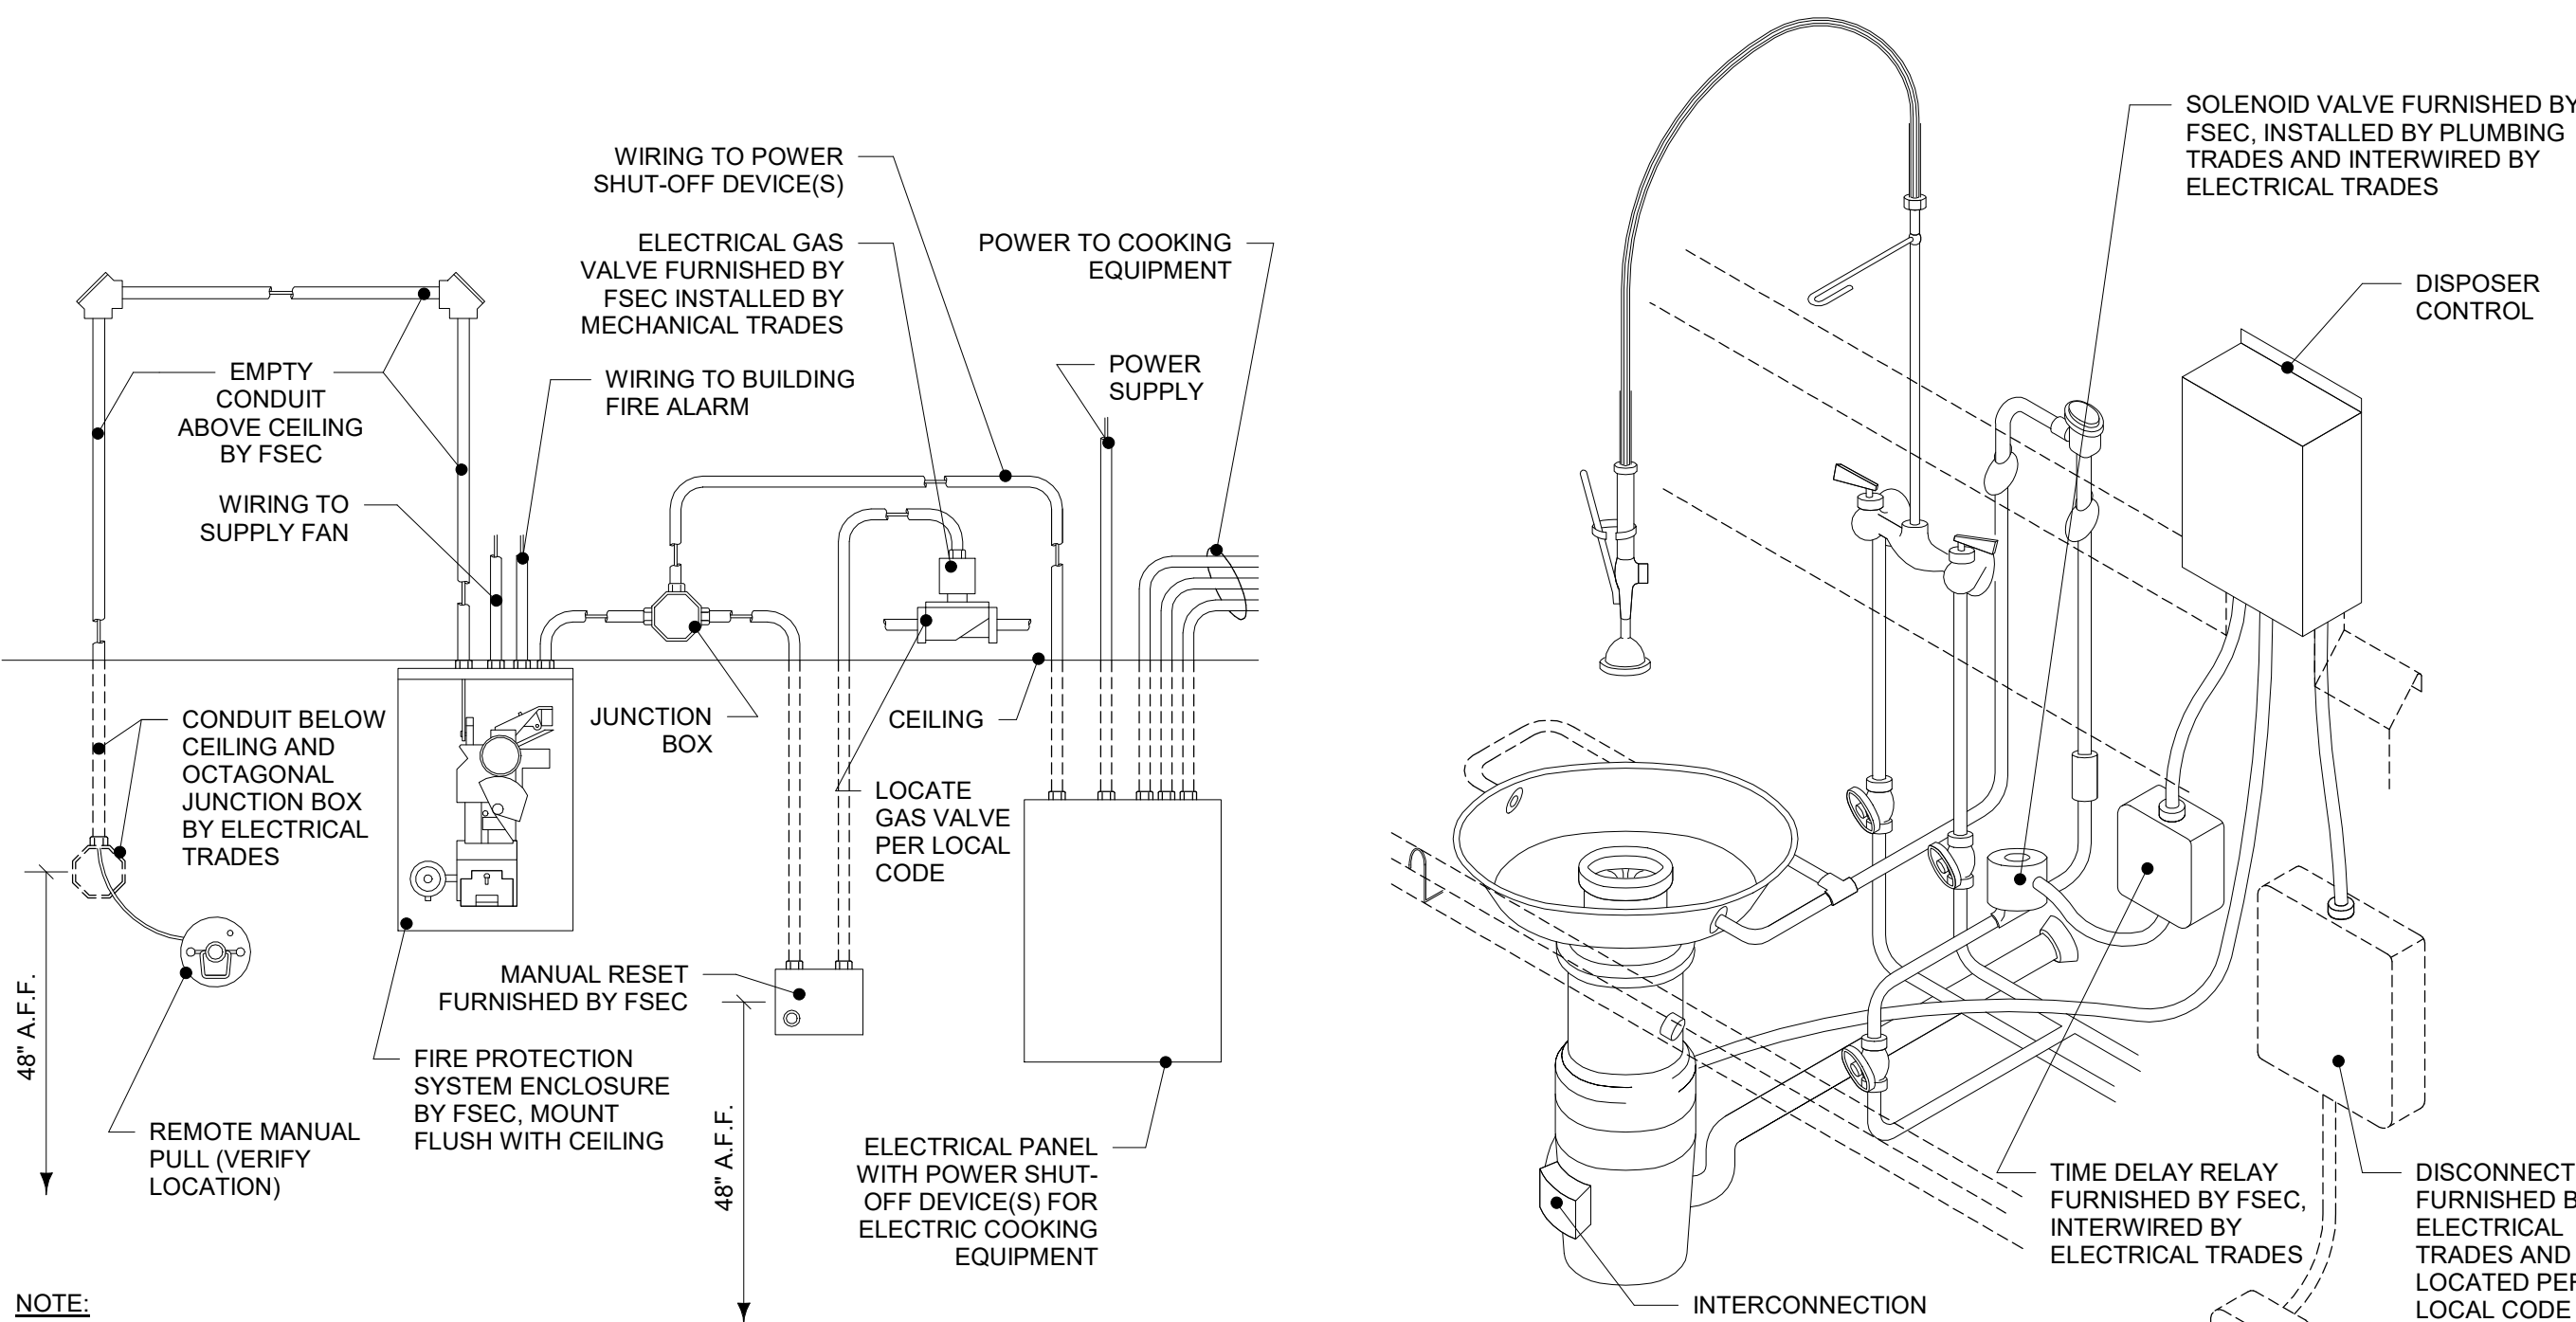


NOTE:
1. ELECTRICAL COMPONENTS AND INTERWIRING BY ELECTRICAL TRADES UNLESS NOTED OTHERWISE.
2. CONDUIT CONCEALED IN WALL WHEREVER POSSIBLE. EXPOSED CONDUIT TO BE CHROME-PLATED.

WET CHEMICAL FIRE PROTECTION SYSTEM

WIRING DIAGRAM - ELECTRIC GAS VALVE

ROBERT RIPPE & ASSOCIATES, INC.

© 2011 ROBERT RIPPE

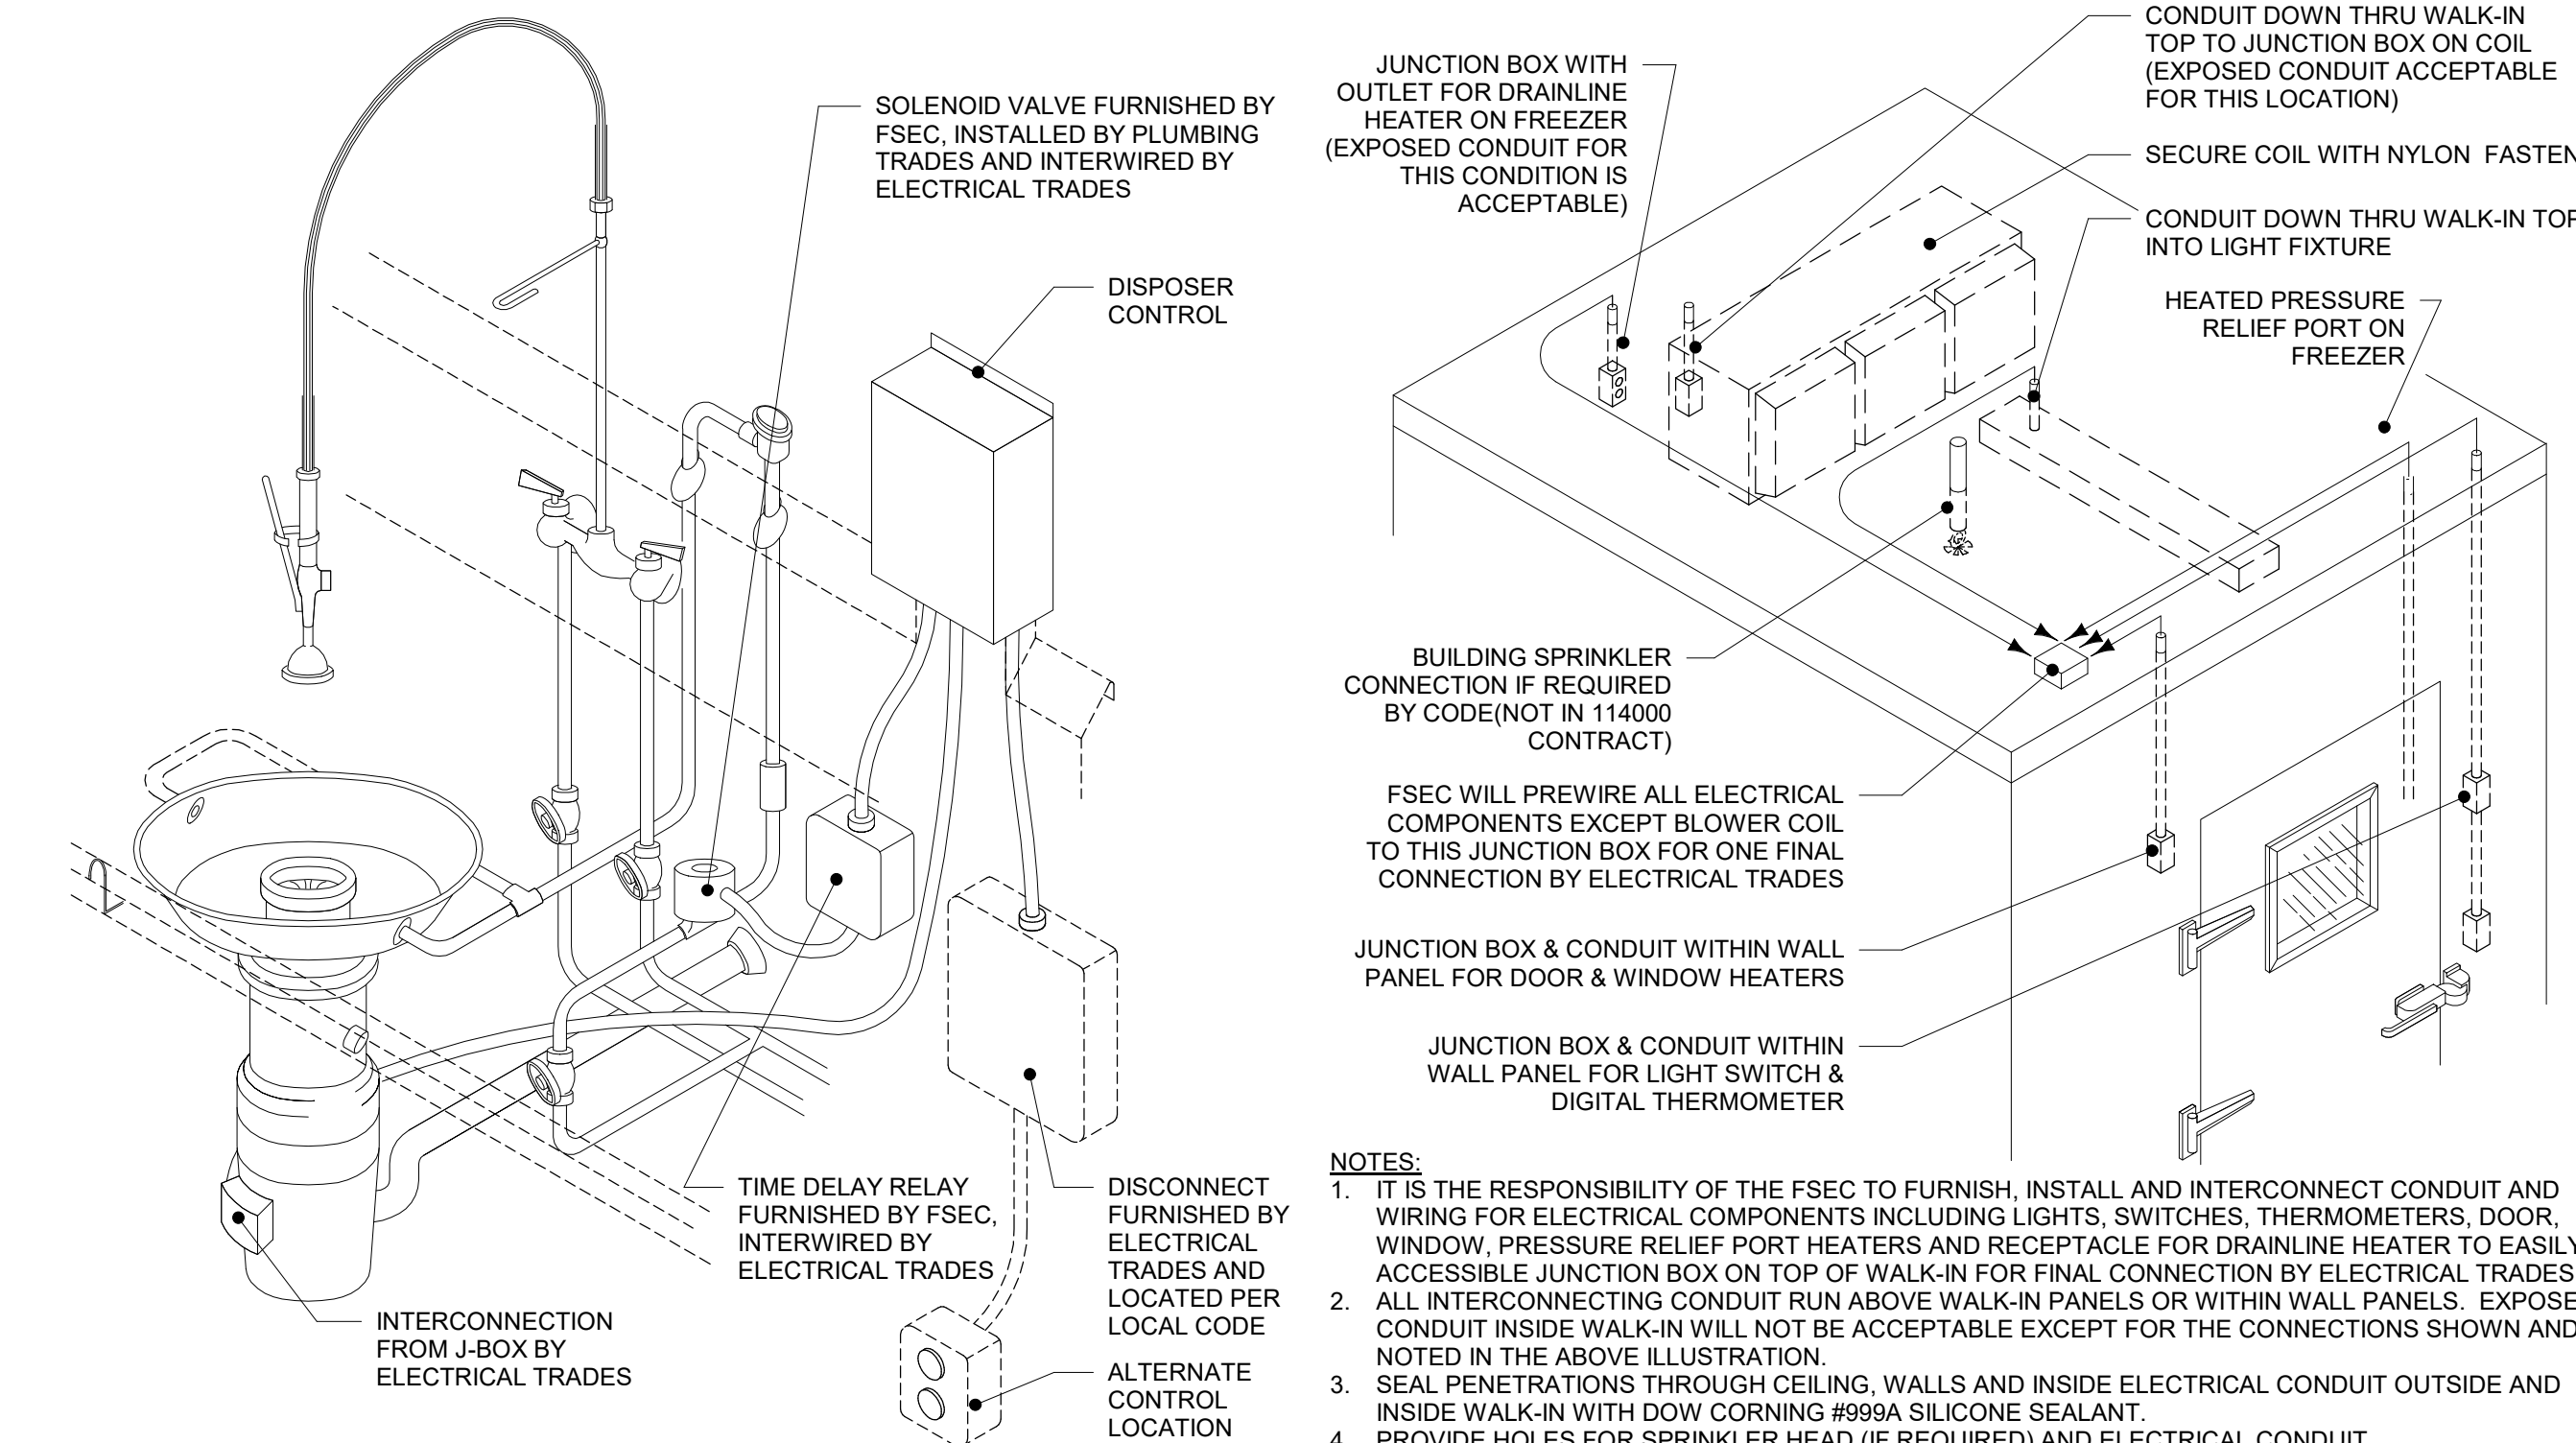


DISPOSER

WITH TIME DELAY RELAY

ROBERT RIPPE & ASSOCIATES, INC.


© 2011 ROBERT RIPPE

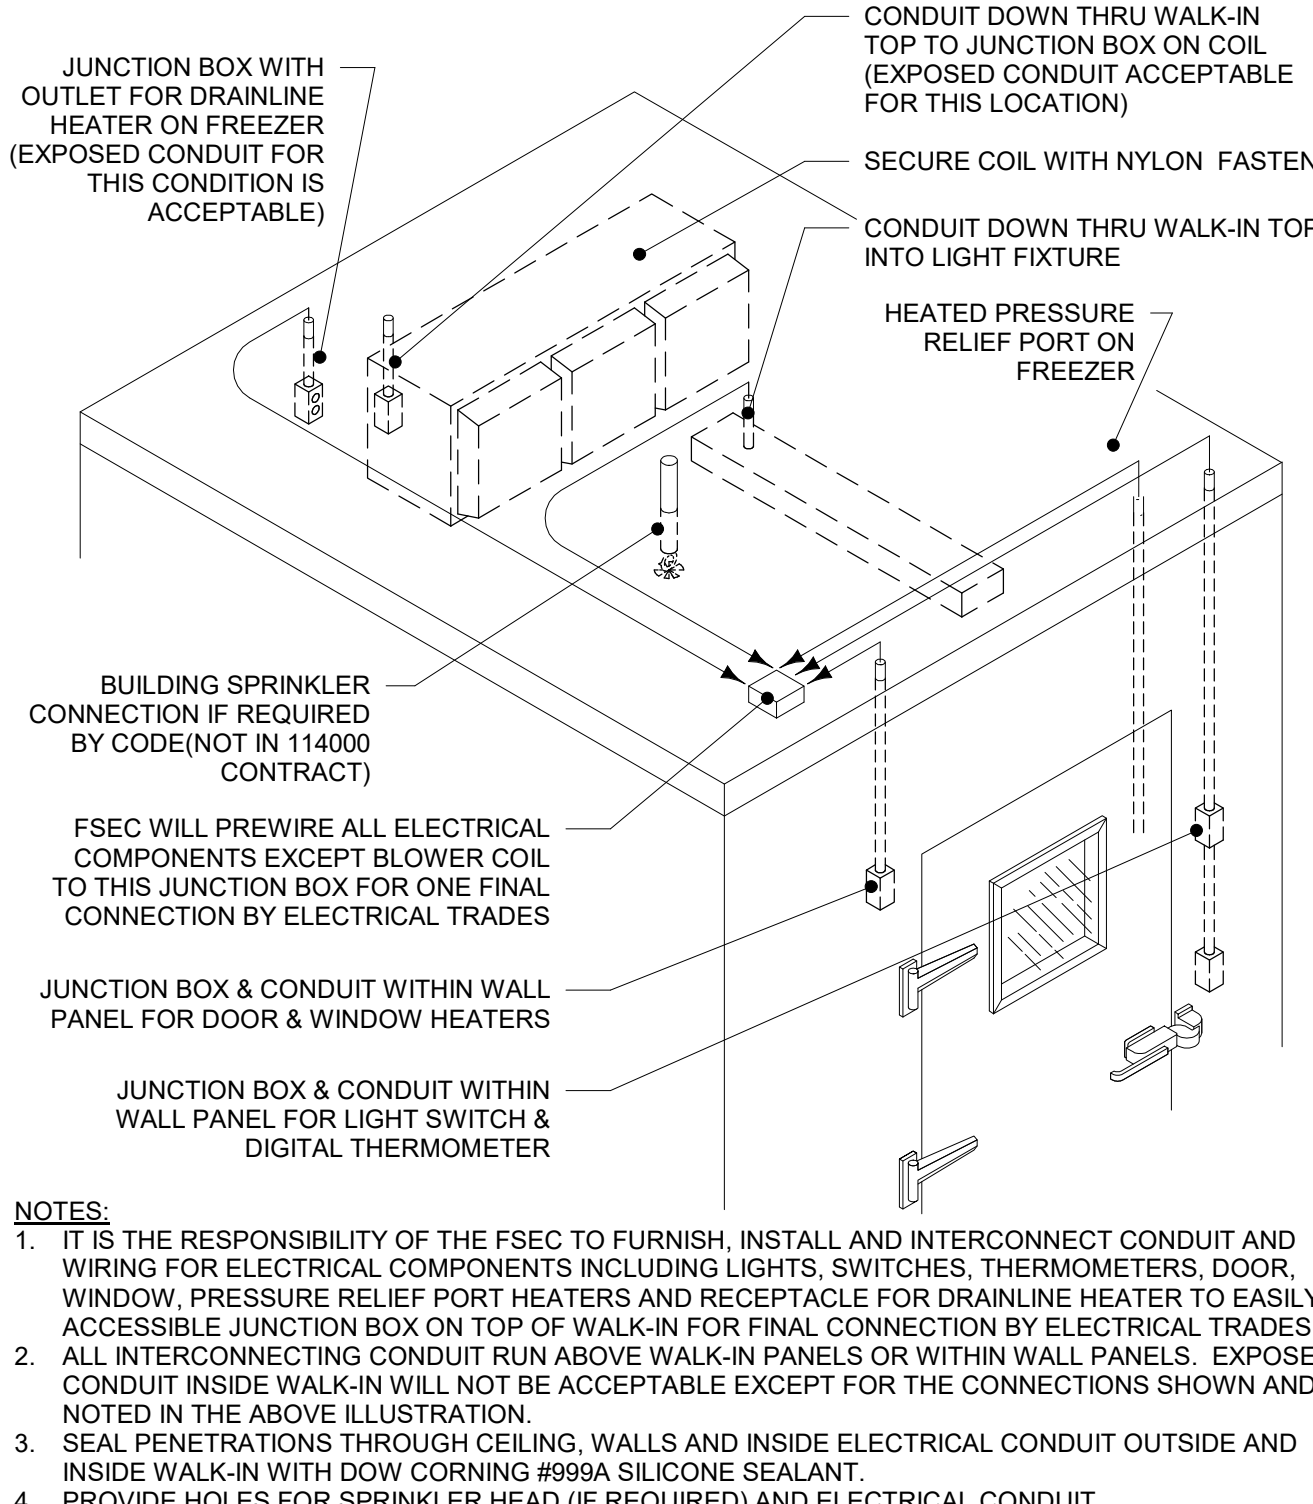

WALK-IN REFRIGERATOR/FREEZER SD-191

WIRING DIAGRAM - ELECTRIC GAS VALVE

ROBERT RIPPE & ASSOCIATES, INC.

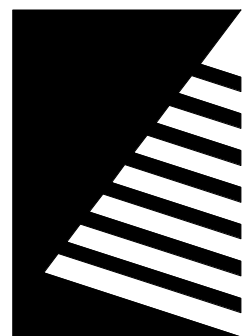

Farnsworth
GROUP

14225 UNIVERSITY AVENUE, SUITE 110
WALKEE, IOWA 50263
(515) 225-3469 / info@f-w.com

www.f-w.com
Engineers | Architects | Surveyors | Scientists

RIPPE ASSOCIATES
FOODSERVICE DESIGN + CONSULTING

kpff

IMEG

Bishop Engineering

ISSUE:
DATE: DESCRIPTION:

BID SET

PROJECT:
STATE OF IOWA DEPARTMENT
OF CORRECTIONS

**CLARINDA
CORRECTIONAL
FACILITY - KITCHEN &
LAUNDRY ADDITION**

2000 N 16TH ST, CLARINDA, IA
51632

DATE: 02/09/2024

DESIGNED: EG/TP

DRAWN: MM

REVIEWED: EG/RB

SHEET TITLE:


**FOODSERVICE
EQUIPMENT
ELECTRICAL DETAILS
- UDS #41A**

SHEET NUMBER:

FSE101




PROJECT NO.: 0240202.00
RFB922300-02

☐	ELECTRICAL CONTRACTOR	☐
☒	E1. COOKING EQUIPMENT CIRCUIT BREAKERS MOUNTED IN A REMOTE LOCATION, PROVIDED BY OTHERS.	
☒	E2. RECEPTACLES MOUNTED IN UDS BY GAYLORD. ALL WIRING FROM REMOTE CIRCUIT BREAKERS PANEL TO RECEPTACLES BY ELECTRICAL CONTRACTOR.	
☒	E3. POWER SOURCE STUB-IN LOCATION (DOWN FROM CEILING)	
☒	E4. CONNECT ALL WIRES AT FIELD JOINTS. TERMINAL BLOCKS ARE MARKED FOR APPROPRIATE CONNECTION (REFER TO PLAN OR ELEVATION VIEW FOR FIELD JOINT LOCATIONS)	
☒	E5. INSPECT FOR ANY LOOSE CONNECTIONS CAUSED BY SHIPPING AND TIGHTEN AS NEEDED.	

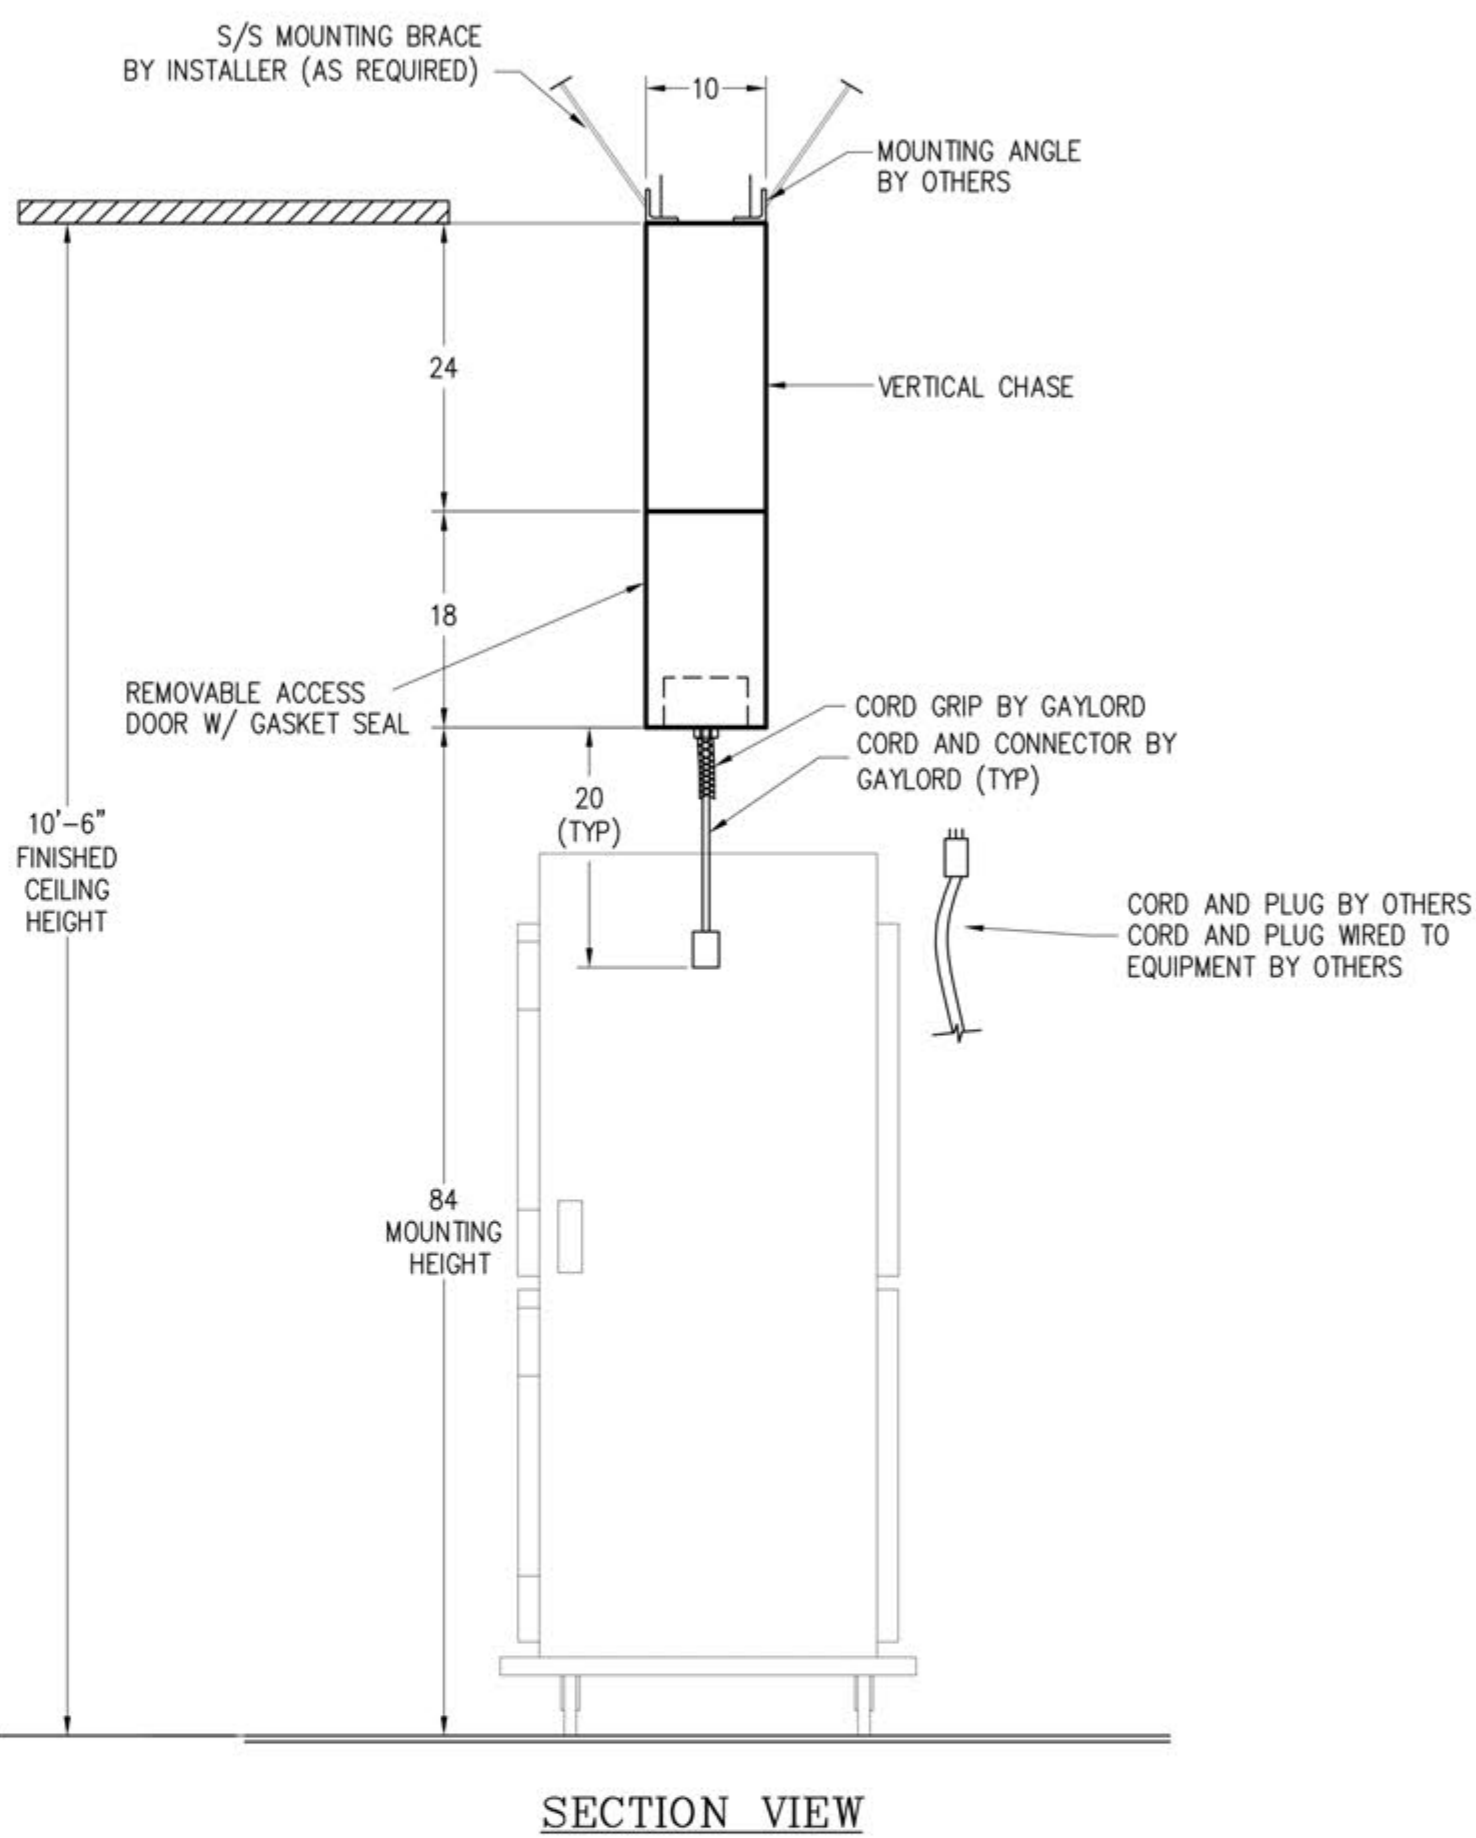


SHOP NOTES (T2)

* CEILING MOUNT UDS

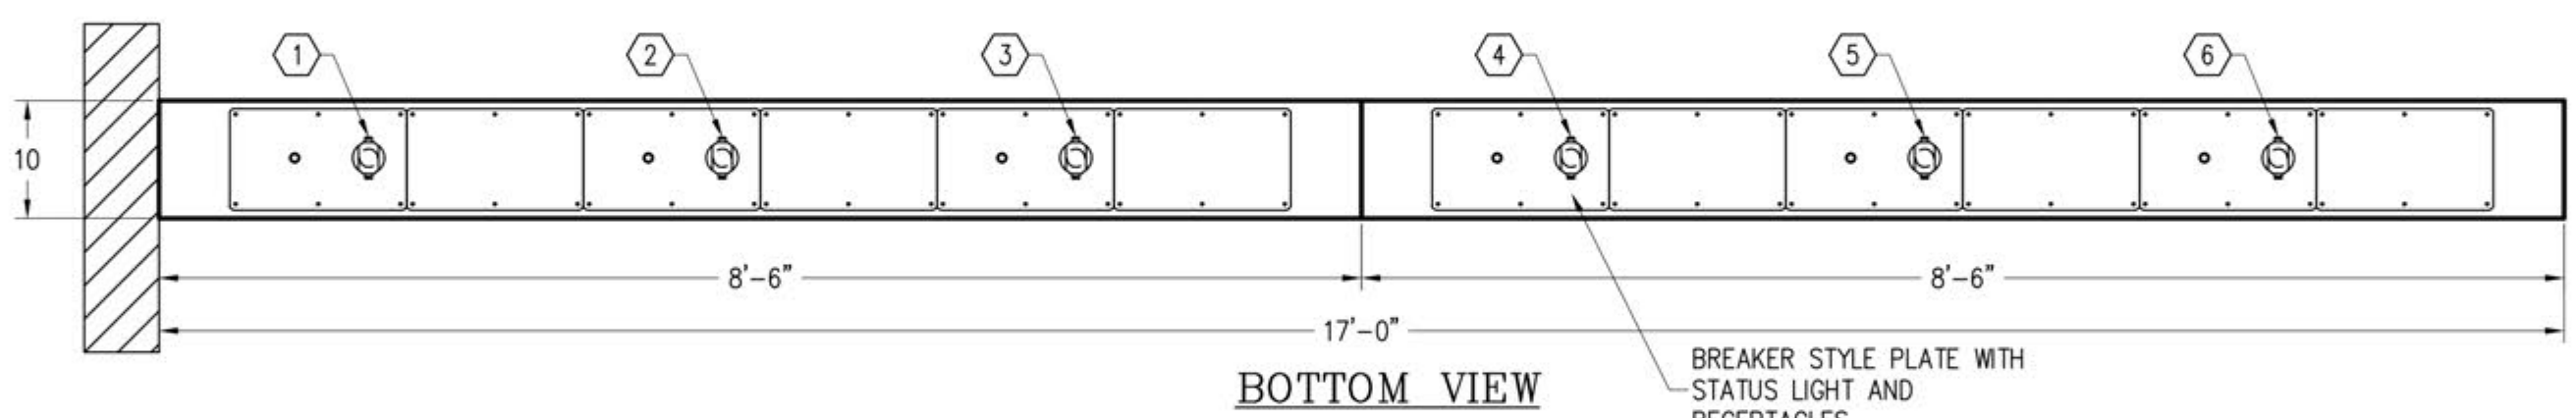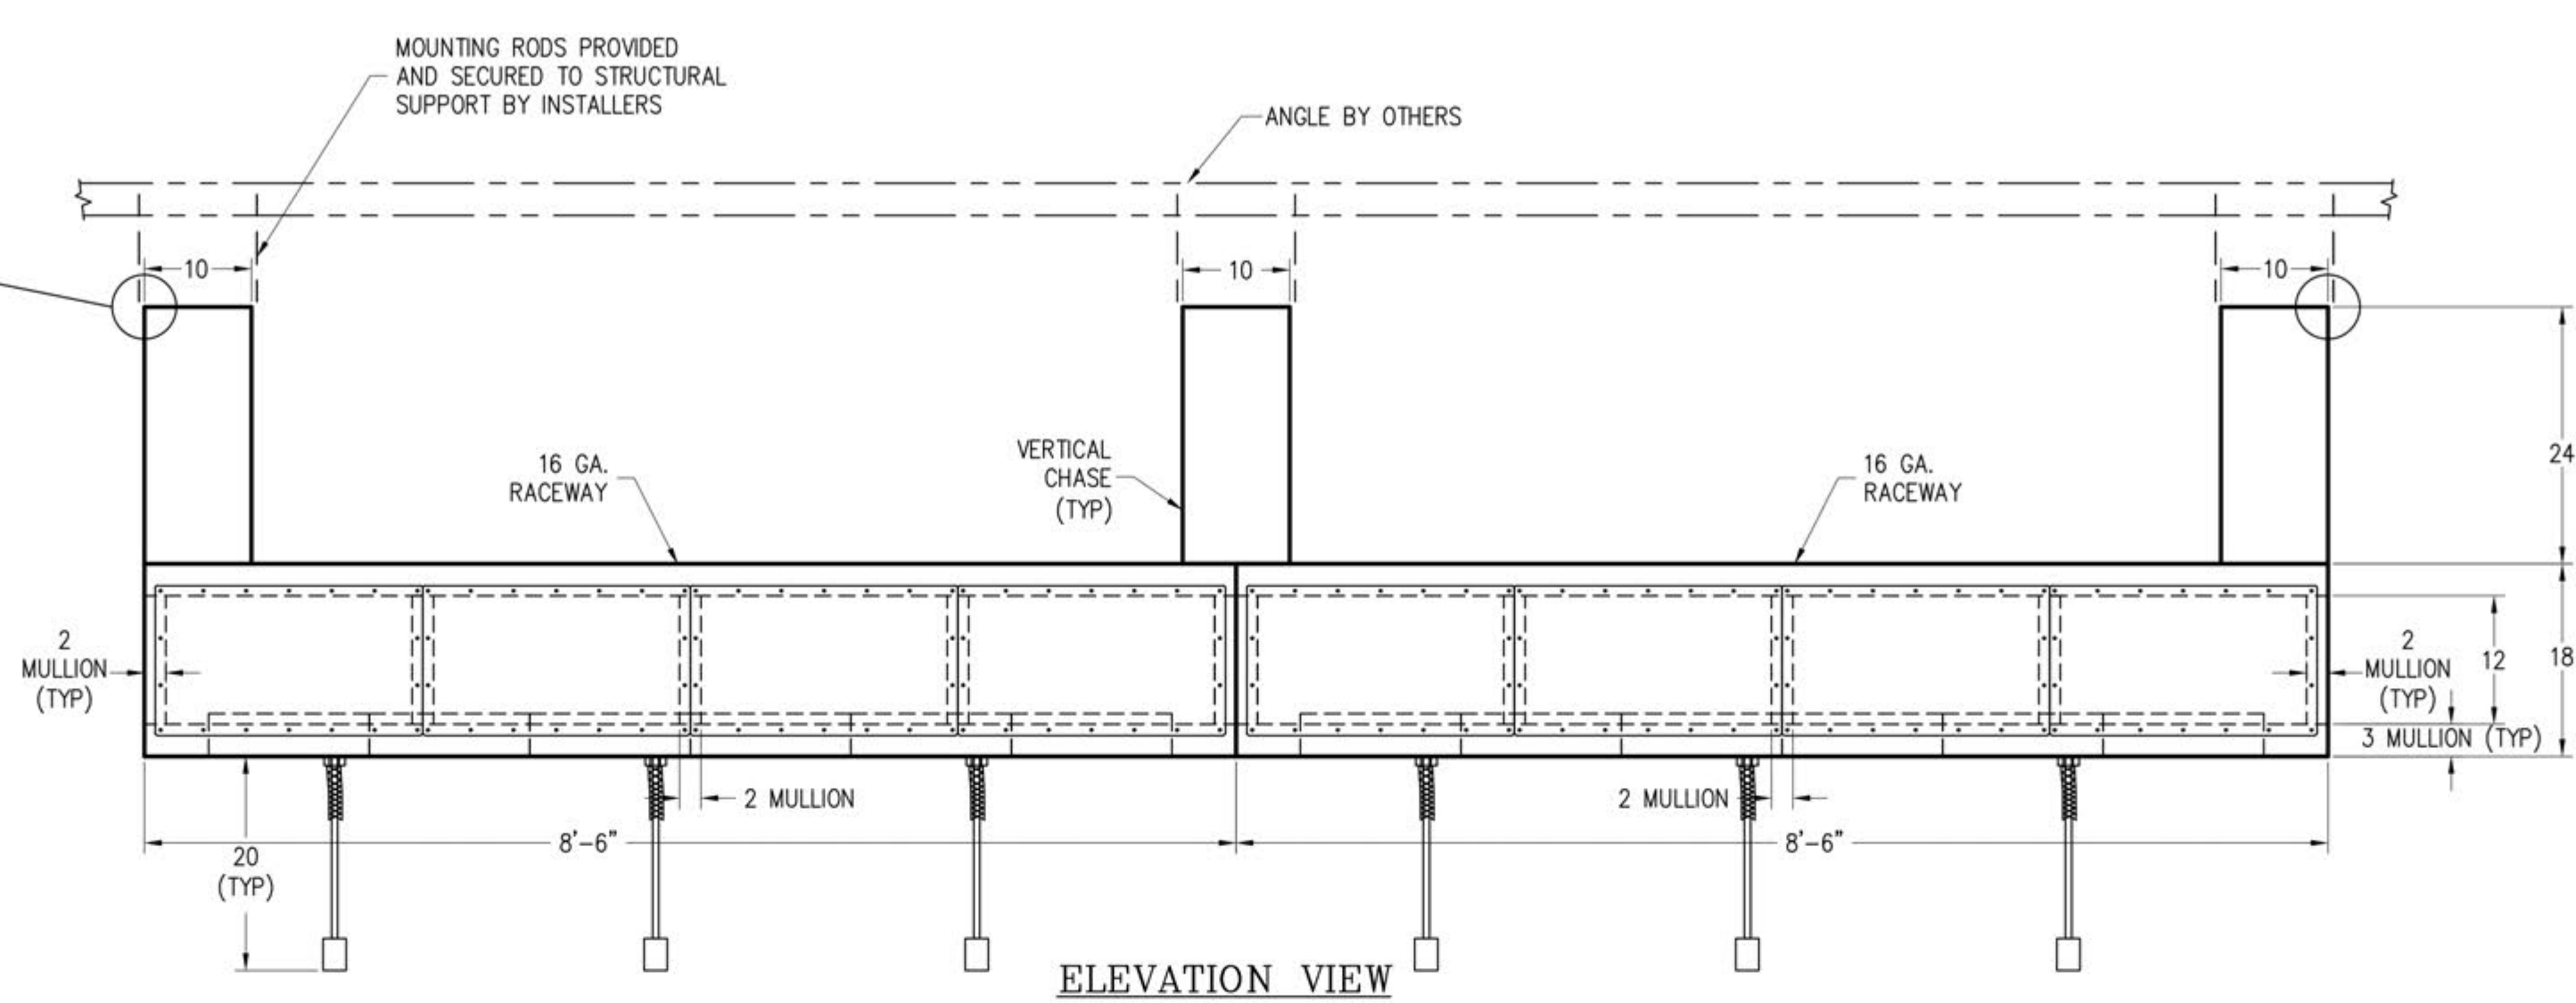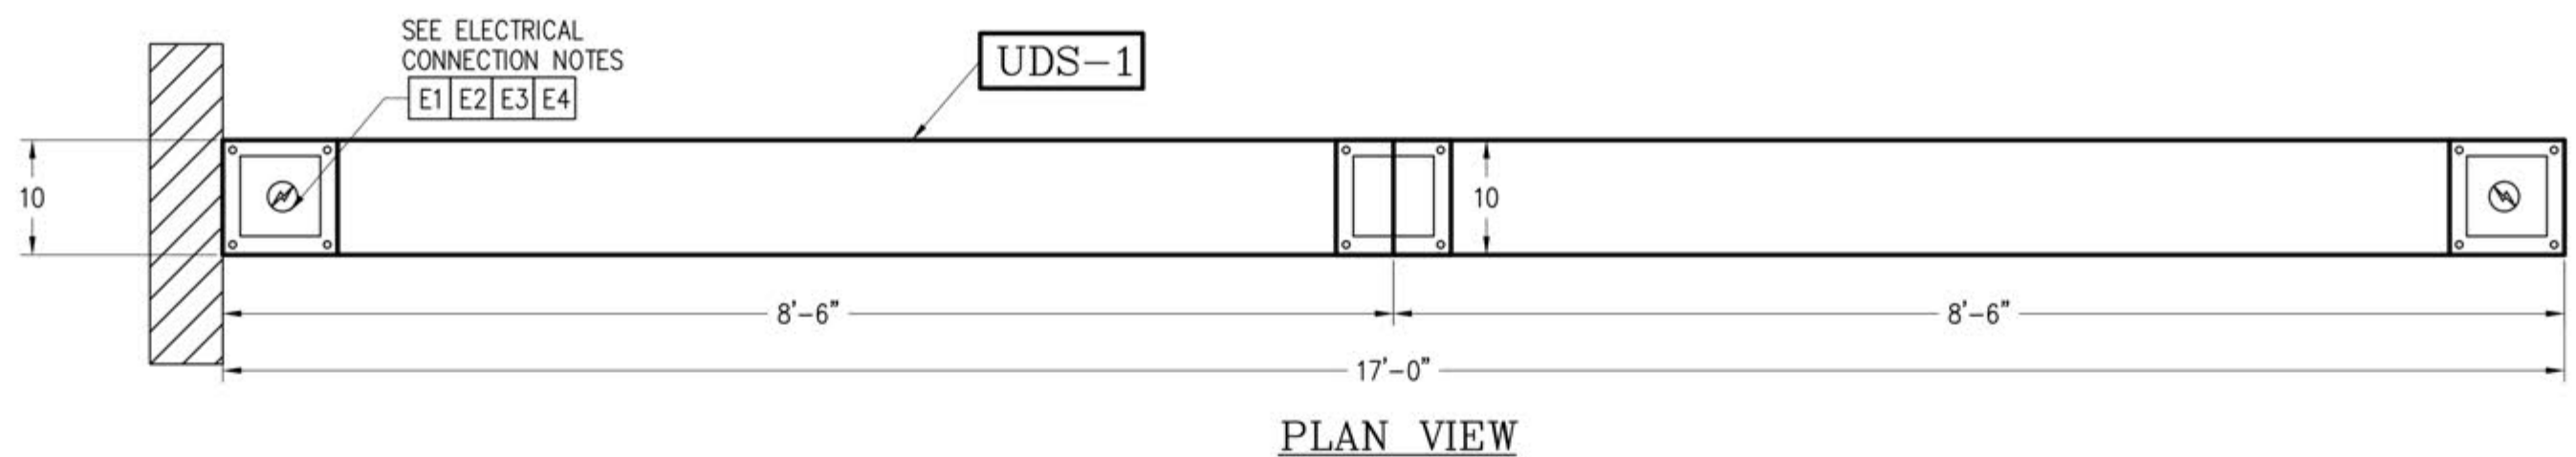

UDS SCHEDULE																		
EQUIPMENT					ELECTRICAL									REMARKS		BILL NUMBER		CONN. NO.
ITEM NO.	CONN. NO.	DESCRIPTION	MFG.	MODEL	K.W.	VOLTS	PH.	AMPS	BREAKER SIZE	POLE	WIRE SIZE	CORD LENGTH	CIRCUIT TYPE				QTY	
	1	ELEC. CONN.	JONES ZYLON	JZHR-168	1.80	120	1	15	20	1	12	--	GFCI	NEMA 5-20R CONNECTOR			1	
	2	ELEC. CONN.	JONES ZYLON	JZHR-168	1.80	120	1	15	20	1	12	--	GFCI	NEMA 5-20R CONNECTOR			2	
	3	ELEC. CONN.	JONES ZYLON	JZHR-168	1.80	120	1	15	20	1	12	--	GFCI	NEMA 5-20R CONNECTOR			3	
	4	ELEC. CONN.	JONES ZYLON	JZHR-168	1.80	120	1	15	20	1	12	--	GFCI	NEMA 5-20R CONNECTOR			4	
	5	ELEC. CONN.	JONES ZYLON	JZHR-168	1.80	120	1	15	20	1	12	--	GFCI	NEMA 5-20R CONNECTOR			5	
	6	ELEC. CONN.	JONES ZYLON	JZHR-168	1.80	120	1	15	20	1	12	--	GFCI	NEMA 5-20R CONNECTOR			6	
REMARKS																		
TOTAL CONNECTED LOAD																		
RESERVE FOR FUTURE																		
SERVICE SIZE BY OTHERS																		
UDS COMPONENTS																		
		DESCRIPTION	MANUFACTURER			MODEL #			REMARKS					BILL #	QTY			
		120/1PH/20A CONNECTOR (NEMA 5-20)	HUBBELL			HBL5369								50382	6			
		CORD GRIP (1/2" NPT, 0.625"-0.75")	HUBBELL			074011247								50024	6			

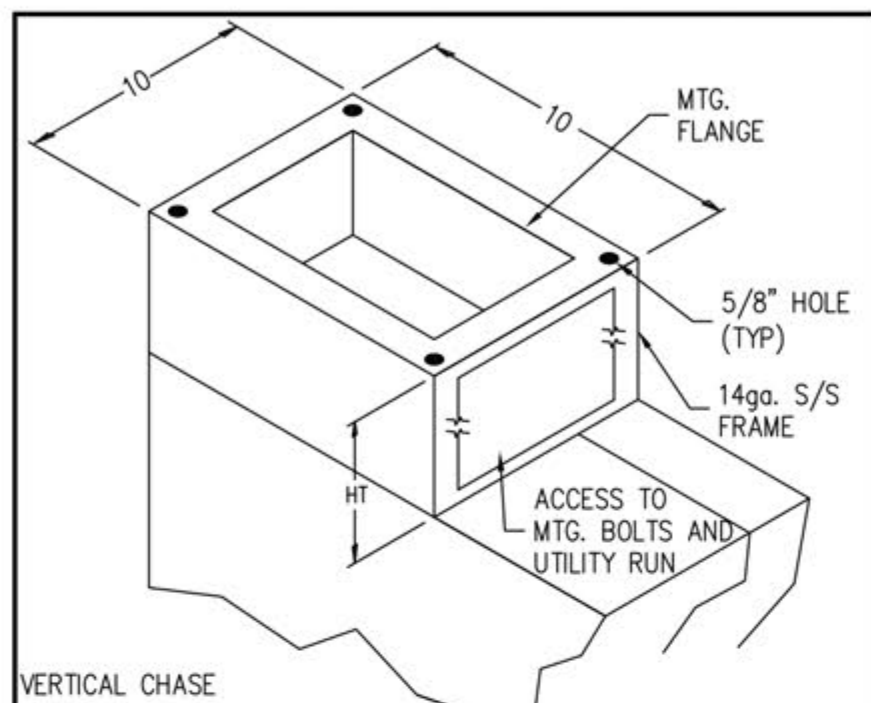

SYMBOL CHART	
	ELECTRICAL CONNECTION
	AIR INLET
	EQUIPMENT CONNECTION CALLOUT
	ELECTRICAL CALLOUT
	PLUMBING CALLOUT



VERIFY CEILING CONDITIONS


EXACT FLOOR TO STRUCTURAL CEILING AND FLOOR TO FINISH CEILING HEIGHTS MUST BE VERIFIED FOR UTILITY DISTRIBUTION SYSTEM DESIGN. INCORRECT HEIGHTS MAY CAUSE THE UDS TO NOT FIT PROPERLY. UTILITY CONNECTION MAY NOT REACH EQUIPMENT PROPERLY OR COMPLY WITH CLEARANCES SPECIFIED IN APPLICABLE CODES AND STANDARDS.

FLOOR TO STRUCTURAL CEILING: (VERIFY)
FLOOR TO FINISH CEILING: 10'-6" (VERIFY)

ELECTRICAL NOTE
ELECTRICAL CONTRACTOR TO PROVIDE EACH BRANCH CIRCUIT BREAKER AND WIRING TO THE UDS TERMINAL BLOCKS, AND GROUND TERMINAL LUG. FOR COMPLETE SHUT OFF OF ELECTRICAL POWER, MAIN CIRCUIT BREAKER SHOULD BE TURNED OFF.

IMPORTANT NOTES:
1) EQUIPMENT MAKE, MODEL MUST BE VERIFIED TO ASSURE CORRECT UTILITY LOADS, PRIOR TO RELEASE FOR FABRICATION. ANY CHANGES TO THE EQUIPMENT AFTER APPROVAL OR RELEASE, WILL ADD COST AND EFFECT SHIPPING DATES.
2) SEE U.S. SCHEDULE FOR EQUIPMENT CONNECTIONS

UDS WIRING DIAGRAM

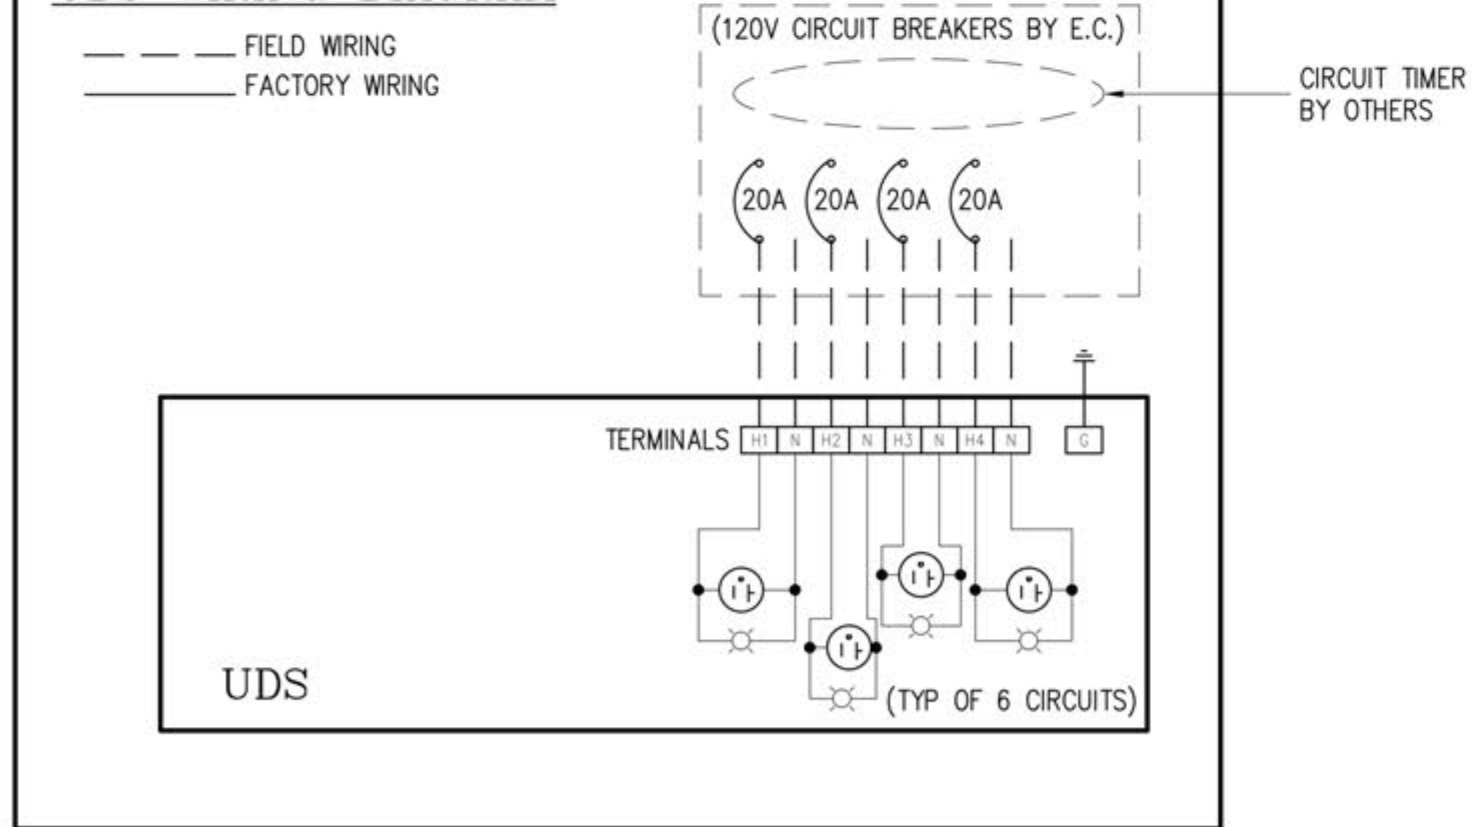

DIMENSION TOLERANCE ± 1/4" (6mm)		DH-CM-E3-17 (T2)		UDS-1		22168901	
DRAWN BY: EP		CHECKED BY:		ELECT. CHECK:		F.P. CHECK:	
DATE: 22-1689		DATE: 08-25-22		REV: 00		SHEET NO.: 01	

**GAYLORD®
INDUSTRIES**

10900 S.W. AVERY ST.
TUALATIN, OR 97062

TELEPHONE: (503) 691-2010
TOLL FREE: (800) 547-9696
FAX NO.: (503) 692-6048
E-MAIL: gaylord@gaylordusa.com


CLARINDA CORRECTIONAL FACILITY
CLARINDA, IA



INSTALLATION INFORMATION			
01	RD	09-06-22	REVISED EQUIPMENT TO 1.8 KW, 15 AMPS
00	EP	08-25-22	INITIAL DESIGN
REV	DRWN BY	DATE	REVISIONS
			CHECKED BY

This plan is made from available information, but measurements are to be verified by contractors, installers and others in connection with this job. Gaylord Industries accepts no responsibility for work done by contractors, installers and others, and will not stand any expense for charges made necessary by local building codes, ordinances, structural conditions or by the substitution or changes in equipment shown in this plan. This plan must be verified and approved by proper parties before fabrication can be started and approval shall not be made unless contractors, installers and others have reviewed applicable codes with code authorities. Reference is made to the general notes, which are a part of these plans and all contractors, installers and others utilizing these plans are advised they are responsible for examining and becoming familiar with said general notes before commencing any work hereunder. Any inconsistencies between these plans and the general notes, or between these plans, the general notes, and local building codes or ordinances must be immediately called to the attention of Gaylord Industries in writing so that any such inconsistencies can be resolved.

Gaylord Industries must be notified of any changes made to the plan in a clear and conspicuous manner. Gaylord Industries will not be responsible for any incidental or consequential damages incurred by others as a result of contractors, installers and others failure to notify Gaylord of changes to the plan.
ATTENTION - This plan is the property of Gaylord Industries and is confidential and proprietary. It is not to be copied, reproduced, or distributed, in whole or part, nor be used in anyway detrimental to Gaylord Industries. If you have received this plan without Gaylord's permission, please (i) do not read it, (ii) reply to the sender that you received the drawing in error, and (iii) erase and/or destroy the drawing.

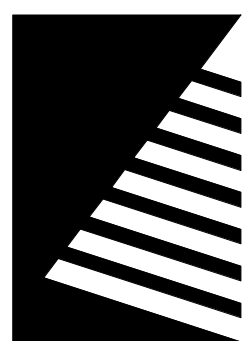

Farnsworth
GROUP

14225 UNIVERSITY AVENUE, SUITE 110
WALKEE, IOWA 50263
(515) 225-3469 / info@f-w.com

www.f-w.com
Engineers | Architects | Surveyors | Scientists

RIPE ASSOCIATES
FOODSERVICE DESIGN + CONSULTING

kpff

IMEG

Bishop Engineering

ISSUE
DATE DESCRIPTION

BID SET

PROJECT:
STATE OF IOWA DEPARTMENT
OF CORRECTIONS

CLARINDA
CORRECTIONAL
FACILITY - KITCHEN &
LAUNDRY ADDITION

2000 N 16TH ST, CLARINDA, IA
51632

DATE: 02/09/2024

DESIGNED: EG/TP

DRAWN: MM

REVIEWED: EG/RB

SHEET TITLE:


FOODSERVICE
EQUIPMENT
ELECTRICAL DETAILS
- UDS #41B

SHEET NUMBER:

FSE102


PROJECT NO.: 0240202.00
RF8922300-02

☐	ELECTRICAL CONTRACTOR	☐
☒	E1. COOKING EQUIPMENT CIRCUIT BREAKERS MOUNTED IN A REMOTE LOCATION, PROVIDED BY OTHERS.	
☒	E2. RECEPTACLES MOUNTED IN UDS BY GAYLORD. ALL WIRING FROM REMOTE CIRCUIT BREAKERS PANEL TO RECEPTACLES BY ELECTRICAL CONTRACTOR.	
☒	E3. POWER SOURCE STUB-IN LOCATION (DOWN FROM CEILING)	
☒	E4. CONNECT ALL WIRES AT FIELD JOINTS. TERMINAL BLOCKS ARE MARKED FOR APPROPRIATE CONNECTION (REFER TO PLAN OR ELEVATION VIEW FOR FIELD JOINT LOCATIONS)	
☒	E5. INSPECT FOR ANY LOOSE CONNECTIONS CAUSED BY SHIPPING AND TIGHTEN AS NEEDED.	

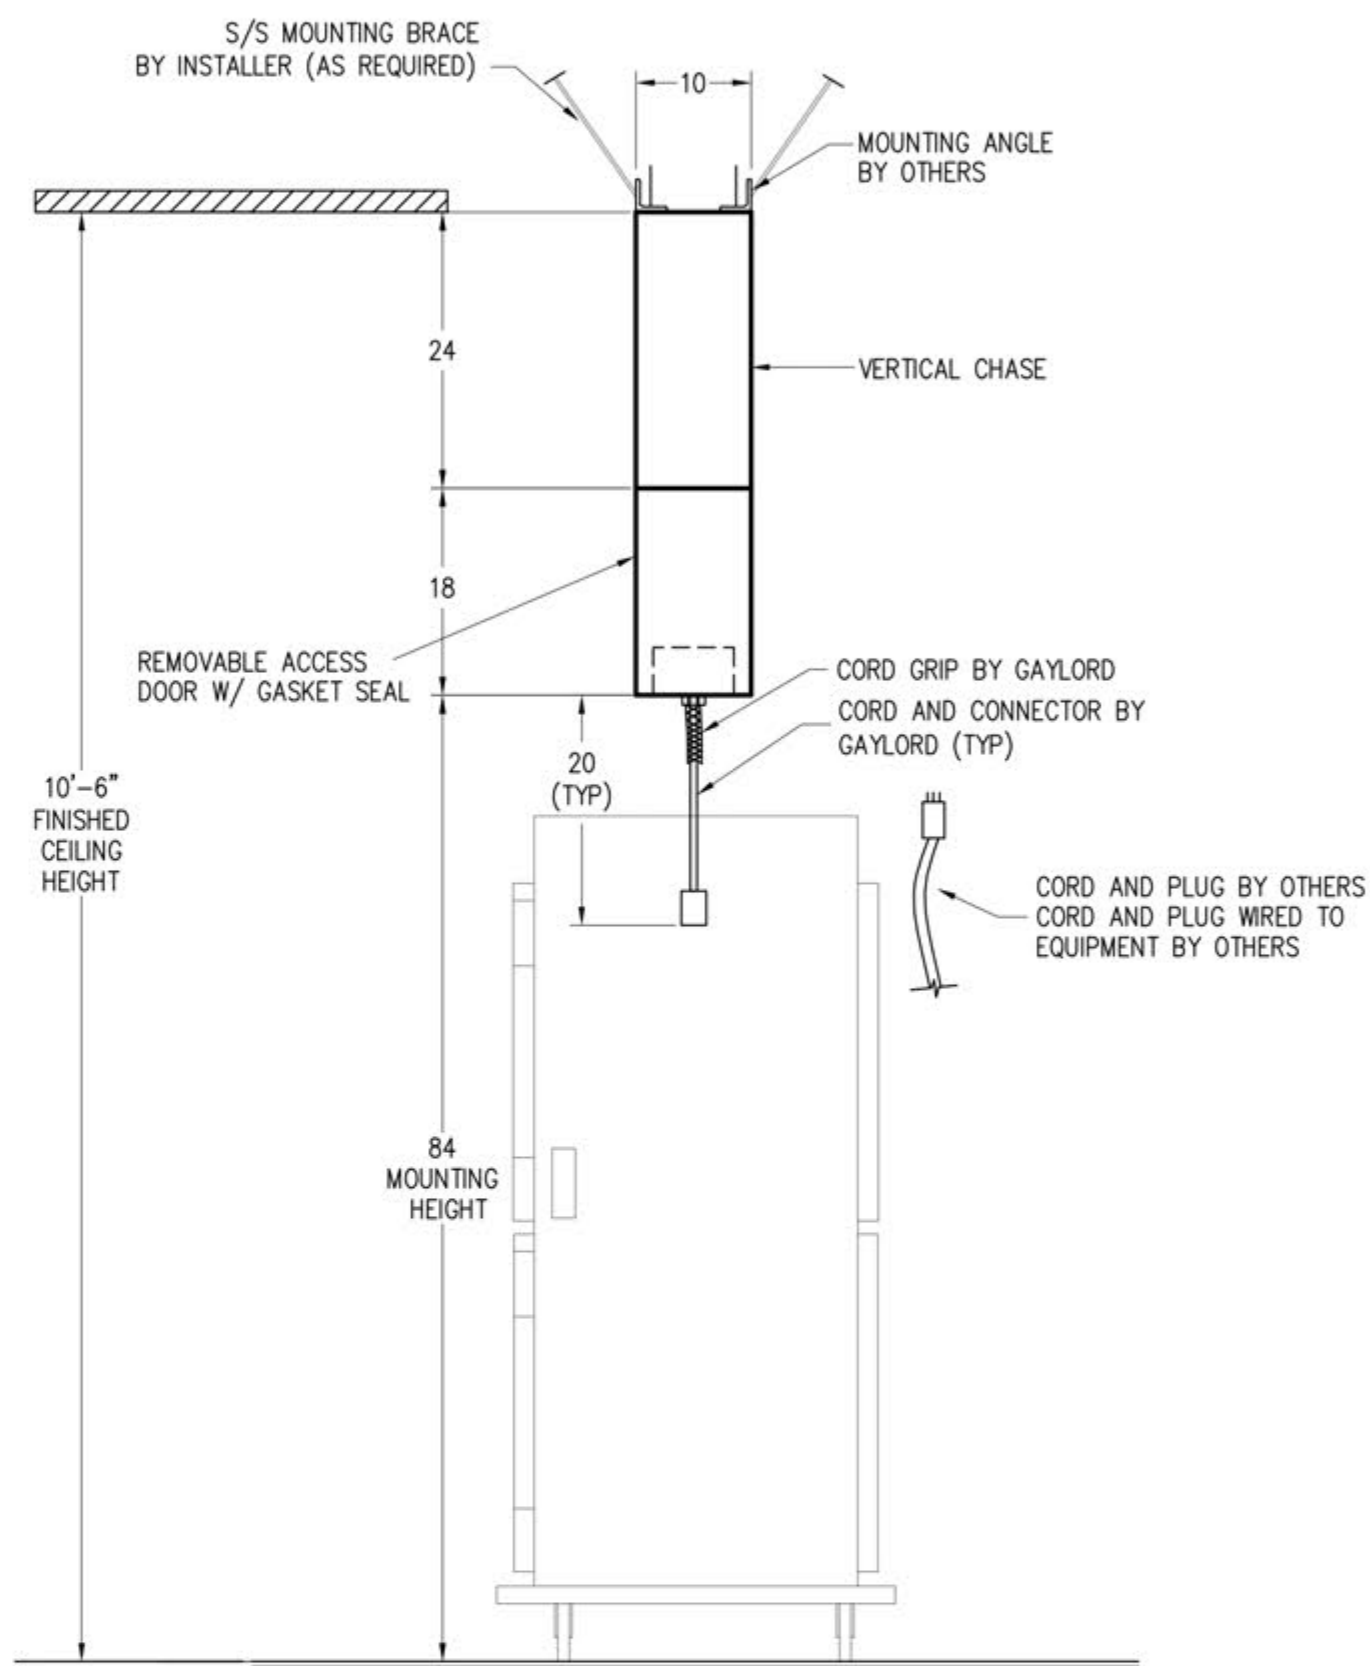


SHOP NOTES (T2)

* CEILING MOUNT UDS

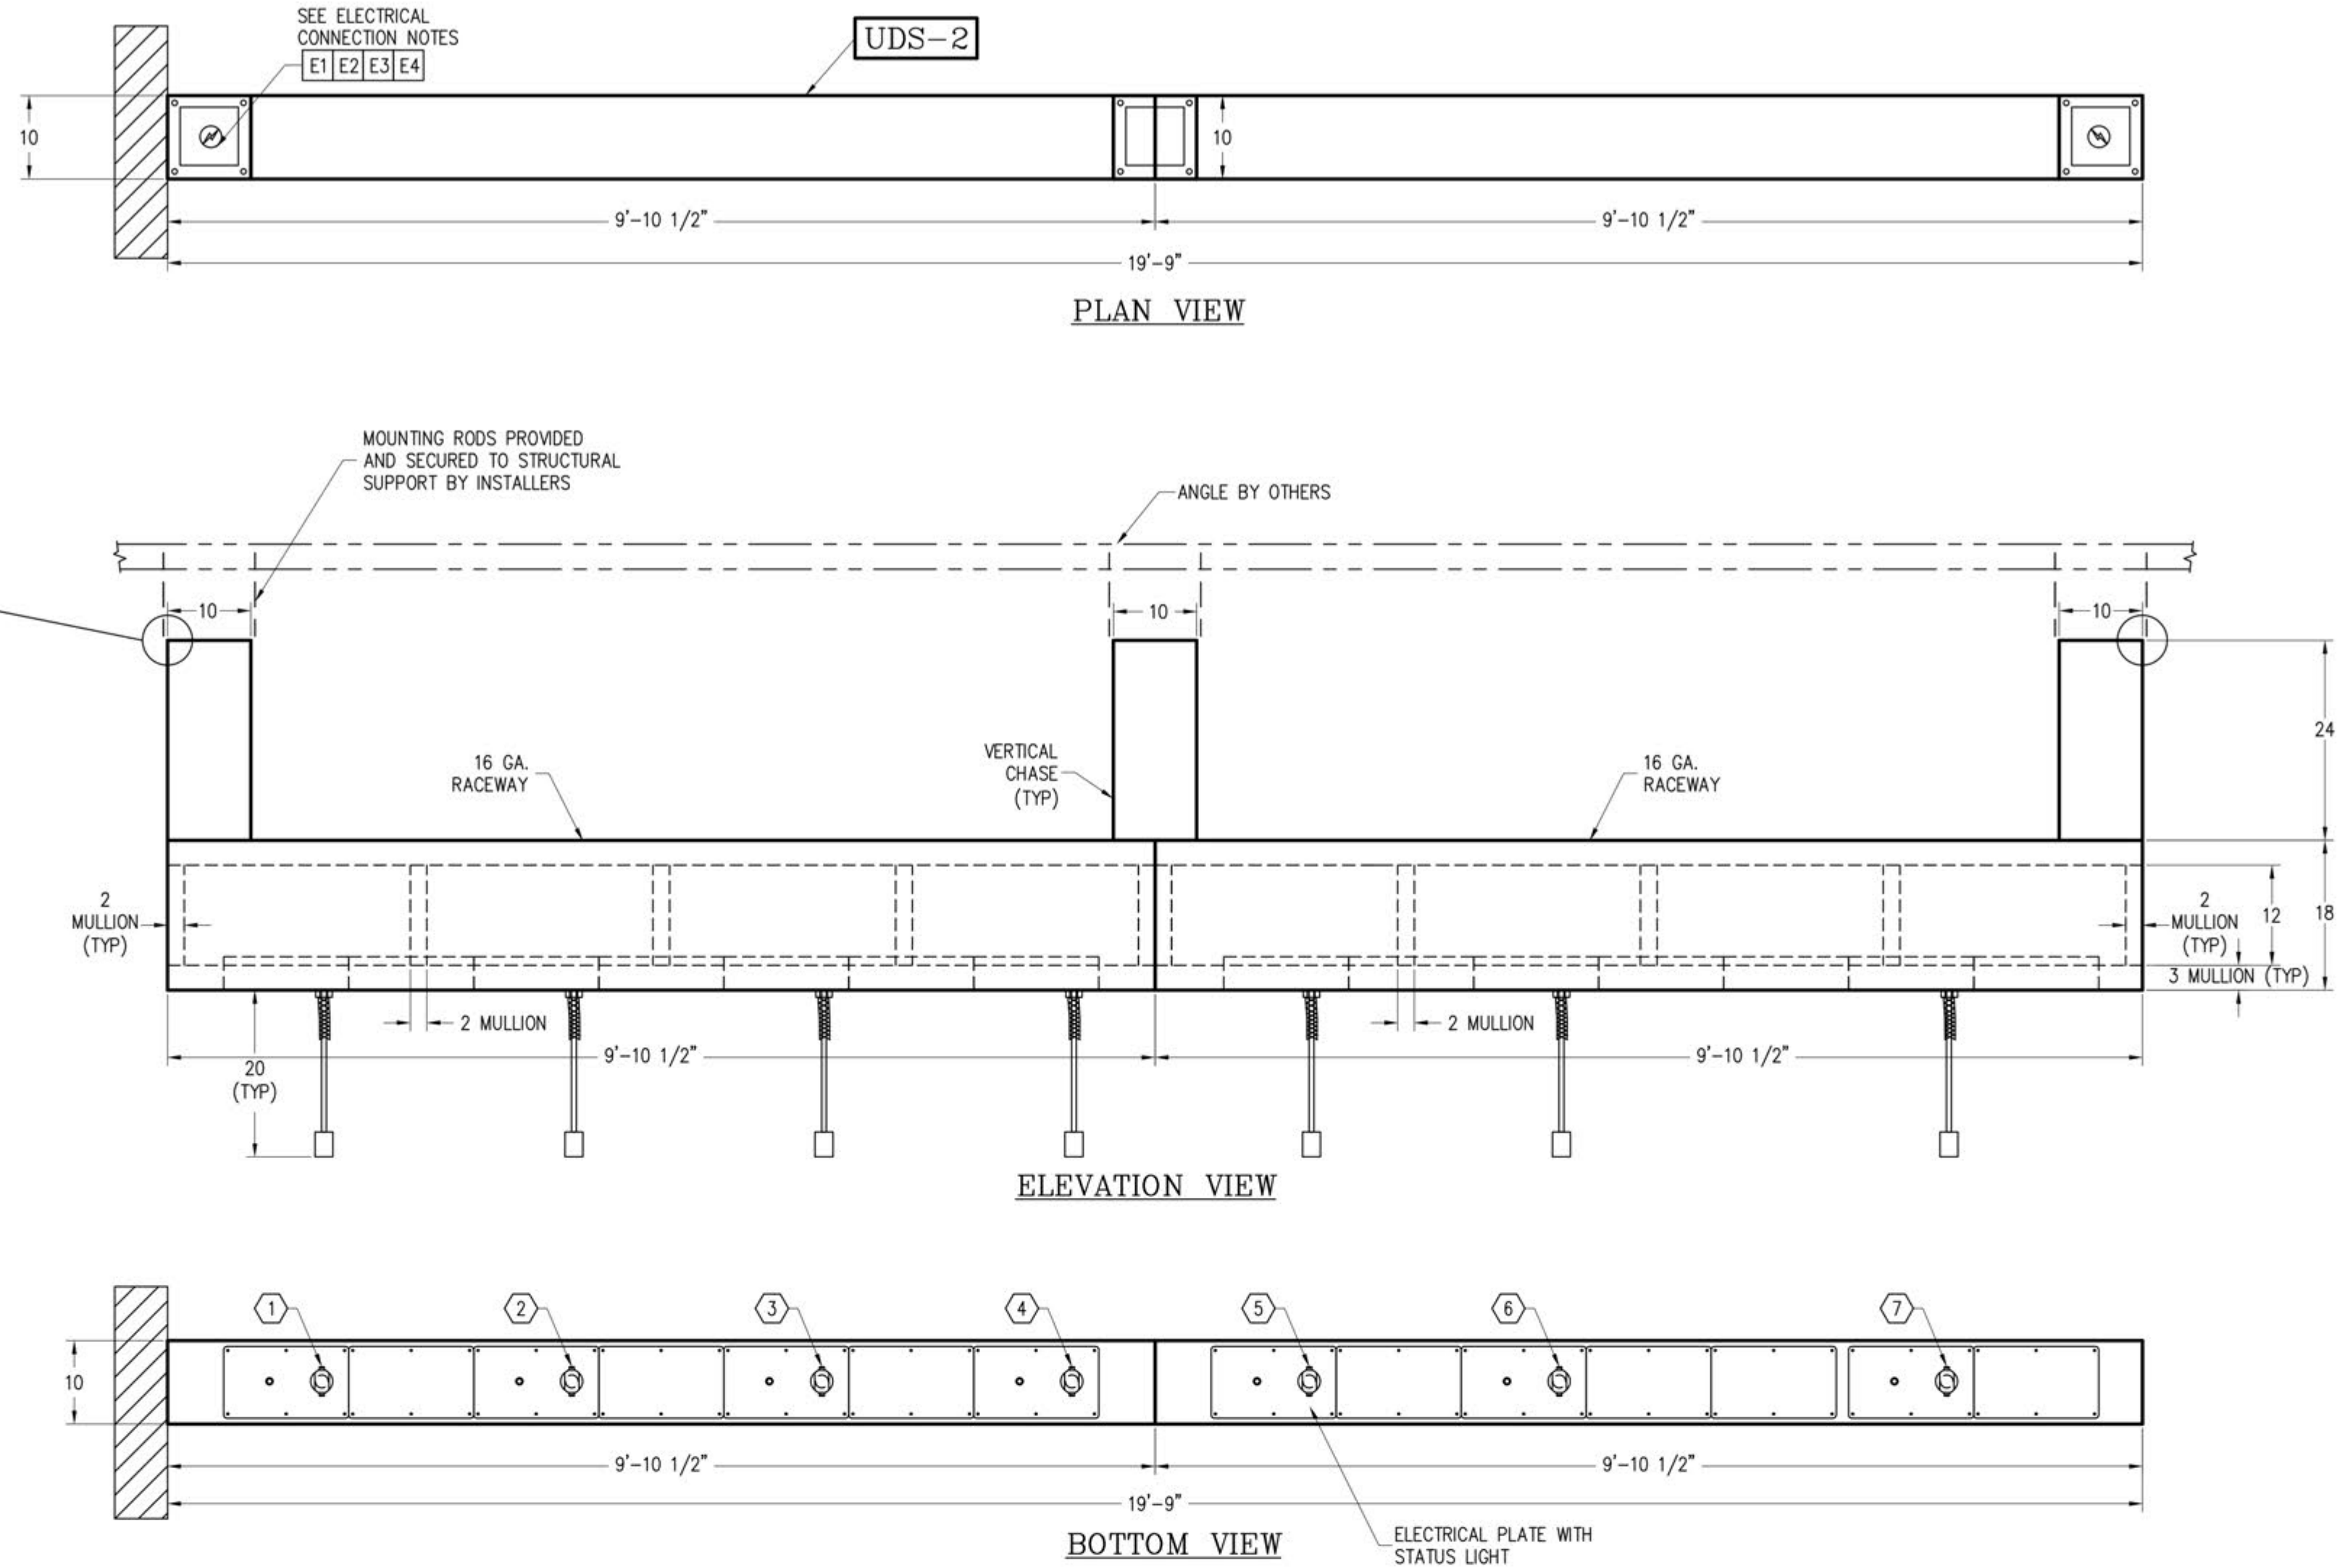

UDS SCHEDULE													
EQUIPMENT				ELECTRICAL				REMARKS				BILL NUMBER	
ITEM NO.	CONN. NO.	DESCRIPTION	MFG.	MODEL	K.W.	VOLTS	PH.	AMPS	BREAKER SIZE	WIRE SIZE	CORD SIZE	CIRCUIT TYPE	QTY
1	ELEC. CONN.	JONES ZYLON	JZHR-168	1.80	120	1	15	20	1	12	—	GFCI	1
2	ELEC. CONN.	JONES ZYLON	JZHR-168	1.80	120	1	15	20	1	12	—	GFCI	2
3	ELEC. CONN.	JONES ZYLON	JZHR-168	1.80	120	1	15	20	1	12	—	GFCI	3
4	ELEC. CONN.	JONES ZYLON	JZHR-168	1.80	120	1	15	20	1	12	—	GFCI	4
5	ELEC. CONN.	JONES ZYLON	JZHR-168	1.80	120	1	15	20	1	12	—	GFCI	5
6	ELEC. CONN.	JONES ZYLON	JZHR-168	1.80	120	1	15	20	1	12	—	GFCI	6
7	ELEC. CONN.	JONES ZYLON	JZHR-168	1.80	120	1	15	20	1	12	—	GFCI	7
TOTAL CONNECTED LOAD													
RESERVE FOR FUTURE													
SERVICE SIZE BY OTHERS													
UDS COMPONENTS													
DESCRIPTION	MANUFACTURER			MODEL #			REMARKS			BILL #		QTY	
120/1PH/20A CONNECTOR (NEMA 5-20)	HUBBELL			HBL5369						50382		7	
CORD GRIP (1/2" NPT, 0.625"-0.75")	HUBBELL			07401247						50024		7	

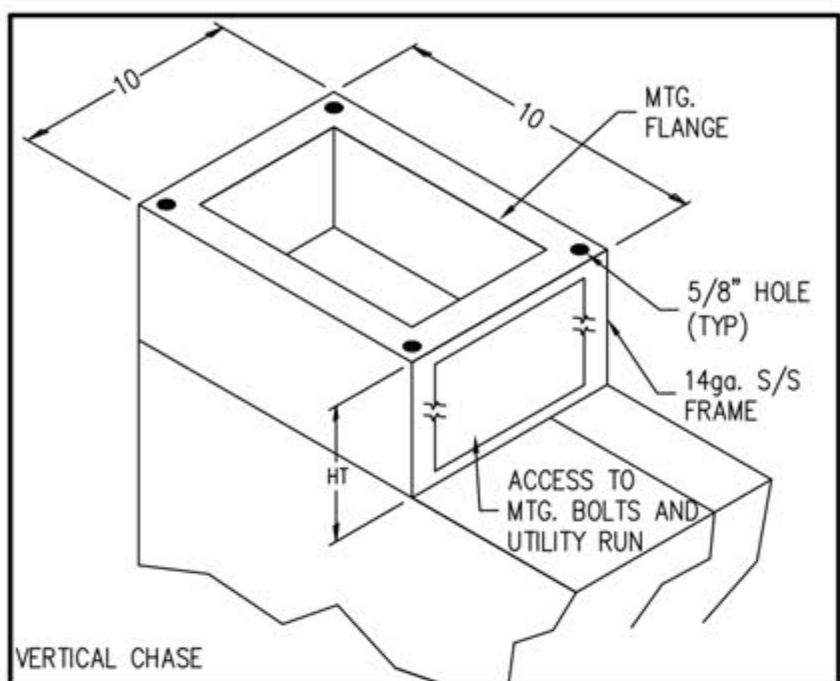

SYMBOL CHART	
	ELECTRICAL CONNECTION
	AIR INLET
	EQUIPMENT CONNECTION CALLOUT
	ELECTRICAL CALLOUT
	PLUMBING CALLOUT


VERIFY CEILING CONDITIONS

EXACT FLOOR TO STRUCTURAL CEILING AND FLOOR TO FINISH CEILING HEIGHTS MUST BE VERIFIED FOR UTILITY DISTRIBUTION SYSTEM DESIGN. INCORRECT HEIGHTS MAY CAUSE THE UDS TO NOT FIT PROPERLY. UTILITY CONNECTION MAT NOT REACH EQUIPMENT PROPERLY OR COMPLY WITH CLEARANCES SPECIFIED IN APPLICABLE CODES AND STANDARDS.

FLOOR TO STRUCTURAL CEILING: (VERIFY)
FLOOR TO FINISH CEILING: 10'-6" (VERIFY)

ELECTRICAL NOTE

ELECTRICAL CONTRACTOR TO PROVIDE EACH BRANCH CIRCUIT BREAKER AND WIRING TO THE UDS TERMINAL BLOCKS, AND GROUND TERMINAL LUG FOR COMPLETE SHUT OFF OF ELECTRICAL POWER. MAIN CIRCUIT BREAKER SHOULD BE TURNED OFF.

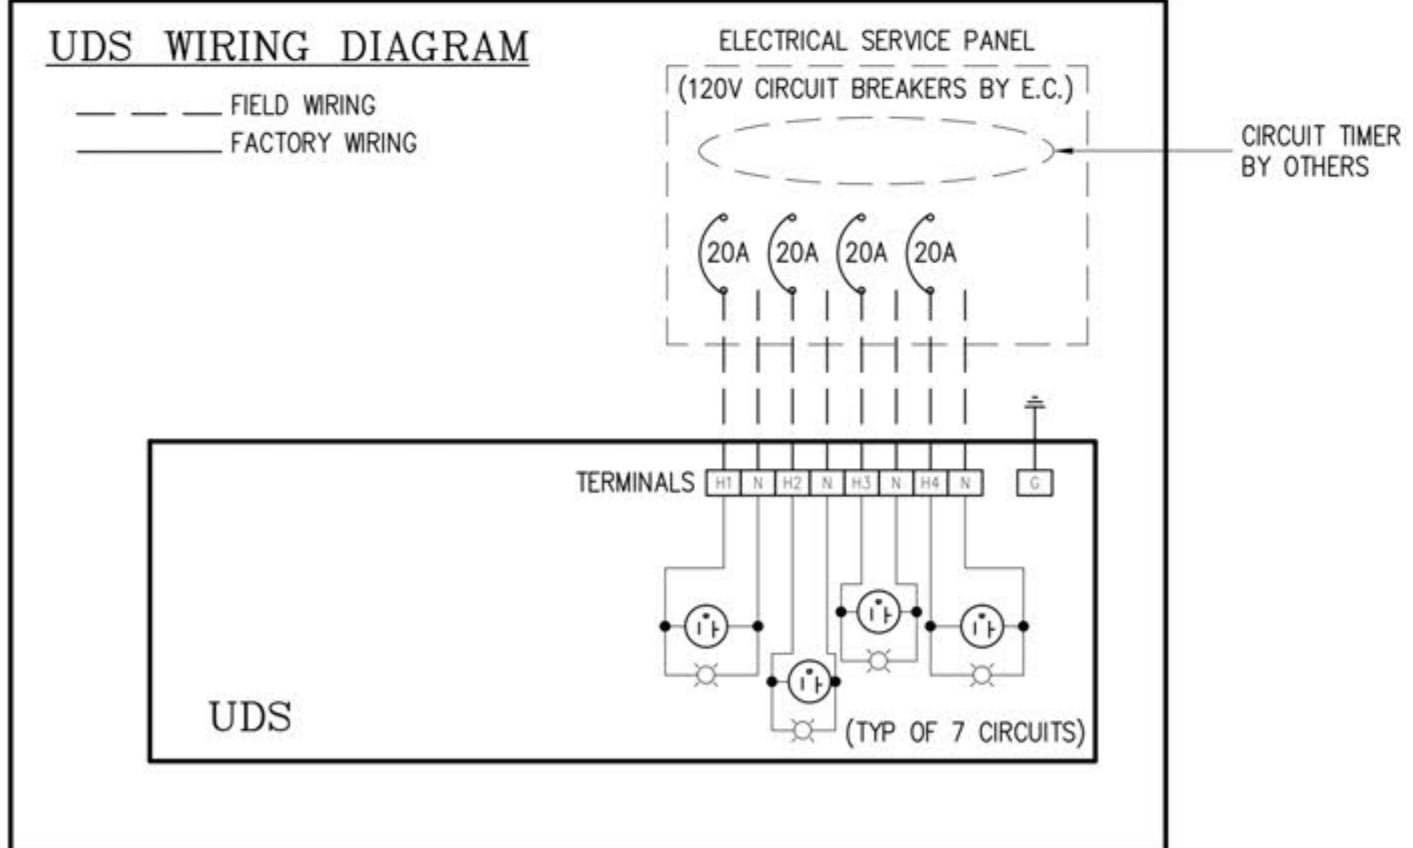

INSTALLATION INFORMATION				
01	RD	09-06-22	REVISED EQUIPMENT TO 1.8 KW, 15 AMPS	
00	EP	08-25-22	INITIAL DESIGN	
REV	DRWN BY	DATE	REVISIONS	CHECKED BY

This plan is made from available information, but measurements are to be verified by contractors, installers and others in connection with this job. Gaylord Industries accepts no responsibility for work done by contractors, installers and others, and will not stand any expense for charges made necessary by local building codes, ordinances, structural conditions or by the substitution or changes in equipment shown in this plan. This plan must be verified and approved by proper parties before fabrication can be started and approval shall not be made unless contractors, installers and others have reviewed applicable codes with code authorities. Reference is made to the general notes, which are a part of these plans and all contractors, installers and others utilizing these plans are advised they are responsible for examining and becoming familiar with said general notes before commencing any work hereunder. Any inconsistencies between these plans and the general notes, or between these plans, the general notes, and local building codes or ordinances must be immediately called to the attention of Gaylord Industries in writing so that any such inconsistencies can be resolved.

Gaylord Industries must be notified of any changes made to the plan in a clear and conspicuous manner. Gaylord Industries will not be responsible for any incidental or consequential damages incurred by others as a result of contractors, installers and others failure to notify Gaylord of changes to the plan.

ATTENTION - This plan is the property of Gaylord Industries and is confidential and proprietary. It is not to be copied, reproduced, or distributed, in whole or part, nor be used in anyway detrimental to Gaylord Industries. If you have received this plan without Gaylord's permission, please (i) do not read it, (ii) reply to the sender that you received the drawing in error, and (iii) erase and/or destroy the drawing.

GAYLORD®
INDUSTRIES

10900 S.W. AVERY ST.
TUALATIN, OR 97062

TELEPHONE: (503) 691-2010
TOLL FREE: (800) 547-9696
FAX NO.: (503) 692-6048
E-MAIL: gaylord@gaylordusa.com

DIMENSION TOLERANCE ± 1/4" (6mm)		DH-CM-E3-19.75 (T2)		UDS-2		22168902	
DRAWN BY: EP		CHECKED BY:		ELECT. CHECK:		S.E. APPROVAL:	
MODEL #		ITEM #		WORK ORDER #			
CLARINDA CORRECTIONAL FACILITY		CLARINDA, IA					
DRAWING NO.: 22-1689		DATE: 08-25-22		REV: 00		SHEET NO.: 02	





www.f-w.com
Engineers | Architects | Surveyors | Scientists

RIPPE ASSOCIATES
FOODSERVICE DESIGN + CONSULTING

 Bishop Engineering

ISSUE:		
#	DATE:	DESCRIPTION:

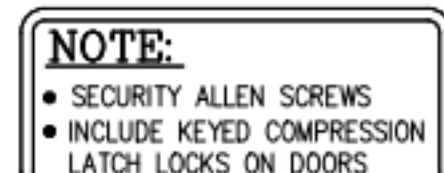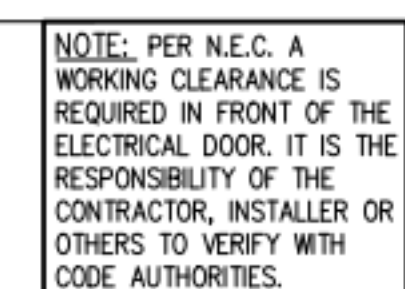

ELEVATION VIEW

[illegible]

2000 N 16TH ST, CLARINDA, IA
51632

**CLARINDA
CORRECTIONAL
FACILITY - KITCHEN &
LAUNDRY ADDITION**

DATE:	02/09/2024
DESIGNED:	EG/TP
DRAWN:	RB
REVIEWED:	EG/RB


SHEET TITLE:

**FOODSERVICE
EQUIPMENT
ELECTRICAL DETAILS
- UPS #150**

SHEET NUMBER:

FSE103

PROJECT NO.: 0240202.00
BFB922300-03

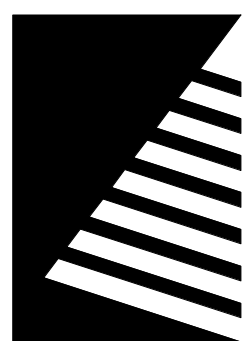

Farnsworth
GROUP

14225 UNIVERSITY AVENUE, SUITE 110
WALKEE, IOWA 50263
(515) 225-3469 / info@f-w.com

www.f-w.com
Engineers | Architects | Surveyors | Scientists

RIPPE ASSOCIATES
FOODSERVICE DESIGN + CONSULTING

kpff

IMEG

Bishop Engineering

ISSUE: # DATE: DESCRIPTION:

BID SET

PROJECT:
STATE OF IOWA DEPARTMENT
OF CORRECTIONS

CLARINDA
CORRECTIONAL
FACILITY - KITCHEN &
LAUNDRY ADDITION

2000 N 16TH ST, CLARINDA, IA
51632

DATE: 02/09/2024

DESIGNED: EG/TP

DRAWN: MM

REVIEWED: EG/RB


SHEET TITLE:
FOODSERVICE
EQUIPMENT
ELECTRICAL PLAN -
AREA 1

SHEET NUMBER:

FSE106


PROJECT NO.: 0240202.00
RFB922300-02

ELECTRICAL LEGEND	
	DR DUPLEX RECEPTACLE
	SR SINGLE RECEPTACLE
	FR FLOOR RECEPTACLE
	SW SWITCH
	V VOLTS
	AMP AMPERES
	PH PHASE
	W WATTS
	KW KILOWATT
	HP HORSEPOWER
	JB JUNCTION BOX
	EMPTY JUNCTION BOX
	+ DISTANCE ABOVE FINISHED FLOOR
	DN+ BRING SERVICE DOWN FROM ABOVE
	CEILING TO A DISTANCE ABOVE FINISHED FLOOR
	COMP COMPRESSOR
	MOTOR
	SOLENOID
	DATA OUTLET
	VOICE OUTLET
	AFF ABOVE FINISHED FLOOR
	CLG CEILING
	DFA DOWN FROM ABOVE
	ET ELECTRICAL TRADES
	FSEC FOODSERVICE EQUIPMENT CONTRACTOR

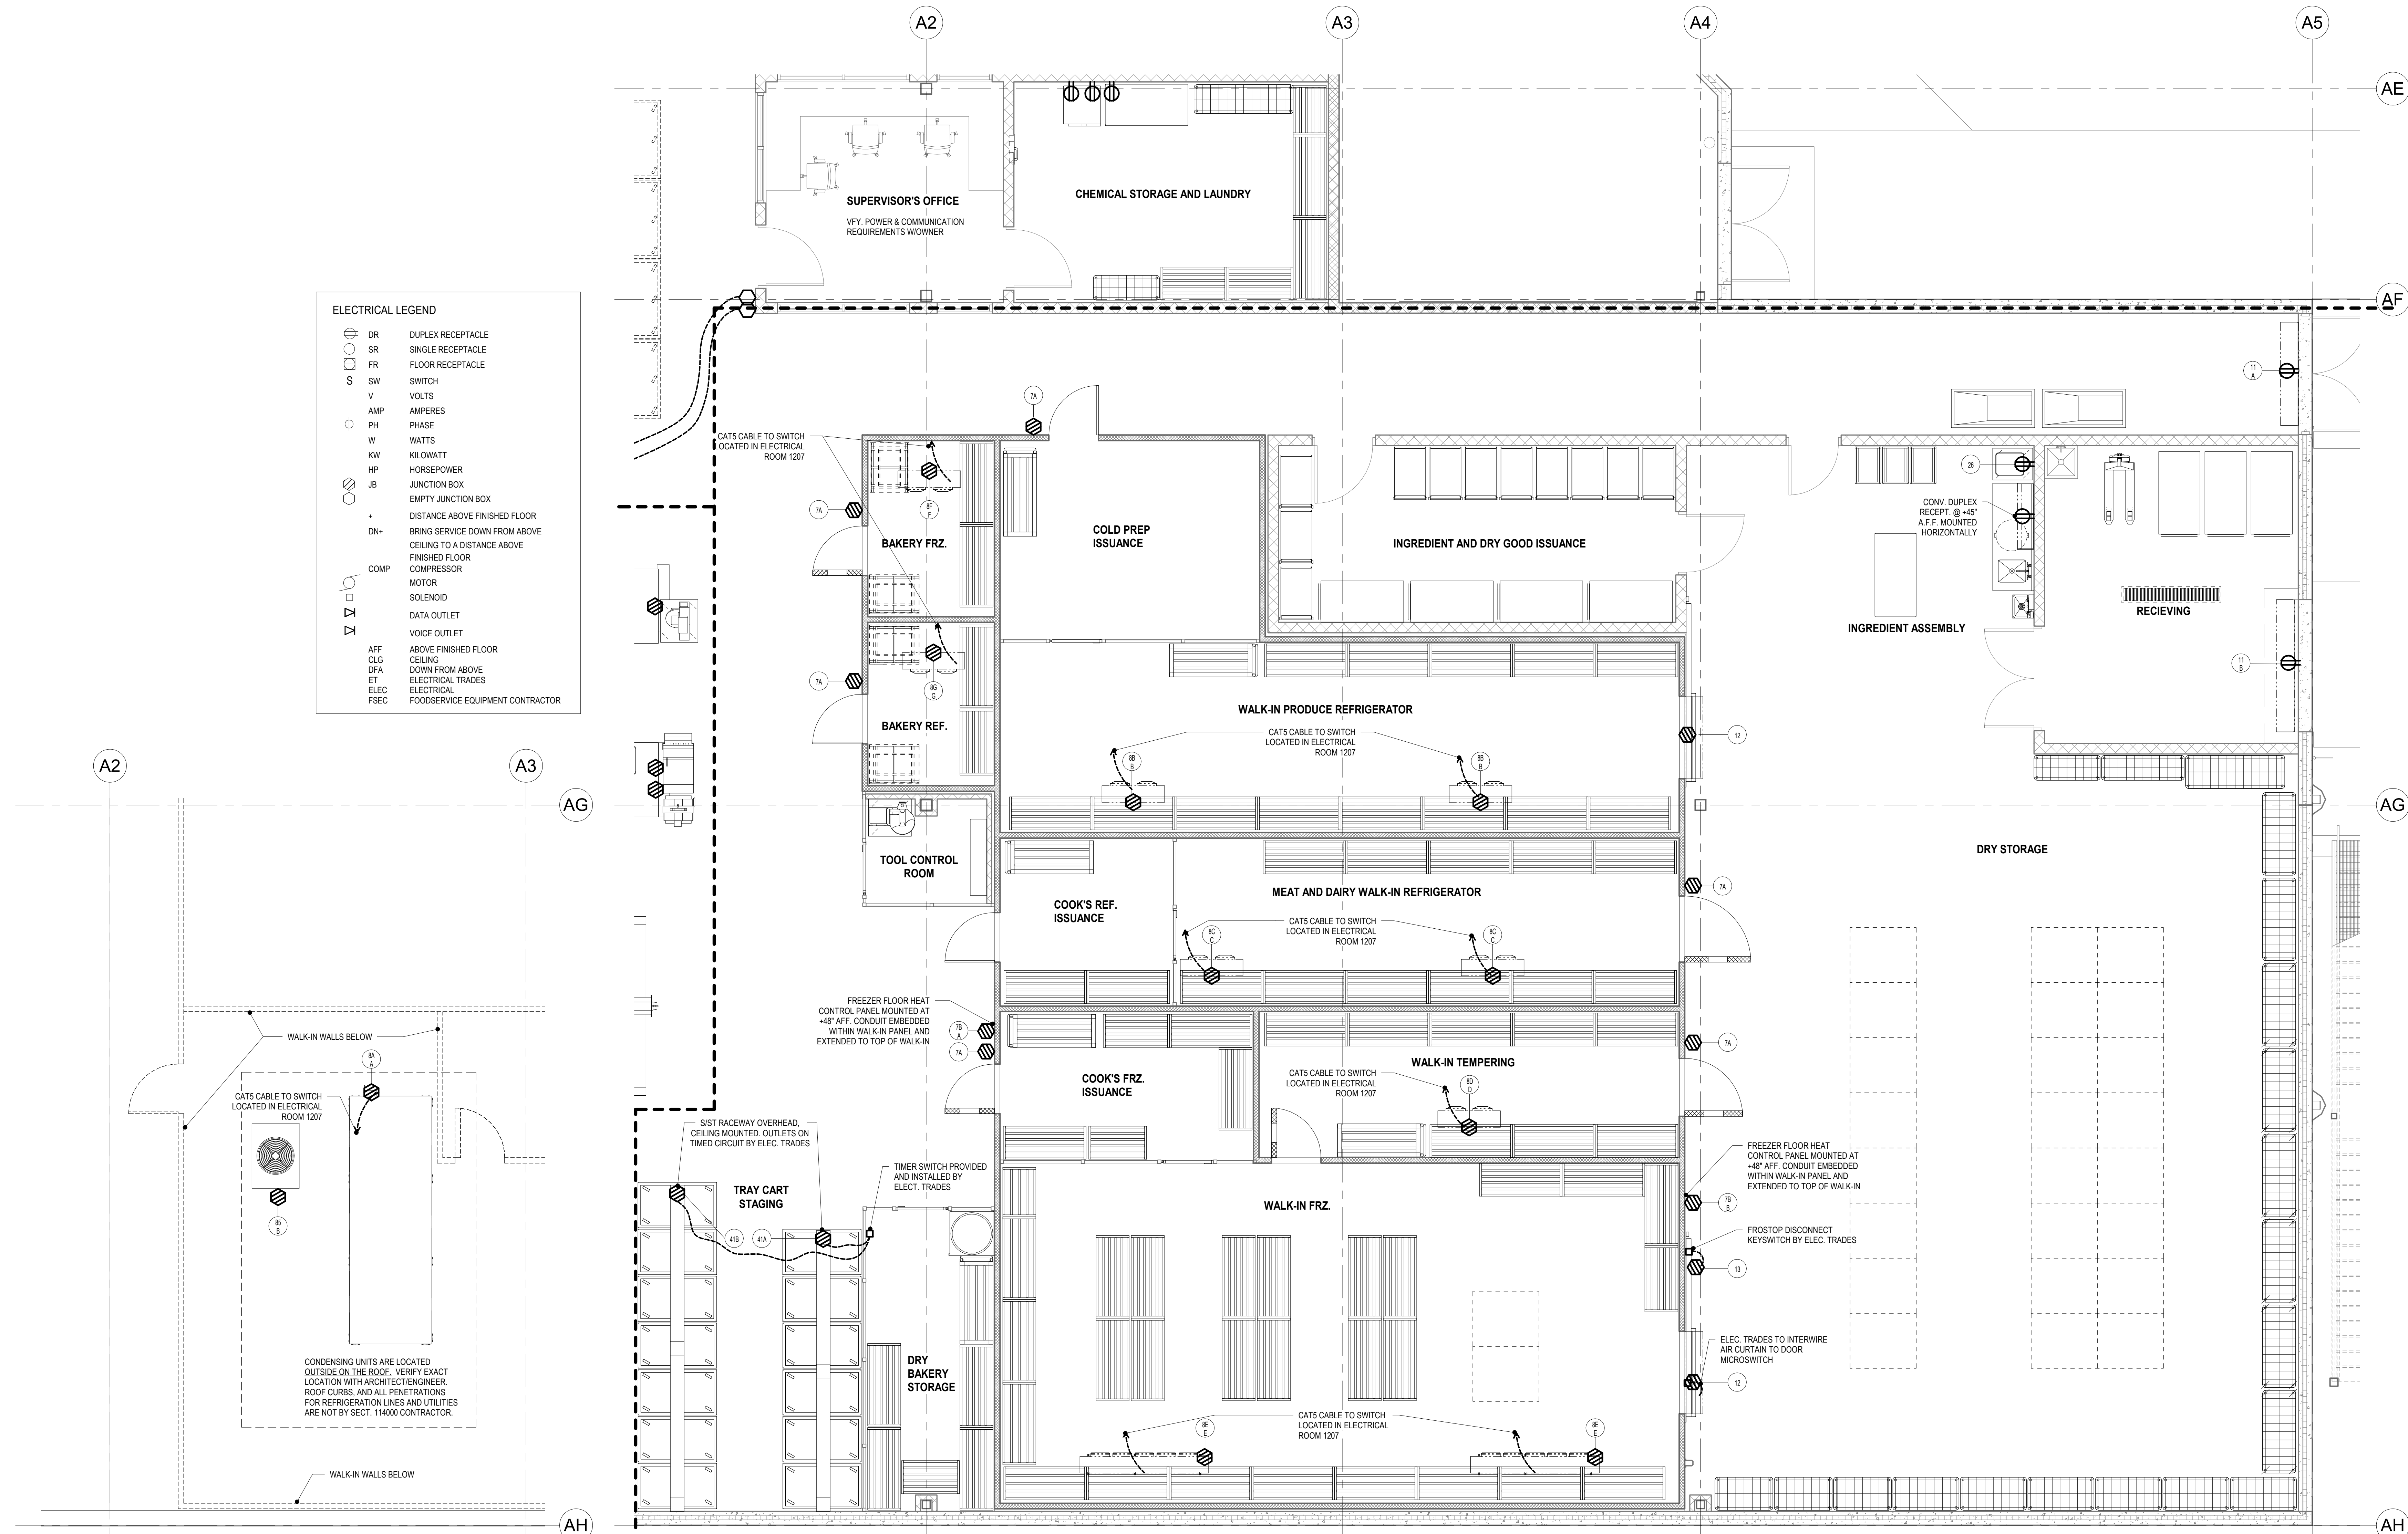

2 FOODSERVICE ELECTRICAL PLAN - ROOF
1/4" = 1'-0"

1 FOODSERVICE ELECTRICAL PLAN - AREA 1
1/4" = 1'-0"

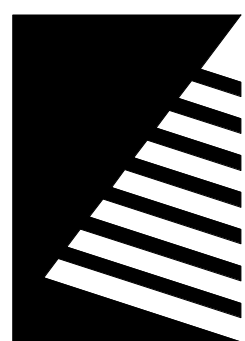

Farnsworth
GROUP

14225 UNIVERSITY AVENUE, SUITE 110
WALKEE, IOWA 50263
(515) 225-3469 / info@f-w.com

www.f-w.com
Engineers | Architects | Surveyors | Scientists

RIPPE ASSOCIATES
FOODSERVICE DESIGN + CONSULTING

kpff

IMEG

Bishop Engineering

ISSUE:
DATE: DESCRIPTION:

BID SET

PROJECT:
STATE OF IOWA DEPARTMENT
OF CORRECTIONS

CLARINDA
CORRECTIONAL
FACILITY - KITCHEN &
LAUNDRY ADDITION

2000 N 16TH ST, CLARINDA, IA
51632

DATE: 02/09/2024

DESIGNED: EG/TP

DRAWN: MM

REVIEWED: EG/RB


SHEET TITLE:

FOODSERVICE
EQUIPMENT
ELECTRICAL PLAN -
AREA 2

SHEET NUMBER:


FSE107

PROJECT NO.: 0240202.00
RFB922300-02

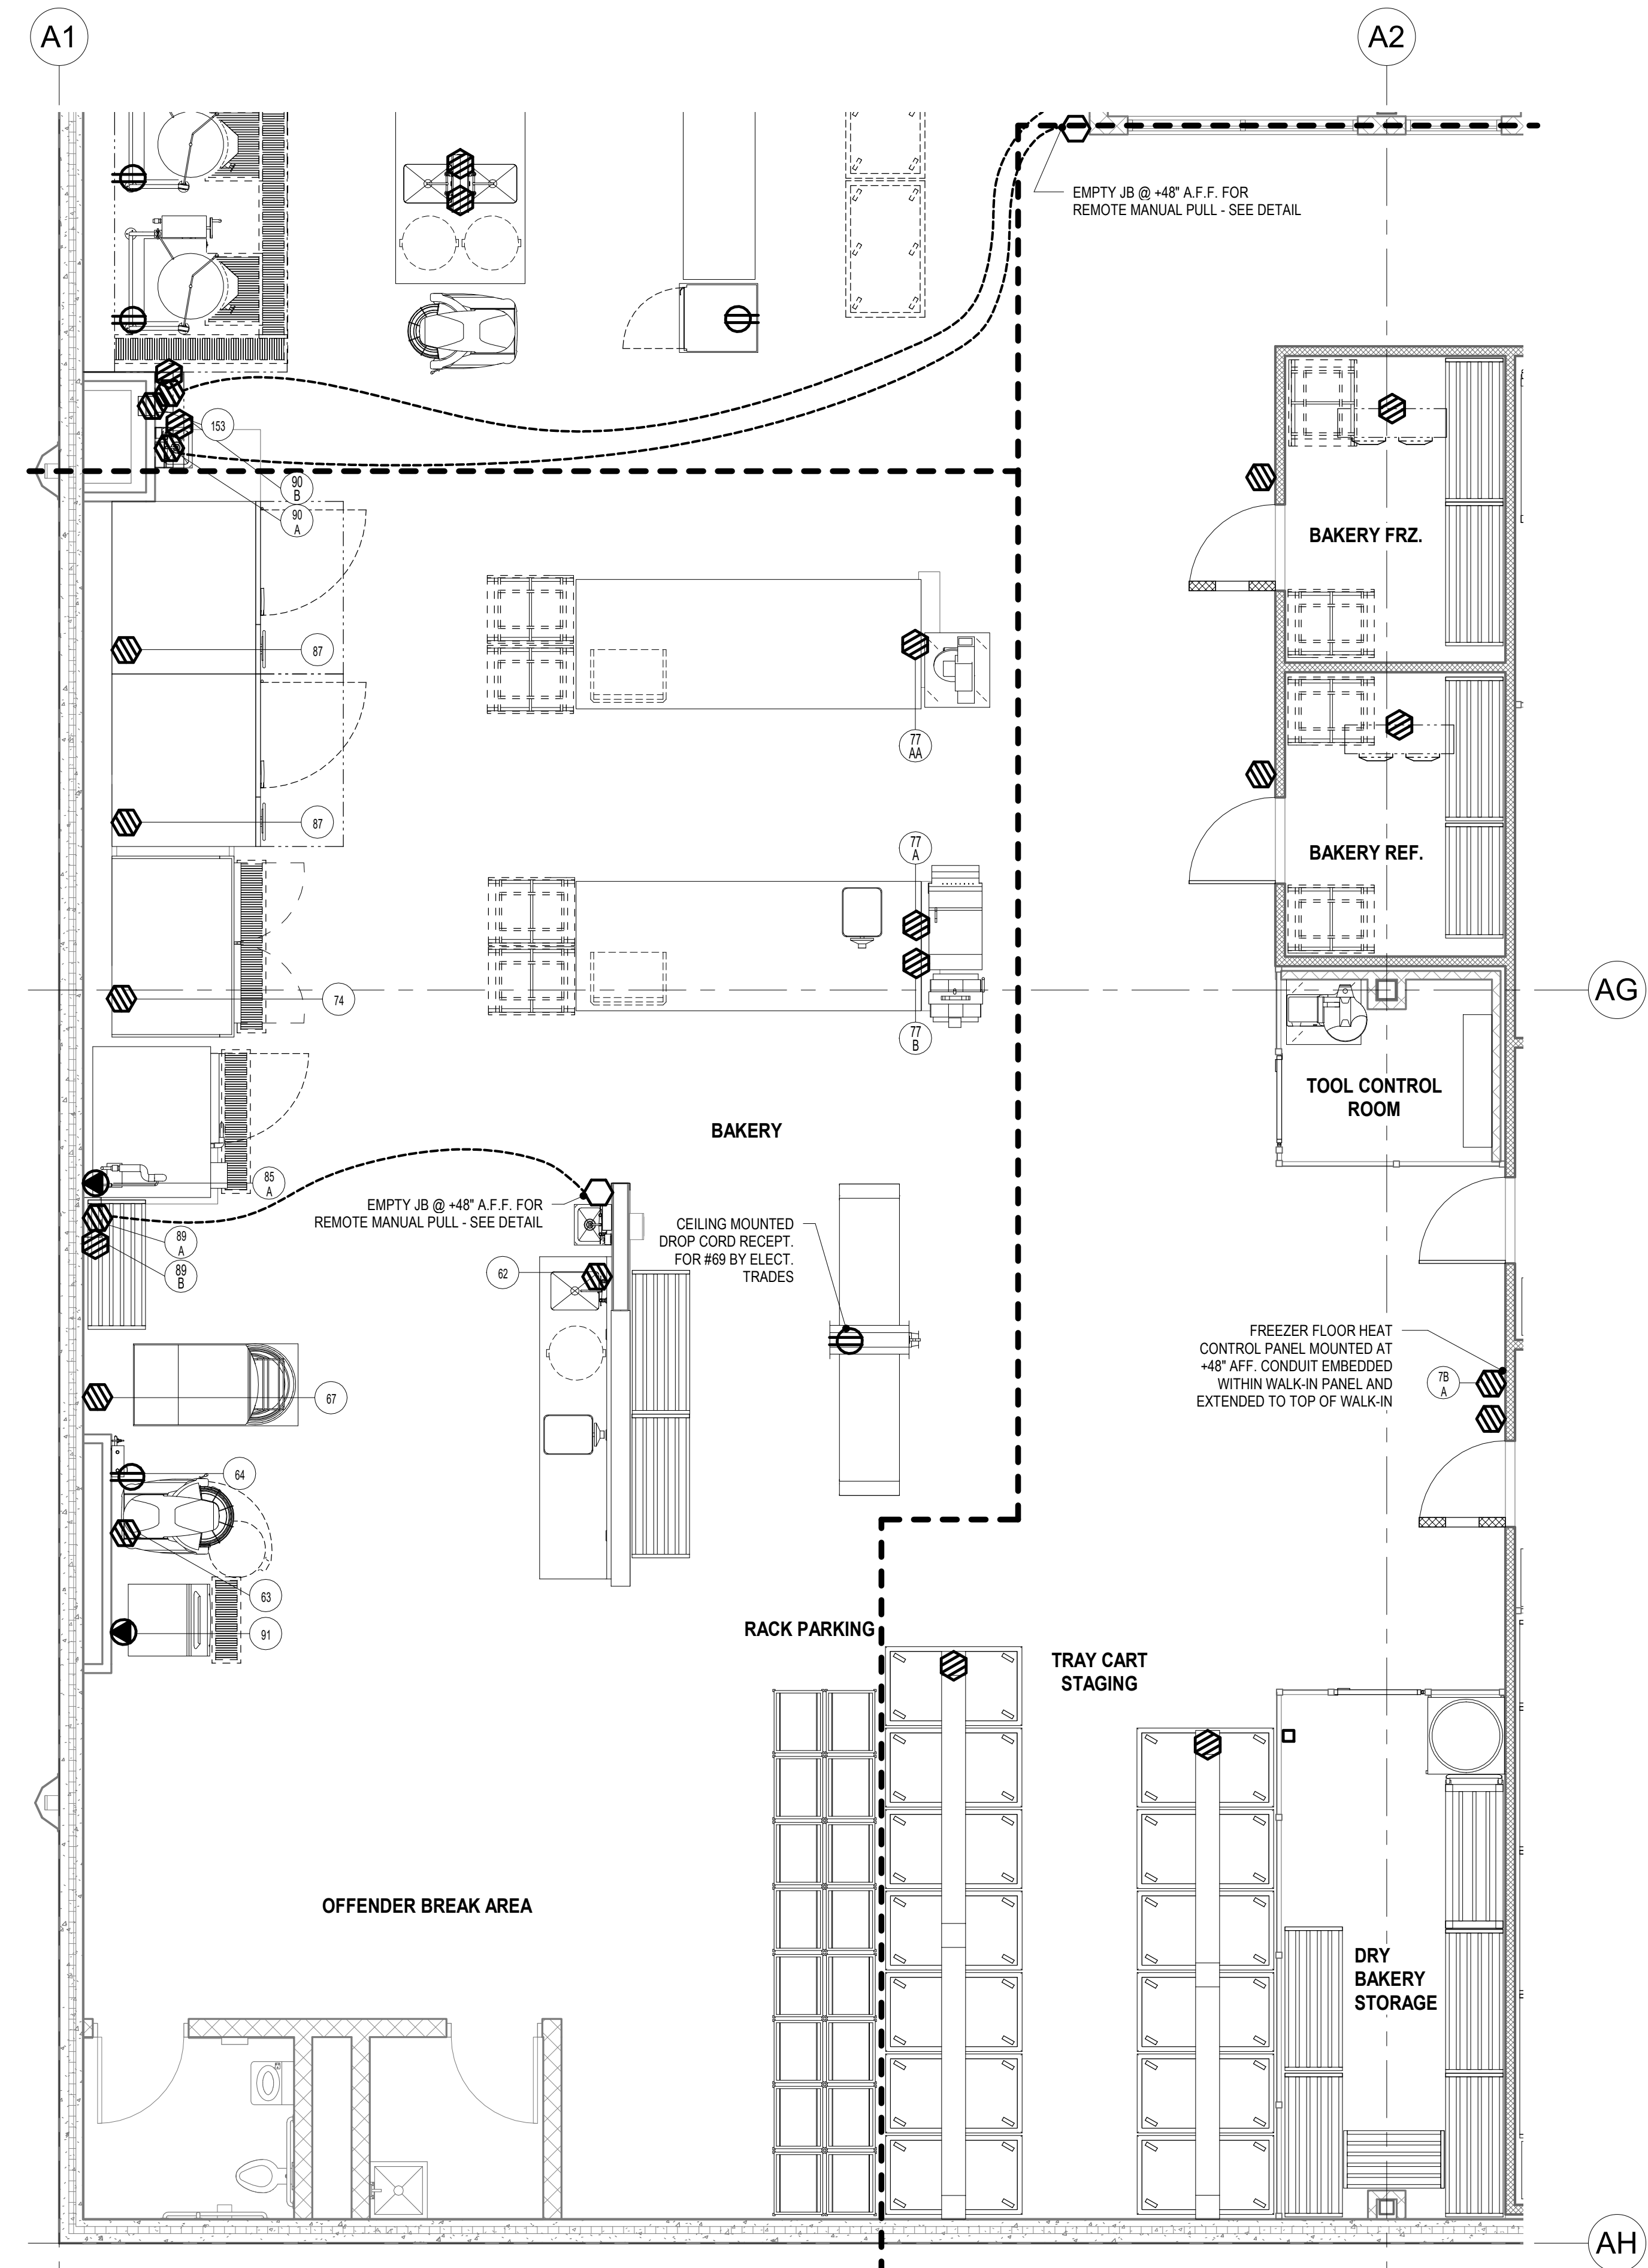

ELECTRICAL LEGEND	
	DR DUPLEX RECEPTACLE
	SR SINGLE RECEPTACLE
	FR FLOOR RECEPTACLE
	SW SWITCH
	V VOLTS
	AMP AMPERES
	PH PHASE
	W WATTS
	KW KILOWATT
	HP HORSEPOWER
	JB JUNCTION BOX
	EMPTY JUNCTION BOX
	+ DISTANCE ABOVE FINISHED FLOOR
	DN+ BRING SERVICE DOWN FROM ABOVE
	CEILING TO A DISTANCE ABOVE FINISHED FLOOR
	COMP COMPRESSOR
	MOTOR
	SOLENOID
	DATA OUTLET
	VOICE OUTLET
	AFF ABOVE FINISHED FLOOR
	CLG CEILING
	DFA DOWN FROM ABOVE
	ET ELECTRICAL TRADES
	ELEC ELECTRICAL
	FSEC FOODSERVICE EQUIPMENT CONTRACTOR

1 FOODSERVICE ELECTRICAL PLAN - AREA 2
1/4" = 1'-0"

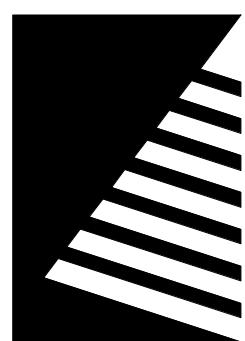

Farnsworth
GROUP

14225 UNIVERSITY AVENUE, SUITE 110
WALKEE, IOWA 50263
(515) 225-3469 / info@f-w.com

www.f-w.com
Engineers | Architects | Surveyors | Scientists

RIPPE ASSOCIATES
FOODSERVICE DESIGN + CONSULTING

kpff

IMEG

Bishop Engineering

ISSUE:
DATE: DESCRIPTION:

BID SET

PROJECT:
STATE OF IOWA DEPARTMENT
OF CORRECTIONS

CLARINDA
CORRECTIONAL
FACILITY - KITCHEN &
LAUNDRY ADDITION

2000 N 16TH ST, CLARINDA, IA
51632

DATE: 02/09/2024

DESIGNED: EG/TP

DRAWN: MM

REVIEWED: EG/RB


SHEET TITLE:

FOODSERVICE
EQUIPMENT
ELECTRICAL PLAN -
AREA 3

SHEET NUMBER:

FSE108

PROJECT NO.: 0240202.00
RFB922300-02

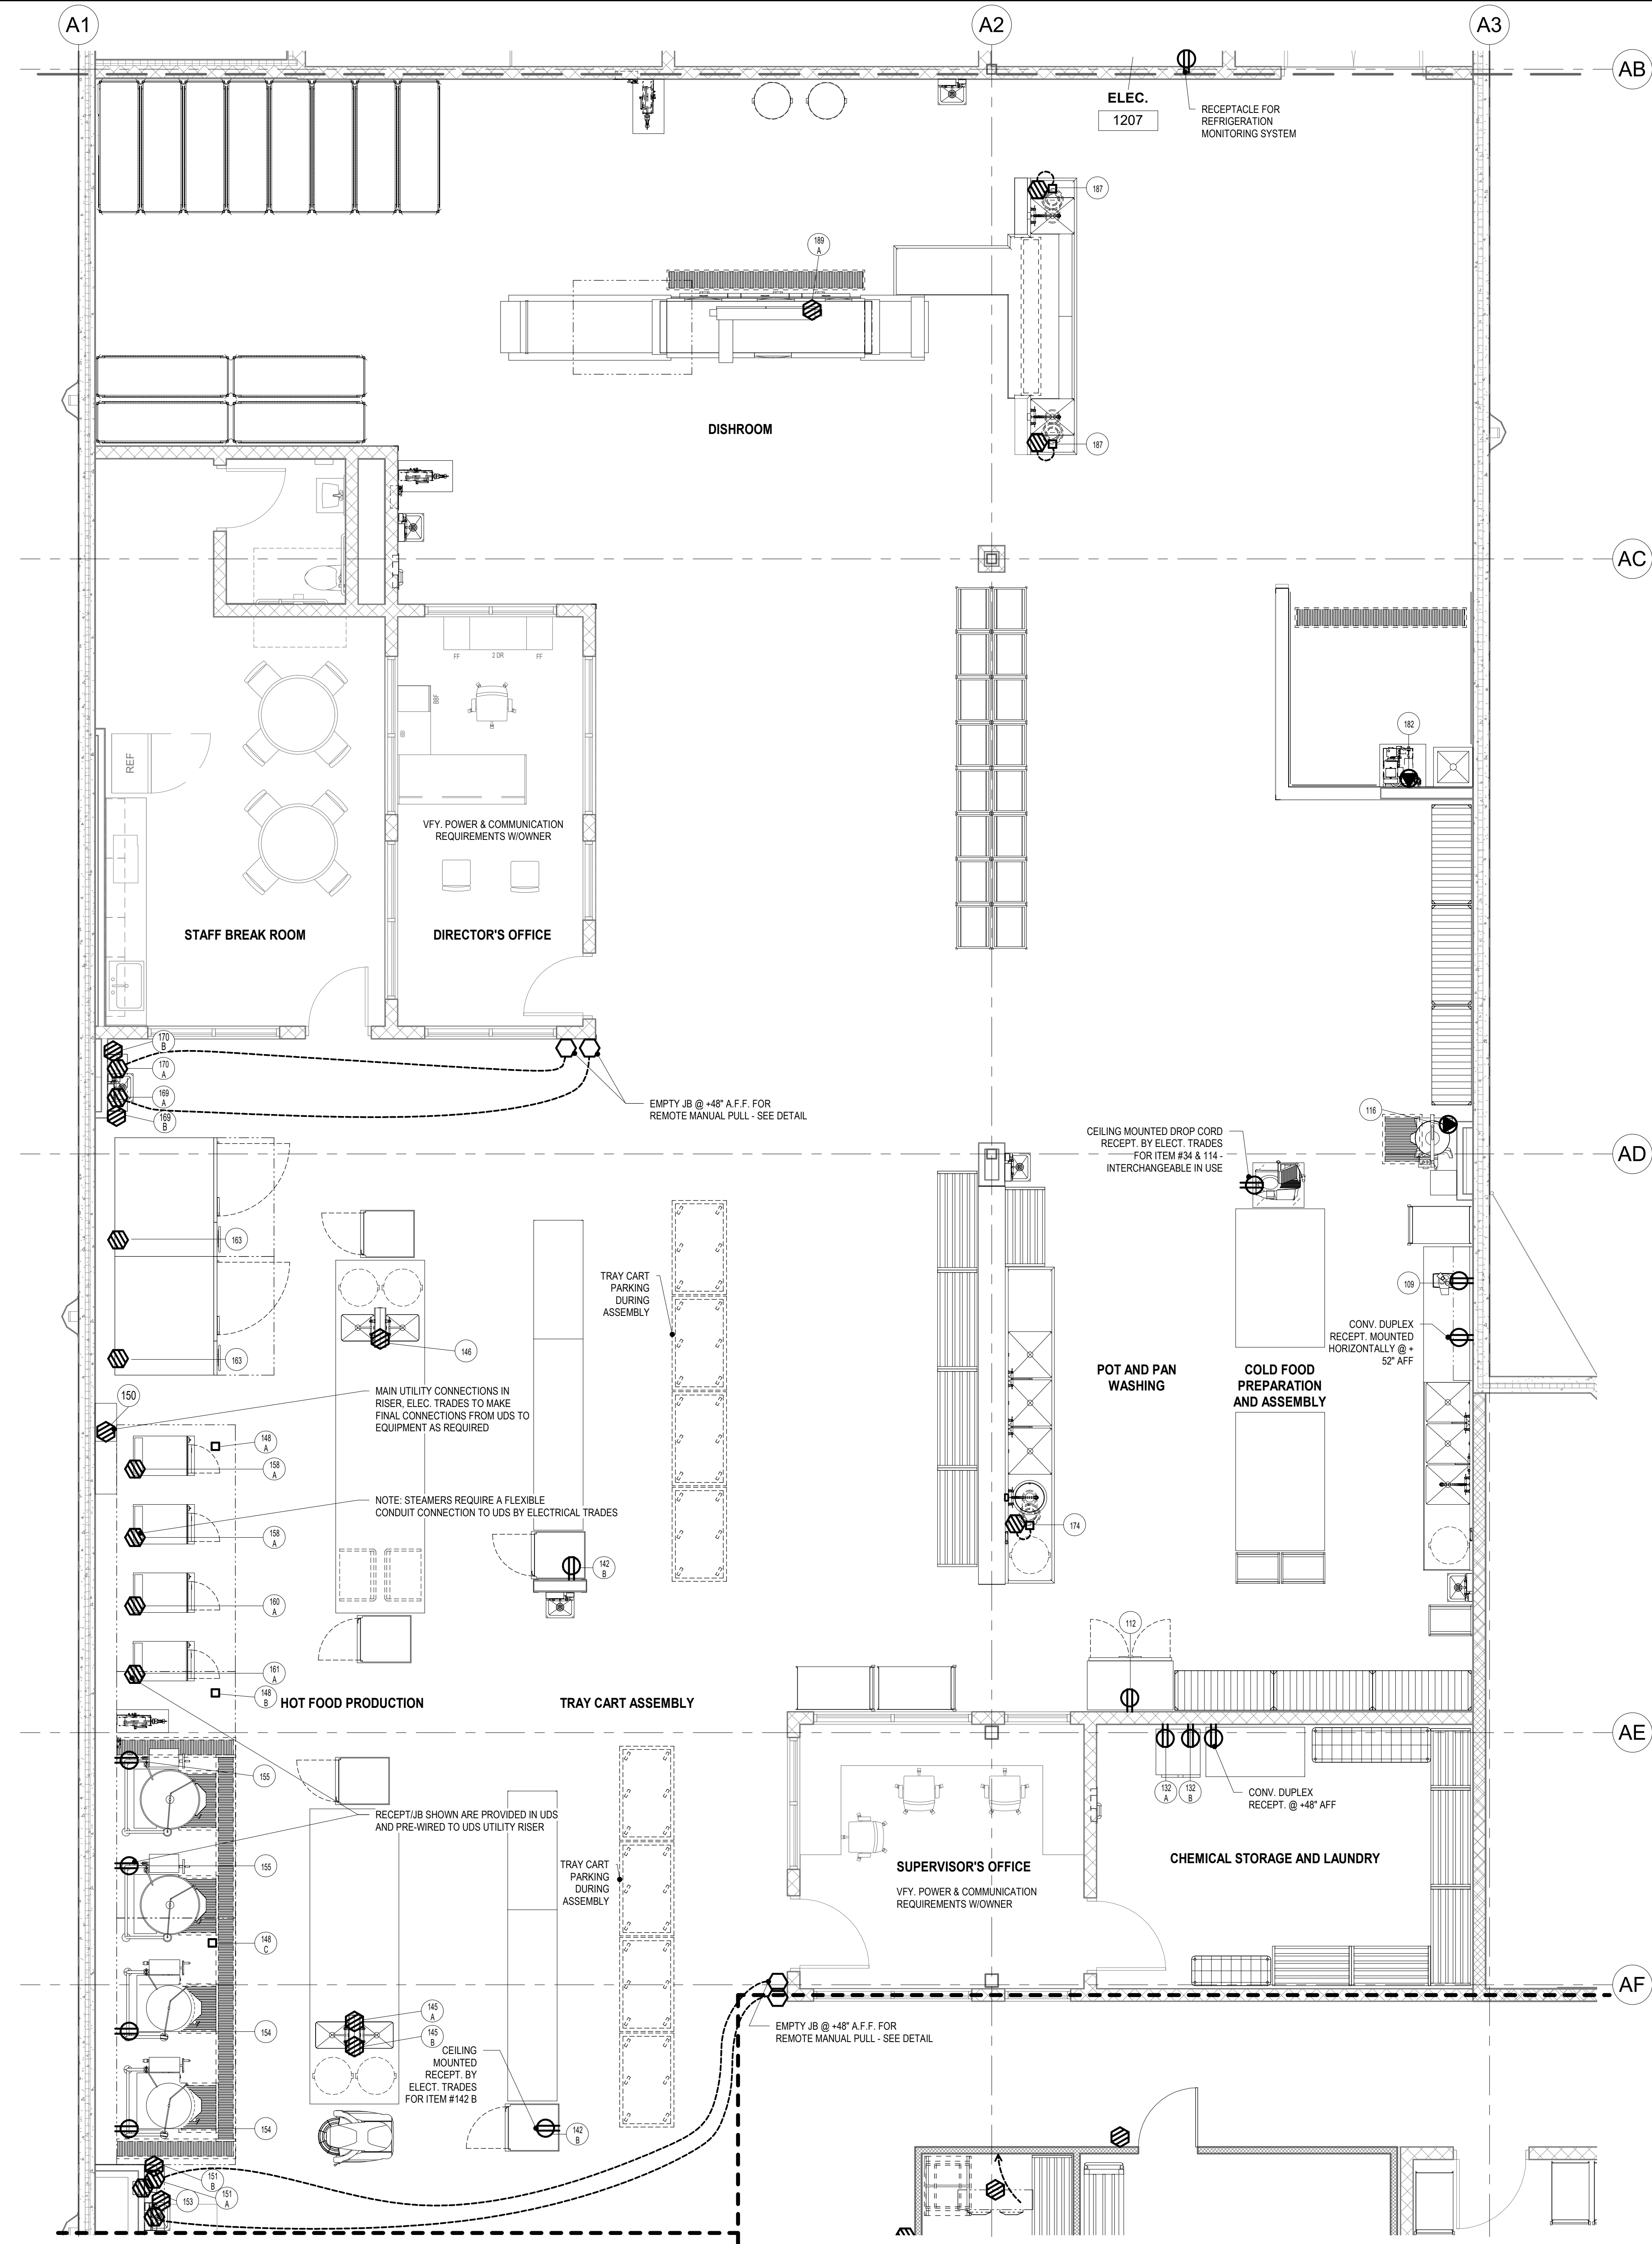

ELECTRICAL LEGEND	
	DR DUPLEX RECEPTACLE
	SR SINGLE RECEPTACLE
	FR FLOOR RECEPTACLE
	SW SWITCH
	V VOLTS
	AMP AMPERES
	PH PHASE
	W WATTS
	KW KILOWATT
	HP HORSEPOWER
	JB JUNCTION BOX
	EMPTY JUNCTION BOX
	+ DISTANCE ABOVE FINISHED FLOOR
	DN+ BRING SERVICE DOWN FROM ABOVE
	CEILING TO A DISTANCE ABOVE
	COMP FINISHED FLOOR COMPRESSOR
	MOTOR
	SOLENOID
	DATA OUTLET
	VOICE OUTLET
	AFF ABOVE FINISHED FLOOR
	CLG CEILING
	DFA DOWN FROM ABOVE
	ET ELECTRICAL TRADES
	ELEC ELECTRICAL
	FSEC FOODSERVICE EQUIPMENT CONTRACTOR

1 FOODSERVICE ELECTRICAL PLAN - AREA 3
1/4" = 1'-0"

FOODSERVICE EQUIPMENT MECHANICAL SCHEDULE														
ITEM #	DESCRIPTION		DIRECT WASTE SIZE	DIRECT WASTE HEIGHT	INDIRECT WASTE SIZE	COLD WATER SIZE	COLD WATER HEIGHT	HOT WATER SIZE	HOT WATER HEIGHT	GAS SIZE	GAS HEIGHT	GAS INPUT MBTU/HR	W.C.	REMARKS
8A	RACKED REFRIGERATION SYSTEM	A												NOTE M
8B	REFRIGERATION SYSTEM COIL - PRODUCE REFRIGERATOR	B			1"									NOTE G
8C	REFRIGERATION SYSTEM COIL - MEAT & DAIRY REFRIGERATOR	C			1"									NOTE G
8D	REFRIGERATION SYSTEM COIL - TEMPERING REFRIGERATOR	D			1"									NOTE G
8E	FREEZER SYSTEM COIL - MAIN FREEZER	E			1"									NOTE G
8F	FREEZER SYSTEM COIL - BAKERY FREEZER	F			1"									NOTE G
8G	REFRIGERATION SYSTEM COIL - BAKERY REFRIGERATOR	G			1"									NOTE G
18	HAND SINK		1 1/2"	22"		1/2"	24"	1/2"	24"					
20	FLOOR TROUGH		4"	-4"										FURNISHED BY FSEC / INSTALLED BY MECH TRADES
22	WORKCOUNTER W/SINK				2"	1/2"	22"	1/2"	22"					(1) CW & HW CONNECTION / (1) INDIRECT WASTE CONNECTION
62	WORKCOUNTER W/SINK				2"	1/2"	22"	1/2"	22"					(1) CW & HW CONNECTION / (1) INDIRECT WASTE CONNECTION
64	WATER METER W/TEMPERATURE RANGE					1/2"	72"	1/2"	72"					NOTE D / TREATED CW FROM BLDG RO SYSTEM / ADD ALTERNATE / MECHANICAL TRADES TO ROUGH IN AND CAP AS NEEDED
68	HAND SINK		1 1/2"	22"		1/2"	24"	1/2"	24"					
74	ROLL-IN PROOFER, 2 DOUBLE RACKS				3/4"	1/2"	90"							NOTE D & E / TREATED CW BLDG RO SYSTEM / ADD ALTERNATE / MECHANICAL TRADES TO ROUGH IN AND CAP AS NEEDED
75	FLOOR TROUGH		4"	-4"										FURNISHED BY FSEC / INSTALLED BY MECH TRADES
85	ROLL-IN BLAST CHILLER	A			1 1/2"									
87	RACK OVEN, 2-SEC.				3/4"	1/2"	100"			1"	90"	290	5.0"	NOTE D, E, H, I, J, V, W & X / TREATED CW BLDG RO SYSTEM / 40 PSI MIN @ 9 GPM / WATER HARDNESS 2-4 GPG / VFY UTILITIES W/OWNER
89	FIRE PROTECTION SYSTEM	A												NOTE J / SEE DETAIL / TO SERVE ITEM (1) #87
90	FIRE PROTECTION SYSTEM	A												NOTE J / SEE DETAIL / TO SERVE ITEM (1) #87
91	ICE MAKER				1/2"	3/8"	54"							NOTE D / TREATED CW FROM BLDG RO SYSTEM
92	ICE BIN				3/4"									
93	FLOOR TROUGH		4"	-4"										FURNISHED BY FSEC / INSTALLED BY MECH TRADES
100	HAND SINK		1 1/2"	22"		1/2"	24"	1/2"	24"					
104	WORKCOUNTER W/SINKS				2"	1/2"	22"	1/2"	22"					(2) CW & HW CONNECTIONS / (3) DIRECT WASTE CONNECTIONS
107	SPRAY RINSE					3/4"	20"	1/2"	20"					
117	FLOOR TROUGH		4"	-4"										FURNISHED BY FSEC / INSTALLED BY MECH TRADES
118	HOSE STATION					1/2"	48"	1/2"	48"					
132	STACKED WASHER/DRYER	A			1 1/4"	1/2"	48"	3/4"	48"	3/8"	30"	22	5.0"	NOTE I, V & W / DRAIN TO STANDPIPE IN WALL
145	WORKCOUNTER W/SINKS					1/2"	10"	1/2"	10"					(2) CW & HW CONNECTIONS / (2) INDIRECT WASTE CONNECTIONS
146	WORKCOUNTER W/SINKS				2"	1/2"	10"	1/2"	10"					(2) CW & HW CONNECTIONS / (2) INDIRECT WASTE CONNECTIONS
150	UTILITY DISTRIBUTION SYSTEM					1"	110"	1"	110"	3"	110"	1260	7.0"	DFA / NOTE S / 3/4" FILTERED CW FROM BUILDING RO SYSTEM
151	FIRE PROTECTION SYSTEM	A												NOTE J / SEE DETAIL / TO SERVE ITEM #148
154	60 GALLON KETTLE					1/2"	24"	1/2"	24"	3/4"	30"	190	4.0"	NOTE I, J, V & W
155	80 GALLON KETTLE					1/2"	24"	1/2"	24"	3/4"	30"	190	4.0"	NOTE I, J, V & W
156	FLOOR TROUGH		4"	-4"										FURNISHED BY FSEC / INSTALLED BY MECH TRADES
158	STEAMER, 2-SEC.	A			1 1/2"	3/4"	24"			3/4"	30"	125	4.0"	NOTE D, E, H, I, J, V, W & X / (1) TREATED CW CONNECTION FROM BLDG RO SYSTEM @ 35-60 PSI
158	STEAMER, 2 SEC.	B				3/4"	24"							NOTE D & X / (1) UNFILTERED CW CONNECTION @ 35-60 PSI
160	STEAMER, 2-SEC.	A			1 1/2"	3/4"	24"			3/4"	30"	125	4.0"	NOTE D, E, H, I, J, V & W / (1) TREATED CW CONNECTION FROM BLDG RO SYSTEM @ 20-60 PSI
160	STEAMER, 2 SEC.	B				3/4"	24"							NOTE D & X / (1) UNFILTERED CW CONNECTION @ 20-60 PSI
161	STEAMER, 2-SEC.	A			1 1/2"	3/4"	24"			3/4"	30"	125	4.0"	NOTE D, E, H, I, J, V & W / (1) TREATED CW CONNECTION FROM BLDG RO SYSTEM @ 35-60 PSI
161	STEAMER, 2 SEC.	B				3/4"	24"							NOTE D / (1) UNFILTERED CW CONNECTION @ 35-60 PSI
162	HOSE REEL					1/2"	44"	1/2"	44"					NOTE D / SEE DETAIL
163	RACK OVEN, 2-SEC.				3/4"	1/2"	100"			1"	102"	290	5.0"	NOTE D, E, H, I, J, V, & W / TREATED CW FROM BLDG RO SYSTEM / 40 PSI MIN @ 9 GPM / WATER HARDNESS 2-4 GPG
169	FIRE PROTECTION SYSTEM	A												NOTE J / SEE DETAIL / TO SERVE ITEM (1) #163
170	FIRE PROTECTION SYSTEM	A												NOTE J / SEE DETAIL / TO SERVE ITEM (1) #163
173	POT & PAN SINK		2"	10"		3/4"	18"	3/4"	18"					NOTE Y / (2) CW & HW CONNECTIONS / (3) DIRECT WASTE CONNECTIONS
174	DISPOSER		2"	10"										NOTE A & B / SEE DETAIL / TEE-OFF 1/2" CW FROM #175
175	SPRAY RINSE					3/4"	20"	1/2"	20"					BRANCH 1/2" CW TO ITEM #174
182	HOSE STATION					3/4"	12"							HOSE BIB W/ 2.1 GPM MIN. @ 30 PSI MIN. / 120°F INCOMING HW
183	FLOOR TROUGH		4"	-4"										FURNISHED BY FSEC / INSTALLED BY MECH TRADES
184	HOSE REEL					1/2"	44"	1/2"	44"					NOTE D / SEE DETAIL
185	EYE/FACE WASH STATION		2"	24"		1/2"	29"	1/2"	29"					MIXING VALVE FURNISHED BY FSEC / INSTALLED BY MECH TRADES
187	DISPOSER		2"	10"										NOTES A & B / SEE DETAIL / TEE-OFF 1/2" CW FROM #191
189	FLIGHT-TYPE DISHMACHINE W/DRYER	A			2"	3/4"	6"	1"	6"					NOTE F & Q
189	FLIGHT-TYPE DISHMACHINE W/DRYER	B			2"									UNLOAD END
191	SPRAY RINSE					3/4"	20"	1/2"	20"					BRANCH 1/2" CW TO ITEM #187
192	FLOOR TROUGH		4"	-4"										FURNISHED BY FSEC / INSTALLED BY MECH TRADES
194	FLOOR TROUGH		4"	-4"										FURNISHED BY FSEC / INSTALLED BY MECH TRADES

FOODSERVICE EQUIPMENT EXHAUST SCHEDULE												
ITEM #	DESCRIPTION		VOLUME	VENT DEPTH	VENT WIDTH	VENT DIAMETER	STATIC PRESSURE	RI HEIGHT	FAN #	FIRE PROTECTION ITEM #	DVC ITEM #	REMARKS
87	RACK OVEN, 2-SEC.		800 CFM			8"	0.300	104"		89	N/A	NOTE X & Z / DIRECTLY VENTED
87	RACK OVEN, 2-SEC.		800 CFM			8"	0.300	104"		90	N/A	NOTE X & Z / DIRECTLY VENTED
132	STACKED WASHER/DRYER		220 CFM			4"		48"		N/A	N/A	
148	EXHAUST HOOD	L1	1422 CFM	12"	12"		1.105	116"	1	151	153	
148	EXHAUST HOOD	L1	1777 CFM	12"	15"		1.170	116"	1	151	153	
148	EXHAUST HOOD	L1	1777 CFM	12"	15"		1.170	116"	1	151	153	
148	EXHAUST HOOD	R1	1422 CFM	12"	12"		1.105	116"	1	151	153	
148	EXHAUST HOOD	R1	1777 CFM	12"	15"		1.170	116"	1	151	153	
148	EXHAUST HOOD	R1	1777 CFM	12"	15"		1.170	116"	1	151	153	
163	RACK OVEN, 2-SEC.		800 CFM			8"	0.300	104"		169	N/A	NOTE Z / DIRECTLY VENTED
163	RACK OVEN, 2-SEC.		800 CFM			8"	0.300	104"		170	N/A	NOTE Z / DIRECTLY VENTED
190	EXHAUST DUCT RISER		300 CFM	31 1/2"	4"		0.250	132"	2	N/A	N/A	CAPTURES LOAD END OF DISHMACHINE
195	CONDENSATE HOOD		2400 CFM	20"	12"		0.250	106 1/2"	2	N/A	N/A	CAPTURES UNLOAD END OF DISHMACHINE

FOODSERVICE EQUIPMENT DISHMACHINE SCHEDULE					
ITEM #	DESCRIPTION	GPH	APPROX. HOUR	LATENT HEAT	SENSIBLE HEAT
189	FLIGHT-TYPE DISHMACHINE W/DRYER	58	6	85000	36400


MECHANICAL LEGEND	
○	CW COLD WATER
○	HW HOT WATER
○	W DIRECT WASTE
○	AGW AIR GAP WASTE
○	IW INDIRECT WASTE
⊠	FD FLOOR DRAIN
⊠	FS FLOOR SINK
⊠	FSH FLOOR SINK w/HALF DRAIN
⊠	TTFD TELL-TALE FLOOR DRAIN
⊠	CR STEAM
⊠	S CONDENSATE RETURN
⊠	G GAS
⊠	CWR COOLING TOWER / CHILLED WATER SUPPLY/RETURN
⊠	A COMRESSED AIR
⊠	CO2
⊠	EXHAUST
⊠	SUPPLY
⊠	ABOVE FINISHED FLOOR
⊠	CLG DOWN FROM ABOVE
⊠	DFA FOODSERVICE EQUIPMENT CONTRACTOR
⊠	OW OUT OF WALL
⊠	MECHANICAL TRADES
⊠	PLUMBING
⊠	WC WATER COLUMN

GENERAL NOTES - MECHANICAL

- NOTE: GENERAL NOTES REFER TO GENERAL CONDITIONS. ALL CONDITIONS MAY NOT EXIST ON THIS PROJECT.
- THESE DRAWINGS ARE FOR USE BY THE PROJECT ENGINEERS IN PREPARING THEIR DRAWINGS. THESE DRAWINGS ARE INCIDENTAL TO OUR SERVICES AND MUST BE REVIEWED AND APPROVED BY A PROPERLY LICENSED DESIGN PROFESSIONAL BEFORE BEING USED FOR ANY OTHER PURPOSES. RIPPE ASSOCIATES IS NOT LICENSED AS A DESIGN PROFESSIONAL AND DOES NOT HOLD ITSELF OUT AS SUCH.
 - SERVICES SHOWN ON THIS PLAN ARE EQUIPMENT REQUIREMENTS FOR FOODSERVICE EQUIPMENT ONLY. LOCATIONS, SIZES AND HEIGHTS ABOVE FINISHED FLOOR ARE APPROXIMATELY AS REQUIRED BY EQUIPMENT TO BE FURNISHED. SINCE MULTIPLE SOURCES FOR THE EQUIPMENT MAY BE SPECIFIED, SLIGHT VARIATIONS IN UTILITY LOADS AND CONNECTION SIZES CAN OCCUR. DESIGN BUILDING UTILITY SYSTEM ACCORDINGLY AND ADD NOTES TO THE MECHANICAL CONTRACT DOCUMENTS INDICATING SLIGHT VARIATIONS ARE TO BE INCLUDED IN THE MECHANICAL TRADES WORK AT NO ADDITIONAL COST.
 - THESE DRAWINGS ARE NOT TO BE USED TO ROUGH-IN UTILITIES AND/OR LOCATE SLEEVES, SINCE REQUIRED ALLOWANCES MUST BE MADE FOR MULTIPLE EQUIPMENT SOURCES AND FOR VALVES, TRAPS, FITTINGS, DISCONNECTS, ETC. WHICH WILL BE FURNISHED UNDER MECHANICAL TRADES. FSEC IS RESPONSIBLE FOR PREPARING DIMENSIONED ROUGH-IN AND SLEEVE LOCATION PLAN PER SPECIFICATIONS TO ACCOMMODATE THE EXACT EQUIPMENT BEING PROVIDED.
 - MECHANICAL TRADES TO PROVIDE ALL NECESSARY SHUT-OFF VALVES, PRESSURE REGULATORS, INDIVIDUAL EQUIPMENT SUPPLY STOPS, ETC. REQUIRED UPSTREAM OF THE FINAL SUPPLY CONNECTION(S) TO FOODSERVICE EQUIPMENT UNLESS NOTED OTHERWISE.
 - ALL INDIRECT WASTES FOR FOODSERVICE EQUIPMENT WILL BE EXTENDED TO FLOOR DRAINS BY MECHANICAL TRADES, EXCEPT FOR THE WALK-IN REFRIGERATOR/FREEZER BLOWER COIL DRAINLINES AND DRAINLINES WITHIN THE CUSTOM FABRICATED COUNTERS WHICH WILL BE EXTENDED TO FLOOR DRAINS BY THE FSEC.
 - THE FSEC IS RESPONSIBLE FOR SETTING EQUIPMENT IN PLACE. FINAL CONNECTIONS AND INTERCONNECTIONS FOR THIS EQUIPMENT ARE THE RESPONSIBILITY OF THE MECHANICAL TRADES.
 - TRADE CONTRACTORS TO PROVIDE HOLES, SLEEVES THROUGH CEILING, ROOFS, AND WALLS FOR BEVERAGE, OIL, COMPRESSED AIR, ICE, SLURRY AND REFRIGERATION LINES. SEAL THEM IN ACCORDANCE WITH LOCAL FIRE, BUILDING CODES AND IN ACCORDANCE WITH SIZES SPECIFIED. TRADE CONTRACTORS TO PROVIDE ALL DUCT FIRE SEPARATIONS, ENCLOSURES, WRAPPINGS, ETC., AS MAY BE REQUIRED BY LOCAL BUILDING AND FIRE CODES. HOLES IN FOODSERVICE EQUIPMENT FOR MECHANICAL SERVICES PROVIDED BY FSEC.
 - SINK FAUCETS FURNISHED LOOSE BY FSEC FOR INSTALLATION BY MECHANICAL TRADES. SINK ROTARY DRAIN & OVERFLOW FURNISHED AND INSTALLED BY FSEC. TAILPIECE, P-TRAP, ESCUTCHEON PLATES AND DRAIN CONNECTION FURNISHED AND INSTALLED BY MECHANICAL TRADES EXCEPT FOR TAILPIECE AND P-TRAP FOR WALL MOUNTED HANDSINKS WHICH ARE PROVIDED BY FSEC AND INSTALLED BY MECHANICAL TRADES.
 - HEALTH CODES REQUIRE THAT ALL PLUMBING BE ENCLOSED IN WALLS OR FLOOR AND THAT EXPOSED PIPING RUNS BE AS SHORT AS POSSIBLE. GAS PIPING TO BE SLEEVED AND VENTED PER CODE SO IT IS CONCEALED WITHIN THE WALL. EXPOSED HORIZONTAL PIPING MUST BE 6" ABOVE THE FLOOR AND AT LEAST 1" OFF THE WALL. ANY EXPOSED UNINSULATED STEAM PIPING/FITTINGS AND HAND SINK PIPING (BOTH DRAIN AND SUPPLY LINES) ARE TO BE CHROME PLATED.
 - SIZE EXHAUST AND SUPPLY FAN CAPACITY FOR 125% OF AIR VOLUMES INDICATED. THE CFM LISTED IN THE SCHEDULE IS THE DESIGN MINIMUM AND THE TEST & BALANCE REPORT MUST BE EQUAL TO OR GREATER THAN THE LISTED CFM.
 - ON EXHAUST HOODS SHOWN OVER COOKING EQUIPMENT, INCLUDING EQUIPMENT WITH INTEGRAL HOODS THAT ARE TYPE I HOODS, PROVIDE APPROPRIATE FIRE-RATED HOOD/DUCT ENCLOSURE ABOVE CEILING. VERIFY WITH LOCAL CODE AUTHORITIES WHETHER FIRE-RATED ENCLOSURE IS REQUIRED AT PORTION OF EXHAUST HOOD THAT EXTENDS ABOVE THE CEILING. IF ENCLOSURE IS NEEDED, ADVISE CONSULTANT AS TO FINAL ENCLOSURE DETAIL AT HOOD.
 - ALL HOSE BIBBS BY MECHANICAL TRADES TO HAVE HOT WATER AND COLD WATER MIXING VALVE.
 - ENGINEERS TO VERIFY WITH LOCAL CODE AUTHORITIES IF USE OF A GREASE INTERCEPTOR IS REQUIRED. IF REQUIRED RUN DRAINLINES THRU GREASE INTERCEPTOR AS REQUIRED BY CODE. CENTRAL GREASE TRAP TO BE LOCATED OUTSIDE OF FOODSERVICE AREA. POINT OF USE GREASE TRAP TO BE FLUSH W/FLOOR & LOCATION TO BE COORDINATED WITH FOODSERVICE CONSULTANT.
 - BENEATH ALL EXHAUST HOODS, INSTALL ALL EXPOSED PIPING AS CLOSE TO WALL AS POSSIBLE, USING 90 DEGREE ELBOWS AS NEEDED SO COOKING EQUIPMENT MAY BE PUSHED BACK FROM FRONT EDGE OF HOOD FOR PROPER CAPTURE.
 - TO MINIMIZE CROSS DRAFTS THAT WOULD AFFECT HOOD CAPTURE, EFFECTIVE INTRODUCTION OF REPLACEMENT AIR (WHETHER SUPPLIED THROUGH DISPLACEMENT VENTILATION DIFFUSERS, PERFORATED DIFFUSERS LOCATED IN THE CEILING, AND/OR TRANSFER AIR FROM ADJACENT SPACES) SHOULD BE DESIGNED TO LIMIT VELOCITIES APPROACHING THE HOOD TO LESS THAN 75 FPM.
 - FOODSERVICE EQUIPMENT WATER PRESSURE REQUIREMENTS, UNLESS NOTED OTHERWISE, IS 40-70 PSI. MECHANICAL TRADES TO PROVIDE PRV'S AS REQUIRED TO ACHIEVE PRESSURE AS NOTED.
 - RECOMMENDED HOT WATER TEMPERATURES FOR SINKS SHOULD BE AS FOLLOWS: POT & PAN SINKS SET AT 120° F MAXIMUM, HAND SINKS SET AT 110° F MAXIMUM AND ALL OTHER SINKS SET AT 110-120° F MAXIMUM. HOT WATER TEMPERATURES MUST CONFORM TO CODE REQUIREMENTS.
 - TO MAXIMIZE EXHAUST HOOD CAPTURE & PROPER AIR VOLUME BALANCING, WE DO NOT RECOMMEND HAVING MORE THAN TWO DUCT COLLARS ON ONE FAN W/OUT THE USE OF A UL LISTED BALANCING DAMPER/BAFFLE AT EACH DUCT COLLAR. THE LISTED DAMPER REQUIRES AT LEAST 8" OF ADDITIONAL VERTICAL CLEARANCE DEPENDING ON THE MANUFACTURE & APPROVAL FROM THE LOCAL AUTHORITY HAVING JURISDICTION. PLEASE ADVISE CONSULTANT IF THE DAMPER NEEDS TO BE SPECIFIED.
 - UTILITY CONNECTIONS SHOWN ARE THOSE REQUIRED TO SERVICE FOOD SERVICE EQUIPMENT ONLY. MECHANICAL TRADES SHOULD VERIFY WITH OWNER WHETHER ADDITIONAL UTILITIES ARE REQUIRED FOR EXISTING, FUTURE OR VENDOR FURNISHED NON-FOODSERVICE EQUIPMENT LOCATED WITHIN THE AREA SHOWN ON THIS PLAN.
 - FLOOR SINKS IN FOODSERVICE AREAS TO BE ACID RESISTANT, PORCELAIN ENAMEL-COATED BOWL AND SPLASH RESISTANT GRATE REMOVABLE WITHOUT TOOLS. BASKET STRAINER TO BE REMOVABLE IN OPENING LESS THAN 6" IN HEIGHT.

SCHEDULE NOTES - MECHANICAL

- NOTE: SCHEDULE NOTES PERTAIN TO INDIVIDUAL ITEMS AS INDICATED IN THE MECHANICAL SPOT CONNECTION SCHEDULE.
- A. MECHANICAL TRADES TO INSTALL BACKFLOW PREVENTION DEVICE SUPPLIED BY FSEC.
- B. BRANCH CW FROM SPRAY RINSE OR FAUCET THRU SOLENOID VALVE AND VACUUM BREAKER, CONNECT TO DISPOSER THROAT, BOWL OR DISPOSER TROUGH AS SHOWN. SEE DETAIL.
- D. MECHANICAL TRADES TO PROVIDE A CODE APPROVED BACKFLOW PREVENTION DEVICE FOR THIS ITEM.
- E. THIS ITEM HAS SPECIAL WATER QUALITY REQUIREMENTS. VERIFY PARTS PER MILLION COUNT (PPM) OF TOTAL DISSOLVED SOLIDS IN THE WATER. IF IT IS 30 PPM OR HIGHER, MECHANICAL TRADES TO PROVIDE CONDITIONED WATER.
- F. IF WATER EXCEEDS 3 GRAINS OF HARDNESS, THE DISHMACHINE MANUFACTURER RECOMMENDS SOFTENED WATER BE PROVIDED TO THE DISHMACHINE AND BOOSTER HEATER. SEE FOODSERVICE EQUIPMENT DISHMACHINE SCHEDULE FOR THE APPROXIMATE HOURS OF OPERATION AND AMOUNT OF WATER USED PER HOUR.
- G. INDIRECT WASTE FOR THIS ITEM EXTENDED TO FLOOR DRAIN/SINK BY FSEC.
- H. PROVIDE CAST IRON OR STAINLESS STEEL WASTE PIPING TO ACCOMMODATE ACCIDENTAL DISCHARGE OF EXCESSIVELY HOT WATER
- I. THE FSEC WILL PROVIDE A QUICK-DISCONNECT FLEXIBLE HOSE WITH THIS PIECE OF EQUIPMENT FOR INSTALLATION BY MECHANICAL TRADES. SEE DETAIL.
- J. THE FSEC WILL PROVIDE A MECHANICALLY OPERATED GAS SHUT-OFF VALVE FOR INSTALLATION BY MECHANICAL TRADES. FSEC TO INTERCONNECT TO FIRE PROTECTION SYSTEM FOR FUEL SHUT-OFF TO COOKING EQUIPMENT BENEATH EXHAUST HOODS UPON ACTIVATION OF FIRE PROTECTION SYSTEM.
- M. ALL REFRIGERATION SYSTEMS ARE LOCATED APPROXIMATELY WHERE SHOWN ON THE PLAN UNLESS OTHERWISE NOTED. THE FOLLOWING ITEMS ARE NOT BY THE FSEC: ROOF CURBS/CONCRETE PADS, SLEEVED & SEALED PENETRATIONS IN ROOFS/FLOORS/CEILING/WALLS. VERIFY EXACT LOCATON WITH ARCHITECT/ENGINEER.
- Q. SEE FOODSERVICE EQUIPMENT DISHMACHINE SCHEDULE FOR THE SENSIBLE AND LATENT HEAT DISSIPATION FROM THE DISHMACHINE. VENTILATE THE DISHROOM ACCORDINGLY. THESE VALUES ARE TO CALCULATE VENTILATION REQUIRED IN ADDITION TO EXHAUST LISTED IN SCHEDULE. THIS HEAT IS ADDITIONAL HEAT NOT EXHAUSTED THRU MACHINE VENTS.
- S. WHEN A UTILITY DISTRIBUTION SYSTEM IS SPECIFIED, MECHANICAL TRADES SHALL:
- 1.PROVIDE AND INSTALL WATER, AND STEAM SUPPLY PIPES INSIDE SYSTEM'S VERTICAL CHASES FROM ROUGH-IN LOCATIONS TO RACEWAY PIPING CONNECTION POINTS
- 2.INSTALL METAL FLEXIBLE HOSES (PROVIDE WITH UNION) AND RIGID PIPE ASSEMBLIES, ALL FURNISHED BY RACEWAY MANUFACTURER, BETWEEN APPROPRIATE EQUIPMENT AND RACEWAY.
- 3.PROVIDE AND INSTALL BRASS ELLS, NIPPLES, AND REDUCING FITTINGS NECESSARY TO PRESENT A NEAT APPEARANCE AND TO PREVENT FLEXIBLE HOSES FROM TOUCHING THE FLOOR.
- 4.INSTALL VACUUM BREAKER, AIR GAP ASSEMBLY AND DRAINLINE FURNISHED BY SYSTEM MANUFACTURER BETWEEN EXHAUST HOOD OUTLET AND AIR GAP DRAIN AT FLOOR. FITTINGS AS REQUIRED BY PLUMBING CONTRACTOR.
- 5.SPECIAL NOTE – NO MODIFICATION OF ANY MANUFACTURED RACEWAY SHALL BE UNDERTAKEN BY ANY ENTITY WITHOUT THE EXPRESS, WRITTEN APPROVAL AND/OR SUPERVISION OF THE RACEWAY MANUFACTURER.
- THE FSEC WILL:
- 1.INTERCONNECT PLUMBING AND FIELD JOINTS BY TIGHTENING UNIONS: UNIONS PRE-FITTED AND SUPPLIED BY RACEWAY MANUFACTURER. EACH FIELD JOINT WILL CONSIST OF ONE UNION FOR EACH SERVICE.
- 2.TEST INTERNAL PIPING SYSTEM FOR LEAKS CAUSED BY SHIPPING AND TIGHTEN AS REQUIRED.
- V. MECHANICAL TRADES TO PROVIDE GAS PRESSURE REGULATORS TO REDUCE NATURAL GAS PRESSURE TO 10" W.C. (PROPANE TO 15" W.C.); GAS PRESSURE REGULATOR FURNISHED WITH REDUCE PRESSURE FROM 10" W.C. (OR 15" W.C.) TO REQUIRED PRESSURE.
- W. MECHANICAL TRADES TO CONCEAL MAIN GAS PIPING IN CHASE. DO NOT RUN EXPOSED ON FACE OF WALL. MINIMIZE EXPOSED PIPING FOR FINAL CONNECTIONS.
- X. THIS EQUIPMENT IS EXISTING. MECHANICAL/ELECTRICAL TRADES TO DISCONNECT, FSEC TO RELOCATE AND SET IN PLACE. FINAL RE-CONNECTION BY MECHANICAL/ELECTRICAL TRADES. MECHANICAL/ELECTRICAL TRADES TO COORDINATE UTILITY REQUIREMENTS WITH EXISTING EQUIPMENT & FSEC PRIOR TO ROUGH-IN.
- Y. PIPE DRAINLINE SERVING THIS EQUIPMENT IN LINE UPSTREAM FROM TELL-TALE FLOOR DRAIN (I.E. FLOOR DRAIN WITHOUT BACKWATER VALVE).
- Z. MECHANICAL TRADES TO FURNISH AND INSTALL DEDICATED EXHAUST FAN AND DUCTWORK TO SERVE THIS EQUIPMENT.

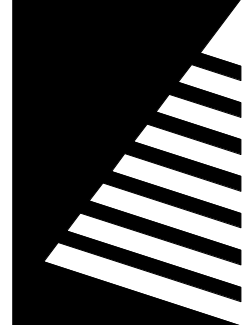

Farnsworth
GROUP

14225 UNIVERSITY AVENUE, SUITE 110
WAUJEE, IOWA 50263
(515) 225-3469 / info@f-w.com

www.f-w.com
Engineers | Architects | Surveyors | Scientists

RIPPE ASSOCIATES
FOODSERVICE DESIGN + CONSULTING

kpff


IMEG

Bishop Engineering

ISSUE
DATE: DESCRIPTION:


BID SET

PROJECT:
STATE OF IOWA DEPARTMENT
OF CORRE

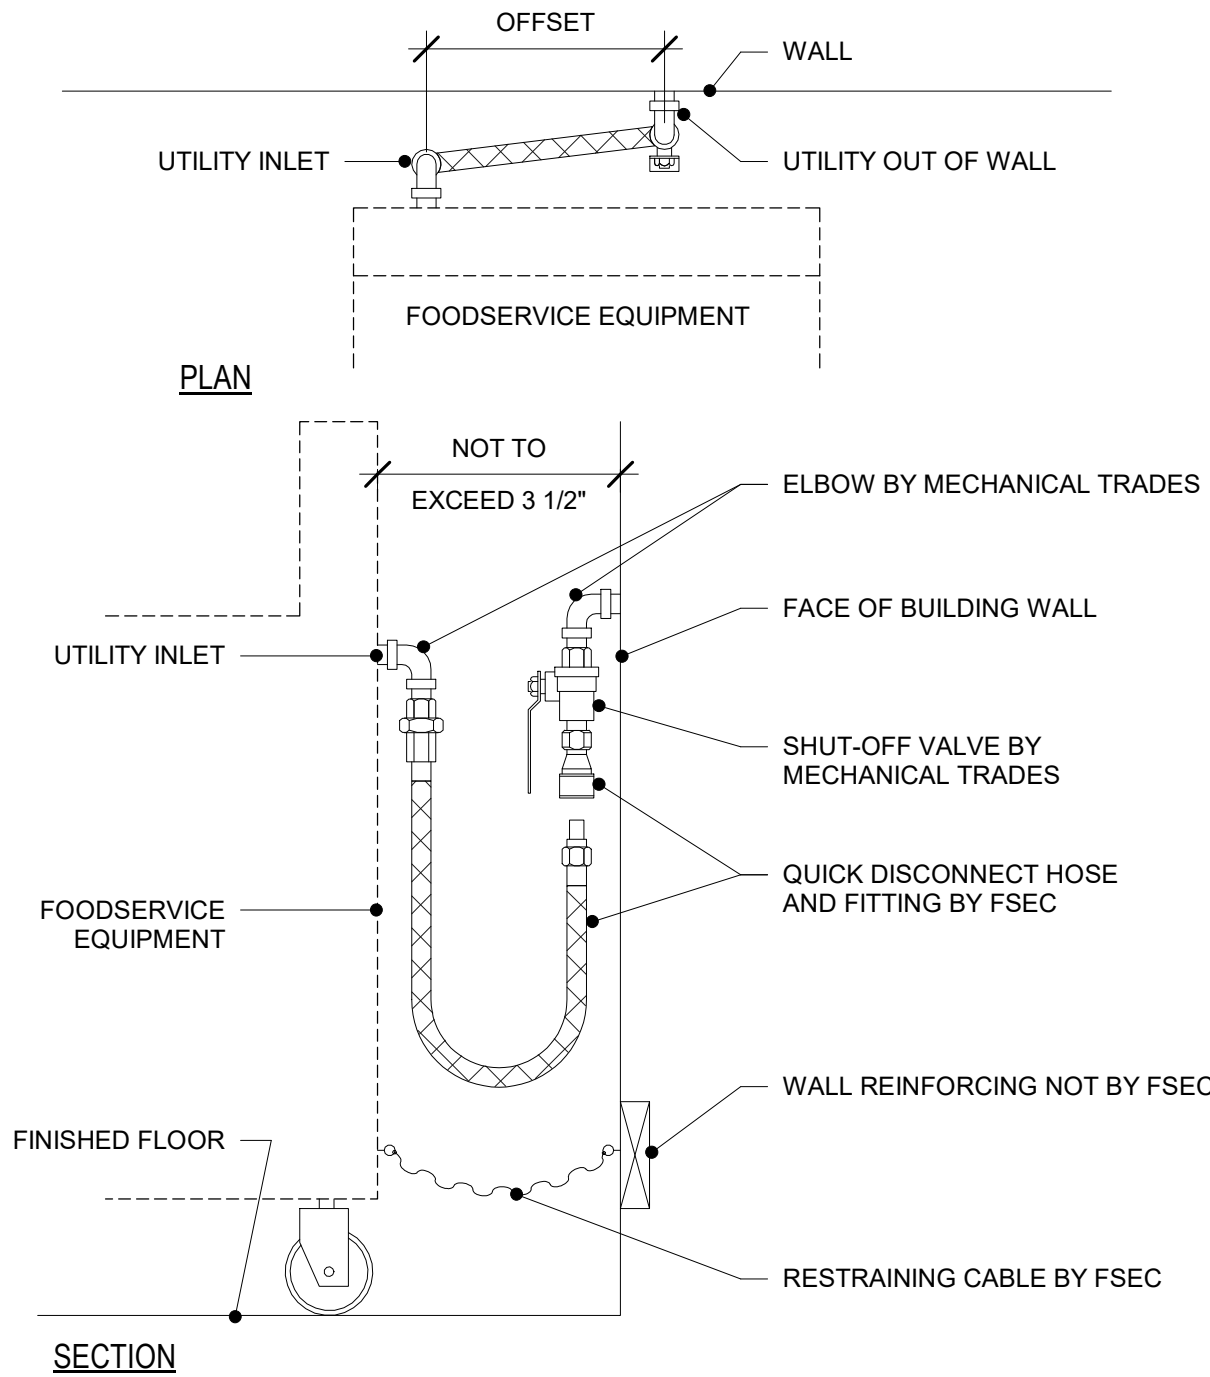


QUICK DISCONNECT

ROBERT RIPPE & ASSOCIATES, INC. © 2011 ROBERT RIPPE

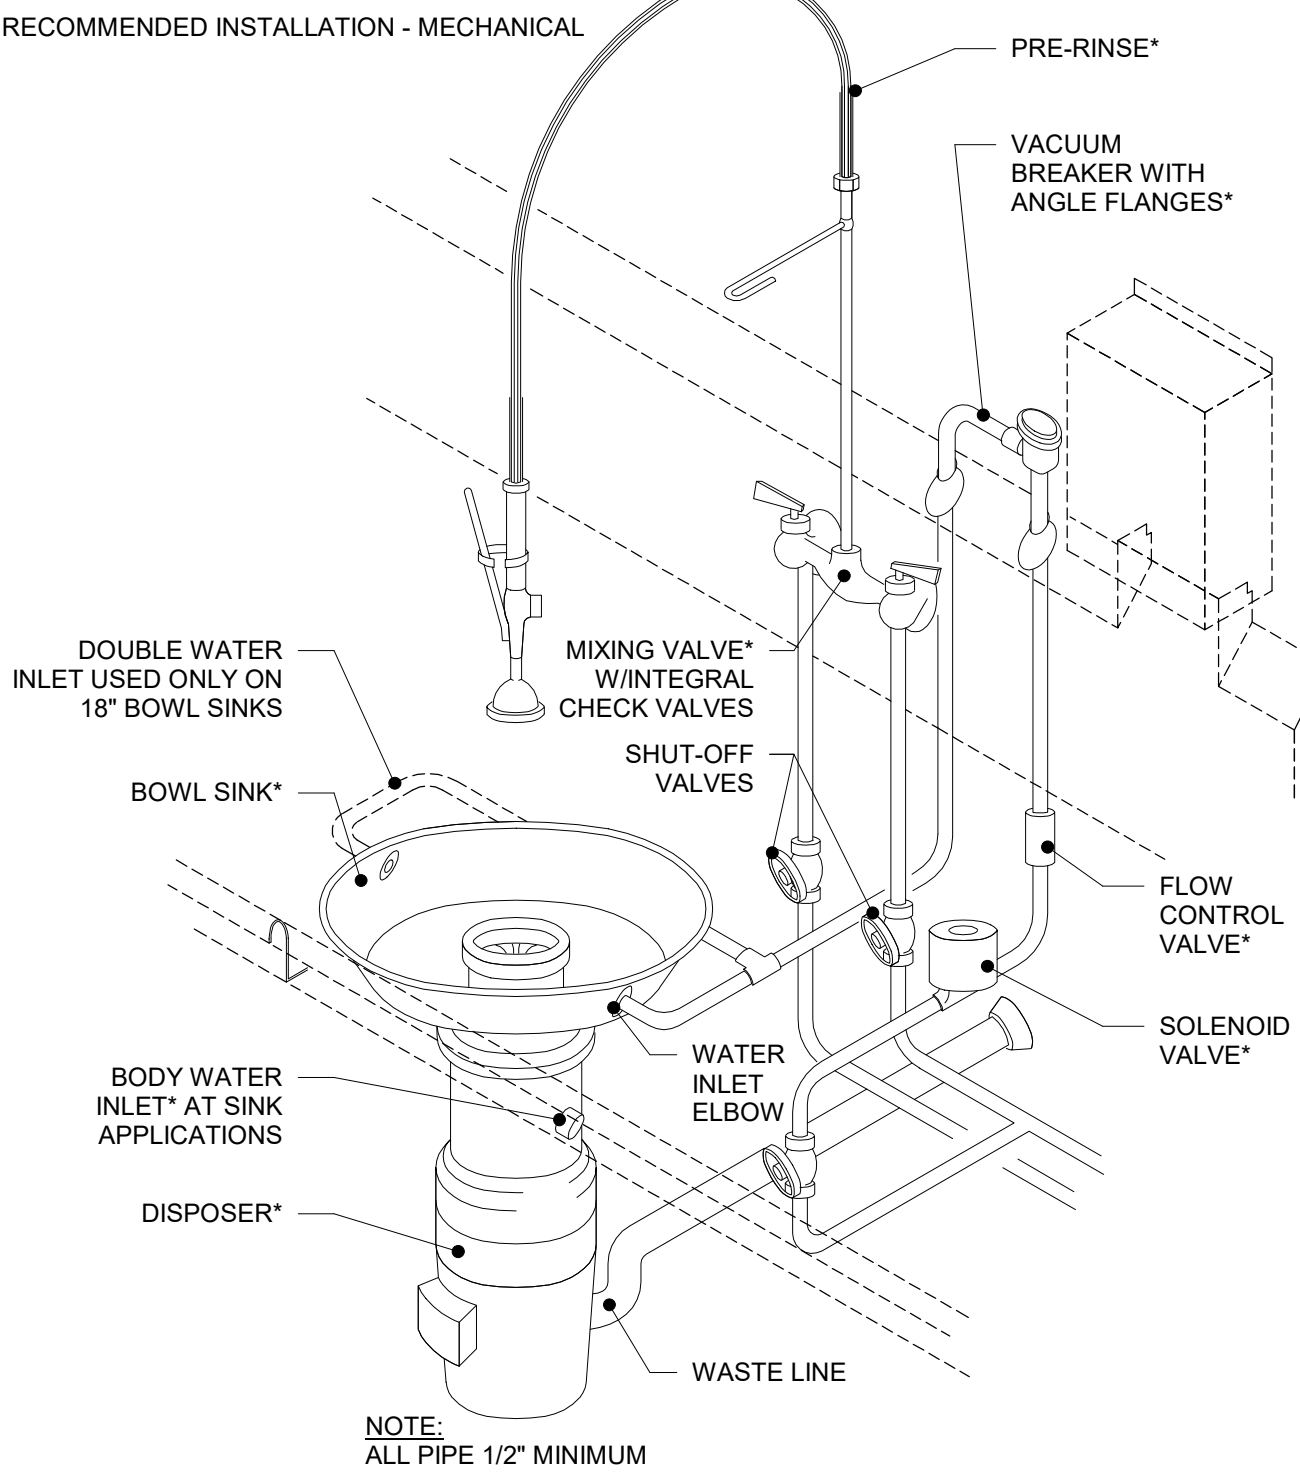


DISPOSER

ROBERT RIPPE & ASSOCIATES, INC. © 2011 ROBERT RIPPE

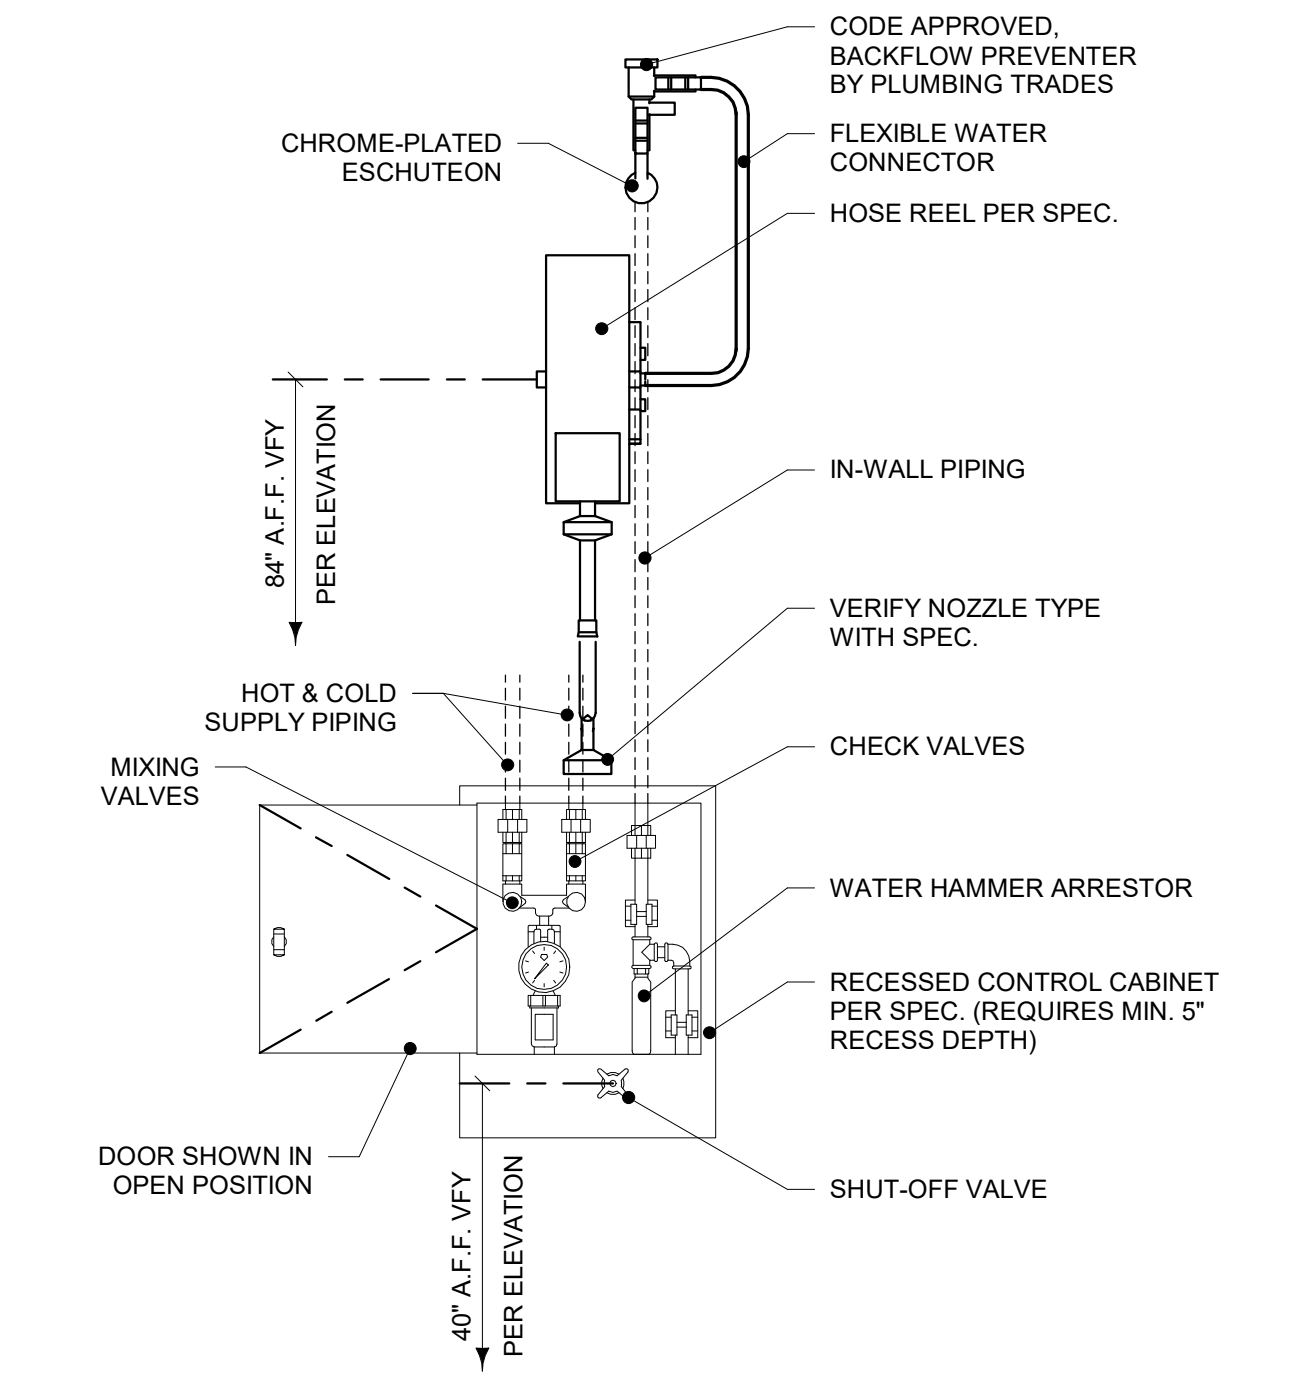


HOSE REEL

ROBERT RIPPE & ASSOCIATES, INC. © 2011 ROBERT RIPPE

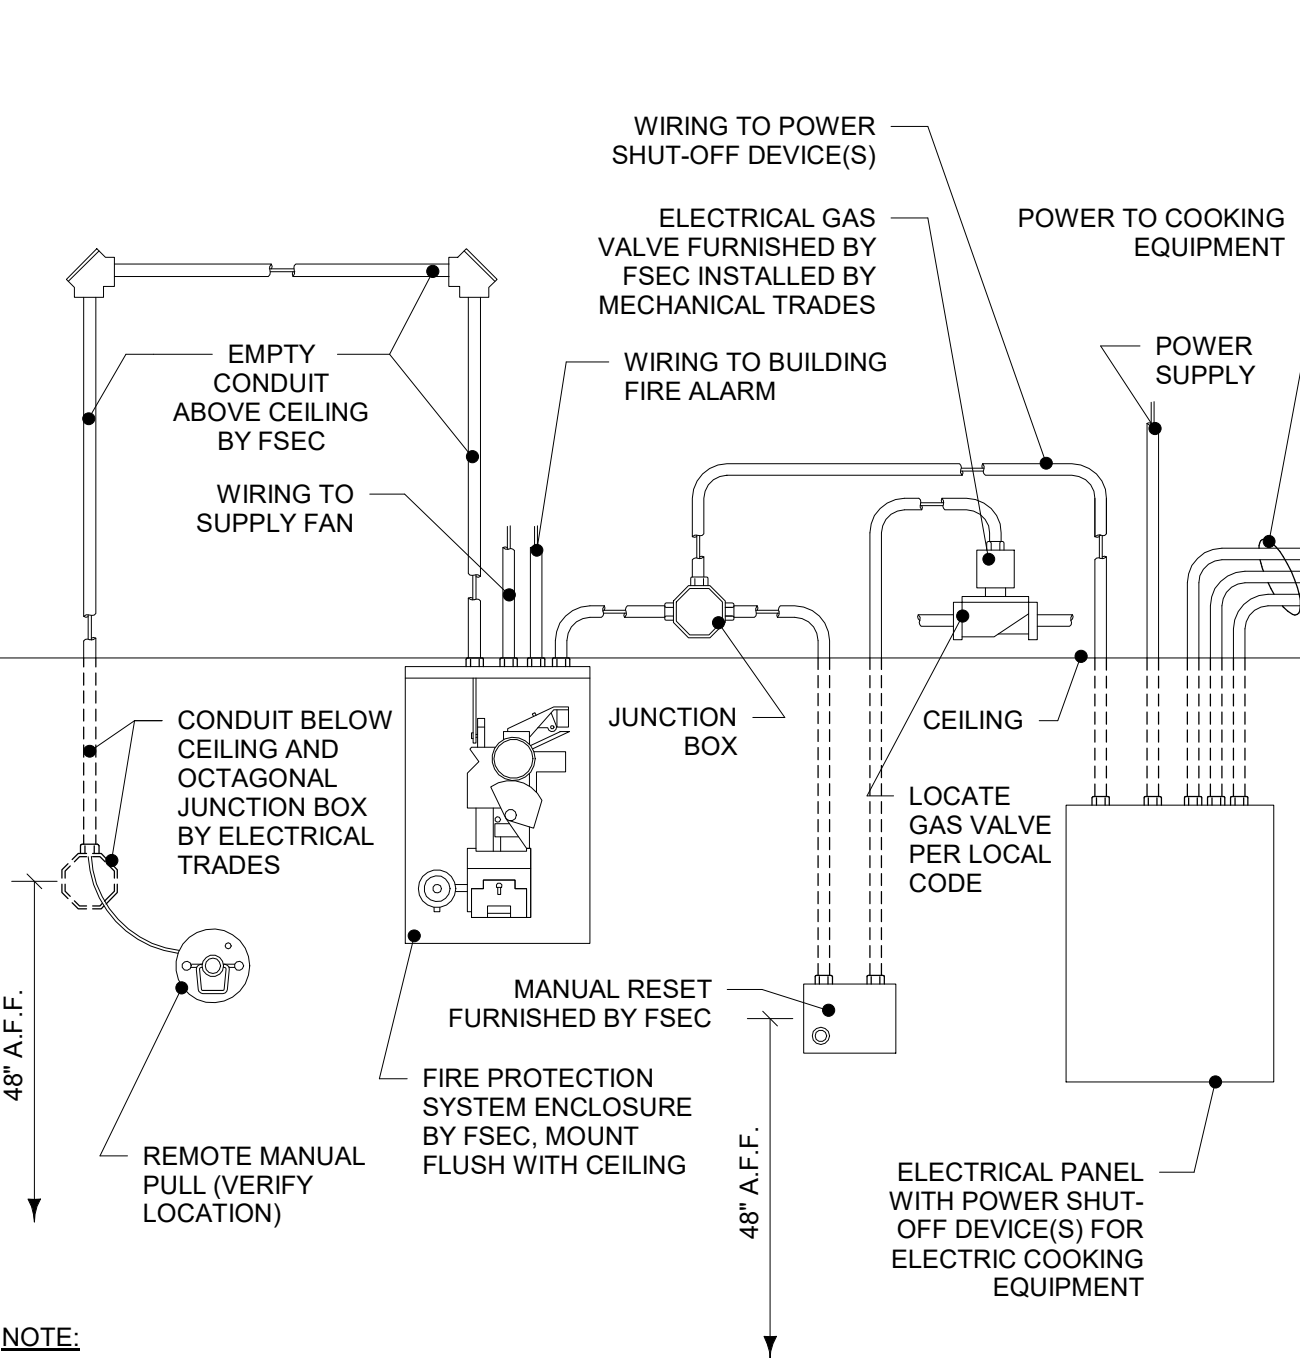

WET CHEMICAL FIRE PROTECTION SYSTEM

ROBERT RIPPE & ASSOCIATES, INC. © 2011 ROBERT RIPPE

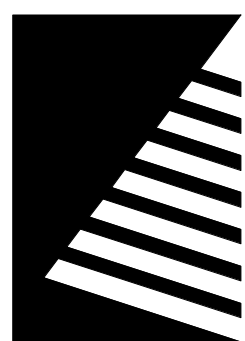

Farnsworth
GROUP

14225 UNIVERSITY AVENUE, SUITE 110
WALKEE, IOWA 50263
(515) 225-3469 / info@f-w.com

www.f-w.com
Engineers | Architects | Surveyors | Scientists

RIPPE ASSOCIATES
FOODSERVICE DESIGN + CONSULTING

kpff

IMEG

Bishop Engineering

ISSUE:
DATE: DESCRIPTION:

BID SET

PROJECT:
STATE OF IOWA DEPARTMENT
OF CORRECTIONS

**CLARINDA
CORRECTIONAL
FACILITY - KITCHEN &
LAUNDRY ADDITION**

2000 N 16TH ST, CLARINDA, IA
51632

DATE: 02/09/2024

DESIGNED: EG/TP

DRAWN: MM

REVIEWED: EG/RB

SHEET TITLE:
**FOODSERVICE
EQUIPMENT
MECHANICAL PLAN -
AREA 1**

SHEET NUMBER:

FSM102

PROJECT NO.: 0240202.00
RFB922300-02

MECHANICAL LEGEND	
	CW COLD WATER
	HW HOT WATER
	W DIRECT WASTE
	AGW AIR GAP WASTE
	IW INDIRECT WASTE
	FD FLOOR DRAIN
	FS FLOOR SINK
	FSH FLOOR SINK WITH HALF GRATE
	TTFD TELL-TALE FLOOR DRAIN
	S STEAM
	CR CONDENSATE RETURN
	G GAS
	CWR COOLING TOWER / CHILLED WATER SUPPLY/RETURN
	CO2 COMPRESSED AIR
	EX EXHAUST
	SUPPLY
	AFF ABOVE FINISHED FLOOR
	CLG CEILING
	DFA DOWN FROM ABOVE
	FSEC FOODSERVICE EQUIPMENT CONTRACTOR
	OOW OUT OF WALL
	MT MECHANICAL TRADES
	PLBG PLUMBING
	WC WATER COLUMN

CONDENSING UNITS ARE LOCATED
OUTSIDE ON THE ROOF. VERIFY EXACT
LOCATION WITH ARCHITECT/ENGINEER.
ROOF CURBS AND ALL PENETRATIONS
FOR REFRIGERATION LINES AND UTILITIES
ARE NOT BY SECT. 114000 CONTRACTOR.

2 FOODSERVICE MECHANICAL PLAN - ROOF
1/4" = 1'-0"

1 FOODSERVICE MECHANICAL PLAN - AREA 1
1/4" = 1'-0"



14225 UNIVERSITY AVENUE, SUITE 110
WAUKEE, IOWA 50263
(515) 225-3469 / info@f-w.com

www.f-w.com
Engineers | Architects | Surveyors | Scientists

RIPPE ASSOCIATES
FOODSERVICE DESIGN + CONSULTING



Bishop Engineering

ISSUE:	
#	DATE: DESCRIPTION:

BID SET

PROJECT:
STATE OF IOWA DEPARTMENT
OF CORRECTIONS

**CLARINDA
CORRECTIONAL
FACILITY - KITCHEN &
LAUNDRY ADDITION**

2000 N 16TH ST, CLARINDA, IA
51632

DATE: 02/09/2024

DESIGNED: EG/TP

DRAWN: MM

REVIEWED: EG/RB


SHEET TITLE:

**FOODSERVICE
EQUIPMENT
MECHANICAL PLAN -
AREA 2**

SHEET NUMBER: _____

FSM103


PROJECT NO.: 0240202.00
RFB922300-02

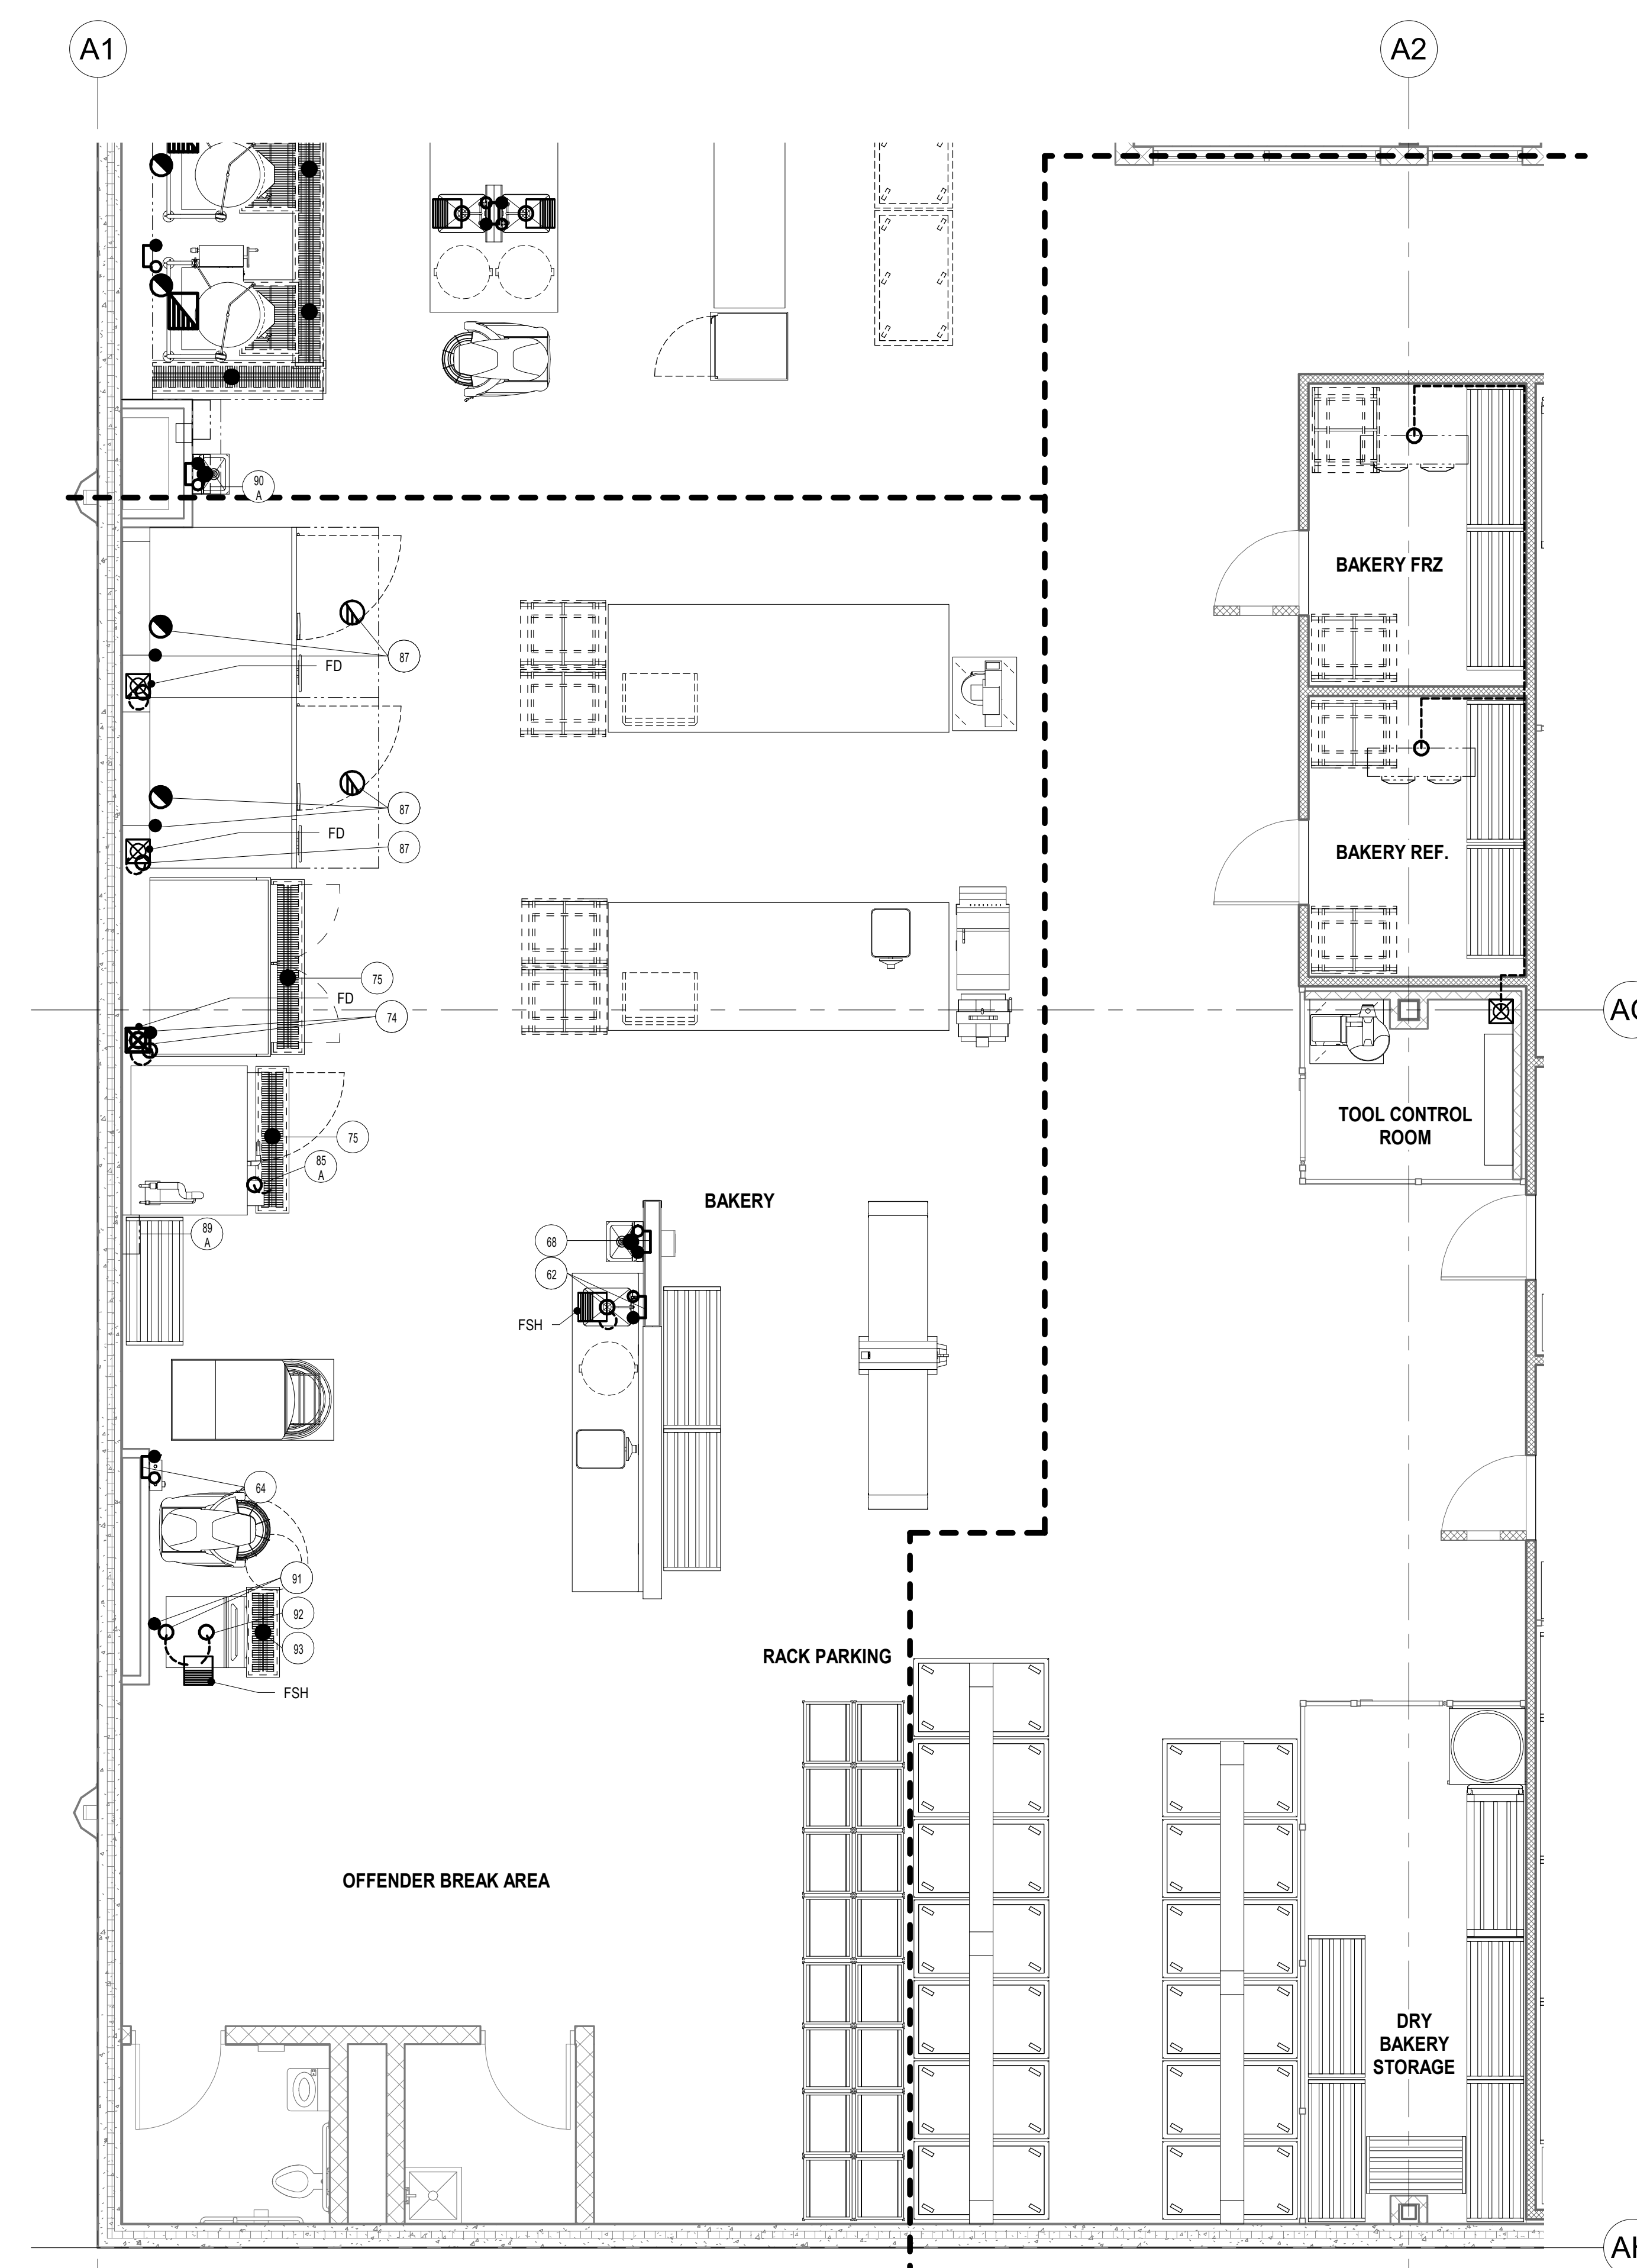

1 FOODSERVICE MECHANICAL PLAN - AREA 2
1/4" = 1'-0"

MECHANICAL LEGEND

	CW	COLD WATER
	HW	HOT WATER
	W	DIRECT WASTE
	AGW	AIR GAP WASTE
	IW	INDIRECT WASTE
	FD	FLOOR DRAIN
	FS	FLOOR SINK
	FSH	FLOOR SINK WITH HALF GRATE
	TTFD	TELL-TALE FLOOR DRAIN
	S	STEAM
	CR	CONDENSATE RETURN
	G	GAS
	CWR	COOLING TOWER / CHILLED WATER SUPPLY/RETURN
		COMPRESSED AIR
		C02
		EXHAUST
		SUPPLY
	AFF	ABOVE FINISHED FLOOR
	CLG	CEILING
	DFA	DOWN FROM ABOVE
	FSEC	FOODSERVICE EQUIPMENT CONTRACTOR
	ODW	OUT OF WALL
	MT	MECHANICAL TRADES
	PLBG	PLUMBING
	WC	WATER COLUMN

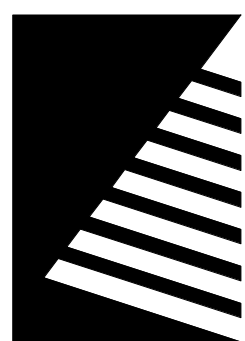

Farnsworth
GROUP

14225 UNIVERSITY AVENUE, SUITE 110
WALKEE, IOWA 50263
(515) 225-3469 / info@f-w.com

www.f-w.com
Engineers | Architects | Surveyors | Scientists

RIPPE ASSOCIATES
FOODSERVICE DESIGN + CONSULTING

kpff

IMEG

Bishop Engineering

ISSUE:
DATE: DESCRIPTION:

BID SET

PROJECT:
STATE OF IOWA DEPARTMENT
OF CORRECTIONS

CLARINDA
CORRECTIONAL
FACILITY - KITCHEN &
LAUNDRY ADDITION

2000 N 16TH ST, CLARINDA, IA
51632

DATE: 02/09/2024

DESIGNED: EG/TP

DRAWN: MM

REVIEWED: EG/RB


SHEET TITLE:

FOODSERVICE
EQUIPMENT
MECHANICAL PLAN -
AREA 3

SHEET NUMBER:

FSM104



PROJECT NO.: 0240202.00
RFB922300-02

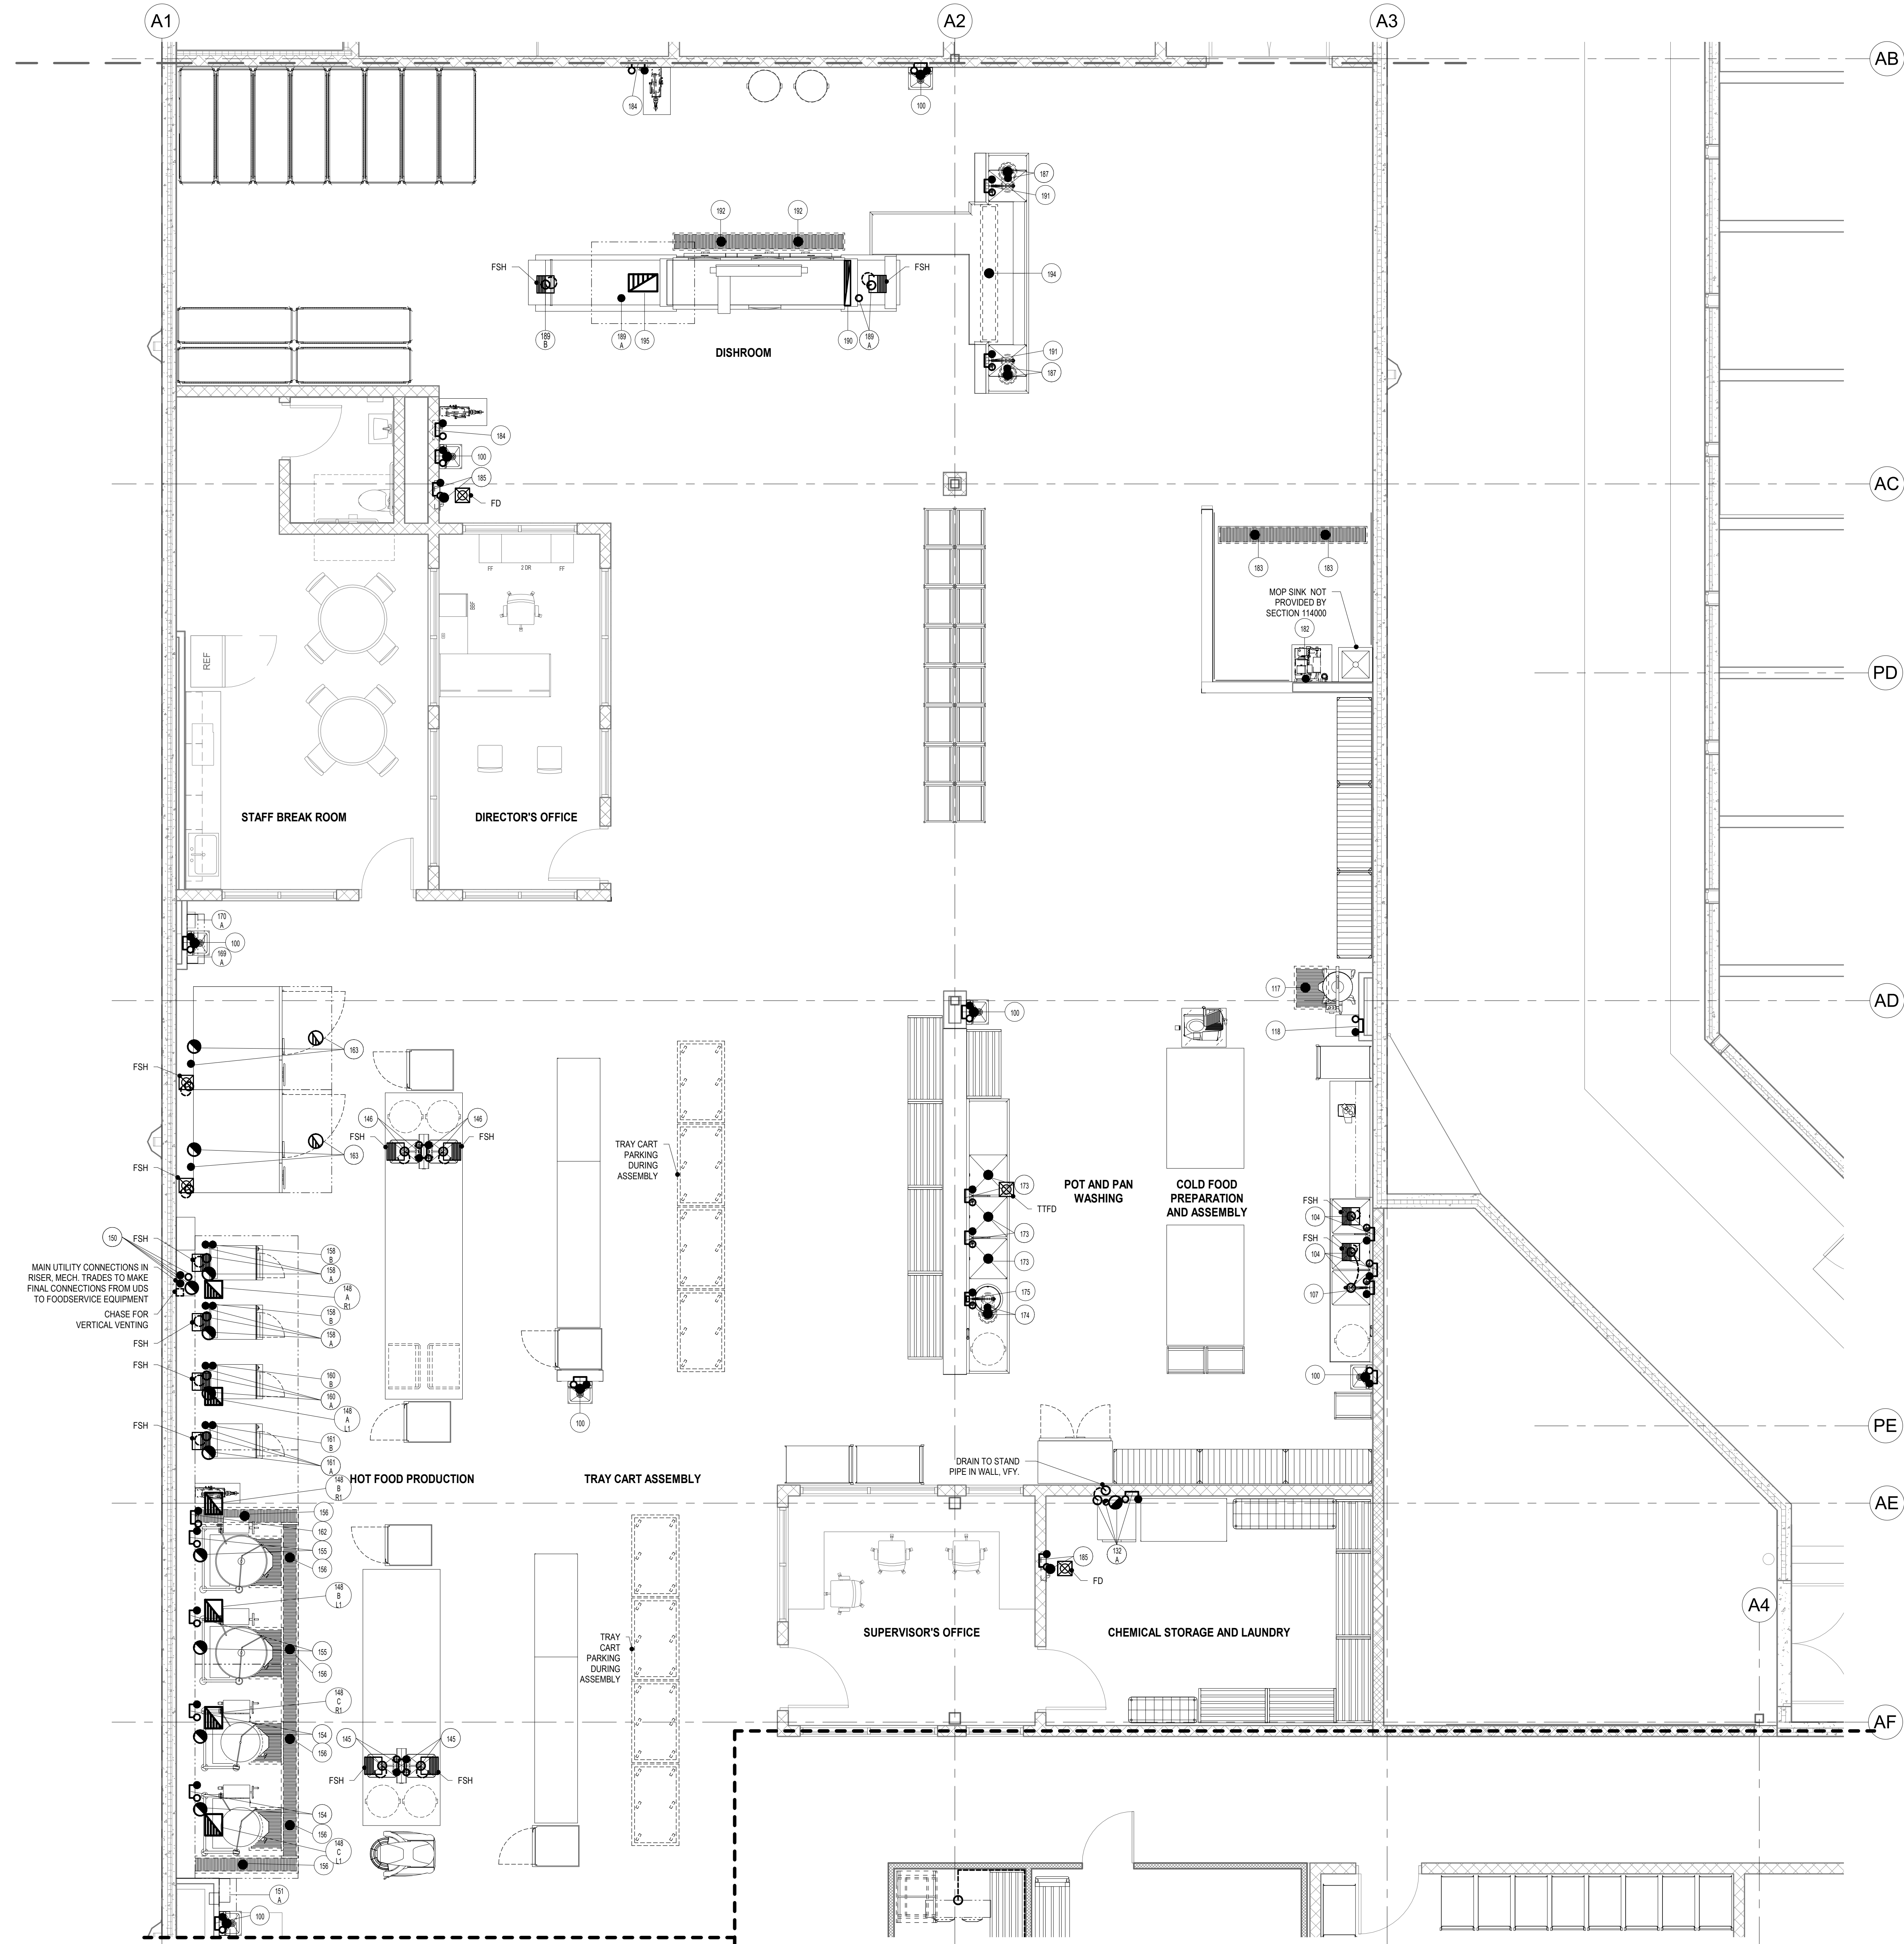

1 FOODSERVICE MECHANICAL PLAN - AREA 3
1/4" = 1'-0"

MECHANICAL LEGEND











CW	COLD WATER
HW	HOT WATER
W	DIRECT WASTE
AGW	AIR GAP WASTE
IW	INDIRECT WASTE
FD	FLOOR DRAIN
FS	FLOOR SINK
FSH	FLOOR SINK w/HALF GRATE
TTFD	TELL-TALE FLOOR DRAIN
S	STEAM
CR	CONDENSATE RETURN
G	GAS
CWR	COOLING TOWER / CHILLED WATER SUPPLY/RETURN
	COMPRESSED AIR
	CO2
	EXHAUST
	SUPPLY
AFF	ABOVE FINISHED FLOOR
CLG	CEILING
DFA	DOWN FROM ABOVE
FSFC	FOODSERVICE EQUIPMENT CONTRACTOR
OOW	OUT OF WALL
MT	MECHANICAL TRADES
PLBG	PLUMBING
WC	WATER COLUMN

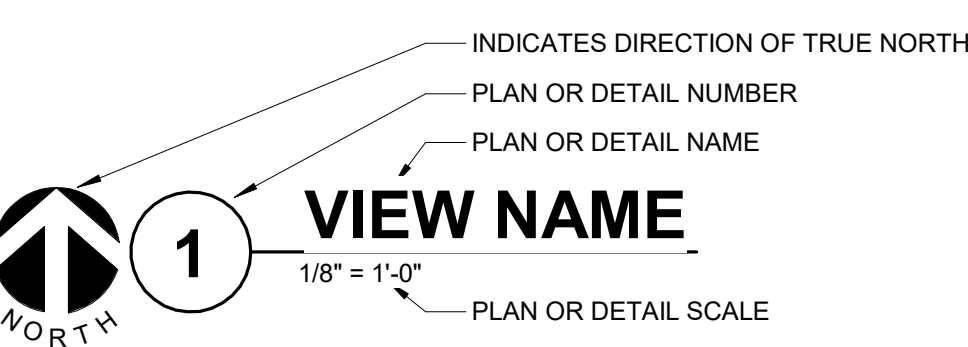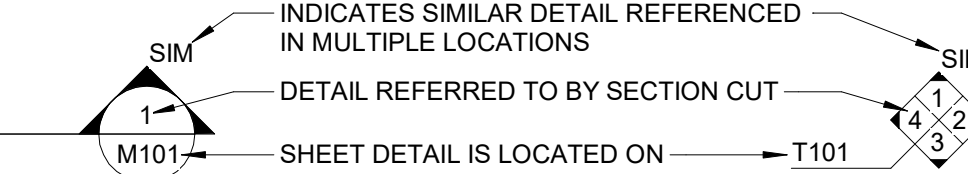VIEW KEY		
 NAME 10'-0"	LEVEL NAME HEIGHT ABOVE PROJECT 0'-0"	 INDICATES NOTE USED TO DESCRIBE ADDITIONAL INFORMATION ABOUT WORK REQUIRED, SPECIFIC TO THE SHEET AND/OR DETAIL
		
		
LINE TYPE AND TAG KEY:		
NEW WORK BY THIS CONTRACTOR (WIDE LINE)		
----- EXISTING TO BE REMOVED (SHORT DASHED PATTERN)		
--- -- EXISTING TO BE REMOVED (LONG DASHED PATTERN)		
EXISTING TO REMAIN OR WORK BY OTHERS (NARROW LINE)		
----- EXISTING TO BE REMOVED BY OTHERS (SHORT DASHED PATTERN)		
--- -- EXISTING UNDERFLOOR OR UNDERGROUND (LONG DASHED PATTERN)		
HALFTONING DOES NOT MODIFY SCOPE.		
'TAG-E TAGS WITH DASH 'E' INDICATES THE REFERENCED OBJECT IS EXISTING		
TAG UNDERLINED TAG INDICATES OBJECT IS IN SCOPE; IF NEW, ADDITIONAL INFORMATION IS AVAILABLE IN A SCHEDULE, MATERIAL LIST, OR SYMBOL LIST		
 INDICATES AN EXISTING SYSTEM'S POINT OF CONNECTION/REMOVAL		
 INDICATES A PLUMBING CONNECTION TO A FOOD SERVICE EQUIPMENT. REFERENCE FOOD SERVICE DRAWINGS FOR ADDITIONAL INFORMATION IN REGARDS TO TYPE OF EQUIPMENT, ROUGH-IN SIZES, AND ADDITIONAL COMMENTS.		

APPLICABLE CODES	
CONTRACTOR SHALL COMPLY WITH APPLICABLE CODES AND LOCAL AMENDMENTS.	
BUILDING CODE:	IBC 2015 EDITION
FIRE CODE:	IFC 2015 EDITION
PLUMBING CODE:	UPC 2021 EDITION
MECHANICAL CODE:	IMC 2021 EDITION
ELECTRICAL CODE:	NFPA 70 (NEC) 2020 EDITION
LIFE SAFETY CODE:	NFPA 101 2012 EDITION
ENERGY CONSERVATION CODE:	IECC 2012
HEALTH DEPARTMENT CODE:	CURRENT EDITION
LOCAL BUILDING CODE:	CURRENT EDITION

CONTRACTOR ABBREVIATION KEY	
ABBR:	DESCRIPTION:
C.C.	CIVIL CONTRACTOR
C.M.	CONSTRUCTION MANAGER
E.C.	ELECTRICAL CONTRACTOR
F.P.C.	FIRE PROTECTION CONTRACTOR
FSEC	FOOD SERVICE EQUIPMENT CONTRACTOR
M.C.	MECHANICAL CONTRACTOR
P.C.	PLUMBING CONTRACTOR
S.C.	SECURITY CONTRACTOR
T.C.	TECHNOLOGY CONTRACTOR
T.C.C.	TEMPERATURE CONTROLS CONTRACTOR

CONTACT PERSONS:	
DESCRIPTION:	PERSON:
PROJECT MANAGER	MIKE MCCARTY
MECHANICAL	MIKE MCCARTY
ELECTRICAL	KRISTEN SPINA
TECHNOLOGY	MIKE MCCARTY

          FIRE PROTECTION SYMBOL LIST	
NOT ALL SYMBOLS MAY APPLY.	
SYMBOL:	DESCRIPTION:
	DRAIN
	FIRE PROTECTION
	PIPE CAP
	PIPE DOWN
	PIPE UP OR UP/DOWN
	UNION/FLANGE
	DIRECTION OF FLOW IN PIPE
	ROUTE TO DRAIN
	SHUTOFF VALVE NORMALLY OPEN
	AUTOMATIC DRAIN VALVE
	ANGLE VALVE
	BUTTERFLY VALVE WITH MONITOR SWITCH
	CHECK VALVE
	INSPECTOR TEST AND DRAIN VALVE
	FLOW SWITCH
	PRESSURE GAUGE (FURNISHED WITH BALL VALVE)
	MONITOR SWITCH
	AREA BOUNDARY
	NO HATCH
	ORDINARY GROUP 1
	SPRINKLER - WALL MOUNTED
	SPRINKLER
	SPRINKLER - CONCEALED

FIRE PROTECTION ABBREVIATION KEY	
ABBR:	DESCRIPTION:
N.C.	NORMALLY CLOSED
NIC	NOT IN CONTRACT
N.O.	NORMALLY OPEN
TYP	TYPICAL
UON	UNLESS OTHERWISE NOTES

MECHANICAL RENOVATION NOTES:

THESE NOTES APPLY TO ALL MECHANICAL SHEETS AND TRADES, INCLUDING BUT NOT LIMITED TO, FIRE PROTECTION, PLUMBING, VENTILATION, PIPING AND TEMPERATURE CONTROL.

- EXISTING CONDITIONS ARE SHOWN BASED ON INFORMATION OBTAINED FROM FIELD SURVEYS, EXISTING BUILDING DOCUMENTS, AND STAFF. VERIFY EXISTING CONDITIONS AND REPORT ANY CONFLICTS BEFORE PROCEEDING.
- NOT ALL EXISTING DUCTWORK AND PIPING IS SHOWN. VERIFY EXISTING CONDITIONS BEFORE STARTING WORK. NOTIFY ENGINEER OF ANY CONFLICTS WITH NEW WORK.
- FIELD VERIFY THE AVAILABLE CLEARANCES FOR DUCTWORK AND PIPING BEFORE FABRICATION. RISER AND DROPS MAY BE NECESSARY BECAUSE OF EXISTING FIELD CONDITIONS.
- EACH CONTRACTOR SHALL FIELD VERIFY ACCESSIBILITY TO THE AREA OF THEIR WORK AND SHALL NOTIFY THE ARCHITECT/ENGINEER PRIOR TO BIDDING IF OTHER UTILITIES ARE REQUIRED TO BE REMOVED OR RELOCATED TO ALLOW ACCESS TO THEIR AREA OF WORK.
- EACH CONTRACTOR SHALL CUT AND PATCH ROOFS, WALLS, AND FLOORS ASSOCIATED WITH THEIR WORK.
- THIS CONTRACTOR IS RESPONSIBLE FOR REMOVAL AND REPLACEMENT OF CEILINGS, CEILING TILES, AND CEILING GRIDS ASSOCIATED WITH AREAS OF WORK REQUIRED BY THEIR WORK.
- WHERE EXISTING MECHANICAL SYSTEMS ARE LOCATED IN AREAS THAT CONFLICT WITH NEW EQUIPMENT, PIPING, OR DUCTWORK TO BE INSTALLED, EACH CONTRACTOR SHALL EITHER ARRANGE NEW EQUIPMENT, PIPING, OR DUCTWORK IN SUCH A FASHION THAT IT DOES NOT CONFLICT WITH EXISTING SYSTEMS, OR REWORK EXISTING MECHANICAL SYSTEMS TO ALLOW FOR INSTALLATION OF NEW EQUIPMENT, PIPING, OR DUCTWORK.
- PROVIDE TEMPORARY CONNECTIONS TO MAINTAIN EXISTING SYSTEMS IN SERVICE DURING CONSTRUCTION. MAINTAIN ACCESS TO EXISTING MECHANICAL INSTALLATIONS THAT REMAIN ACTIVE.
- OBTAIN PERMISSION FROM OWNER BEFORE SHUTTING DOWN ANY SYSTEM FOR ANY REASON. MAINTAIN SERVICE TO ALL COMPONENTS THAT ARE TO REMAIN UNTIL NEW SYSTEMS ARE INSTALLED.
- MAINTAIN EXISTING SYSTEM IN SERVICE UNTIL NEW SYSTEM IS COMPLETE AND READY FOR TIE IN AND SWITCHOVER. DRAIN SYSTEM ONLY TO MAKE SWITCHOVERS AND CONNECTIONS. OBTAIN PERMISSION FROM OWNER BEFORE PARTIALLY OR COMPLETELY DRAINING SYSTEM. MAKE CHANGEOVER TO NEW SYSTEMS WITH MINIMUM OUTAGE.
- DISCONNECT AND REMOVE MECHANICAL DEVICES AND EQUIPMENT SERVING EQUIPMENT THAT HAS BEEN REMOVED.

FIRE PROTECTION GENERAL NOTES:

- THE SYMBOLS AND THE MATERIAL LIST ARE FOR THE CONVENIENCE OF THE CONTRACTOR. CONTRACTOR SHALL VERIFY QUANTITIES AND FURNISH ALL MATERIALS REQUIRED FOR FULLY OPERATIONAL SYSTEMS, WHETHER SPECIFIED OR NOT.
- CATALOG NUMBERS SHALL NOT BE CONSIDERED COMPLETE, BUT ARE GIVEN AS AN AID TO THE CONTRACTOR AND TO INDICATE THE QUALITY REQUIRED. CONTRACTOR IS RESPONSIBLE FOR COMPLETE DESCRIPTION OF MATERIAL ON THESE DRAWINGS AND IN THE SPECIFICATIONS BEFORE ORDERING. THE DESCRIPTION OF THE MATERIAL TAKES PRECEDENCE OVER THE CATALOG NUMBER. THE FIRST MANUFACTURER IS THE BASIS OF DESIGN.
- CENTER SPRINKLERS IN CEILING TILES IN BOTH DIRECTIONS IN ALL AREAS. IN AREAS WITH 2X4' CEILING TILES CENTERING USING A 2X2' CEILING PATTERN IS ACCEPTABLE. SPRINKLER HEADS SHALL BE ALIGNED WITH OTHER SPRINKLER HEADS, LIGHTING, DIFFUSERS, AND ANY OTHER FEATURES IN THE CEILING.
- NEW SPRINKLERS SHALL BE QUICK RESPONSE TYPE, UNLESS OTHERWISE NOTED. CONTRACTOR SHALL NOT MIX STANDARD RESPONSE SPRINKLERS WITH QUICK RESPONSE SPRINKLERS IN UNPARTITIONED SPACES.
- PROVIDE COVERAGE ABOVE AND BELOW ALL DUCTWORK GREATER THAN 48" WIDE.
- FIRE PROTECTION PIPE ROUTING IS SHOWN FOR GENERAL LAYOUT. DETERMINE EXACT NUMBER OF SPRINKLERS, PIPE SIZING, AND PIPE ROUTING.
- ALL BUILDING AREAS SHALL BE FULLY SPRINKLERED INCLUDING CANOPIES, WALKWAYS, OVERHANGS, SOFFITS, AND BUILDING PROJECTIONS. ALL ACCESSIBLE COMBUSTIBLE CONCEALED SPACES SHALL BE FULLY PROTECTED BY THE SPRINKLER SYSTEM.
- EACH RISER ASSEMBLY SHALL INCLUDE CHECK VALVE BUTTERFLY CONTROL VALVE INDICATING "OPEN" OR "CLOSED" POSITION. TEST INSPECTION VALVE, FLOW SWITCH AND PRESSURE GAUGES.
- PROVIDE RISER ROOM IDENTIFICATION SIGNAGE OUTSIDE THE FIRE RISER ROOM. COORDINATE EXACT SIGN LANGUAGE WITH A/E.
- WHERE FEASIBLE INSTALL PIPES HIGH AS POSSIBLE TO AVOID CONFLICT WITH OTHER DISCIPLINES.
- INSTALL SYSTEM DRAINS AT LOW POCKET AREAS CONTAINING FIVE GALLONS OF WATER OR MORE, PROVIDE WITH ISOLATION VALVE AND THREADED HOSE CONNECTION.
- FOR LOW STRUCTURAL DETAILS WHEN PENETRATING OR PASSING THROUGH STRUCTURAL ELEMENTS, ALTERNATE DESIGNS WILL NEED TO BE APPROVED THROUGH THE STRUCTURAL ENGINEER.
- PROVIDE INTERMEDIATE TEMPERATURE SPRINKLER HEADS WHERE REQUIRED BY NFPA 13 UNLESS OTHERWISE NOTED.
- FINAL HEAD LOCATION, TYPE AND FINISH SHALL BE REVIEWED AND APPROVED BY THE ARCHITECT.
- THE OWNER MUST BE NOTIFIED PRIOR TO EACH AND EVERY DRAINING OR RECHARGING OF THE SPRINKLER SYSTEM.
- THE CONTRACTOR OR SHALL PREPARE A COORDINATED SET OF SHOP DRAWINGS AND SHALL OBTAIN APPROVAL FROM THE AUTHORITIES HAVING JURISDICTION AND THE LOCAL FIRE DEPARTMENT PRIOR TO ANY INSTALLATION.
- DRAWINGS SHOWING LOCATIONS OF EQUIPMENT, DUCTWORK, PIPING, ETC. ARE DIAGRAMMATIC AND MAY NOT ALWAYS REFLECT EXACT INSTALLATION CONDITIONS. DRAWINGS SHOW THE GENERAL ARRANGEMENT OF DUCTWORK, PIPING, EQUIPMENT, ETC. AND MAY NOT INCLUDE ALL OFFSETS AND FITTINGS REQUIRED FOR COMPLETE INSTALLATION. THE DRAWINGS SHALL BE FOLLOWED AS CLOSELY AS ACTUAL BUILDING CONSTRUCTION AND THE WORK OF OTHERS WILL PERMIT.
- VERIFY ALL DIMENSIONS AND CLEARANCES FROM ARCHITECTURAL, STRUCTURAL, SUBMITTALS, AND OTHER APPROPRIATE DRAWINGS OR PHYSICALLY AT SITE. REVIEW ALL DRAWINGS, INCLUDING THOSE OF OTHER TRADES.

MECHANICAL GENERAL NOTES:

THESE NOTES APPLY TO ALL MECHANICAL SHEETS AND TRADES, INCLUDING BUT NOT LIMITED TO, FIRE PROTECTION, PLUMBING, VENTILATION, PIPING AND TEMPERATURE CONTROL.


- DRAWINGS SHOWING LOCATIONS OF EQUIPMENT, DUCTWORK, PIPING, ETC. ARE DIAGRAMMATIC AND MAY NOT ALWAYS REFLECT EXACT INSTALLATION CONDITIONS. DRAWINGS SHOW THE GENERAL ARRANGEMENT OF DUCTWORK, PIPING, EQUIPMENT, ETC., AND MAY NOT INCLUDE ALL OFFSETS AND FITTINGS REQUIRED FOR COMPLETE INSTALLATION. THE DRAWINGS SHALL BE FOLLOWED AS CLOSELY AS ACTUAL BUILDING CONSTRUCTION AND THE WORK OF OTHERS WILL PERMIT.
- DO NOT SCALE DRAWINGS. VERIFY ALL DIMENSIONS AND CLEARANCES FROM ARCHITECTURAL, STRUCTURAL, SUBMITTALS, AND OTHER APPROPRIATE DRAWINGS OR PHYSICALLY AT SITE. REVIEW ALL DRAWINGS, INCLUDING THOSE OF OTHER TRADES.
- COORDINATE ALL WORK WITH ALL OTHER TRADES PRIOR TO INSTALLATION TO PROVIDE CLEARANCES REQUIRED FOR OPERATION, MAINTENANCE, CODE COMPLIANCE, AND TO VERIFY NON-INTERFERENCE WITH OTHER WORK. DO NOT FABRICATE PRIOR TO VERIFICATION OF NECESSARY CLEARANCES FOR ALL TRADES. BRING ANY INTERFERENCES OR CONFLICTS TO THE ATTENTION OF THE ARCHITECT/ENGINEER BEFORE PROCEEDING WITH FABRICATION OR EQUIPMENT ORDERS.
- REVIEW SPACE REQUIREMENTS OF EQUIPMENT SPECIFIED OR SUBSTITUTED AND MAKE REASONABLE ACCOMMODATIONS IN LAYOUT AND POSITIONING TO PROVIDE PROPER ACCESS.
- ANY CHANGES REQUIRED TO ELIMINATE CONFLICTS OR THAT RESULT FROM A FAILURE TO COORDINATE SHALL BE MADE BY THE CONTRACTOR WITHOUT ADDITIONAL COST OR EXPENSE TO OTHERS.
- EACH CONTRACTOR IS RESPONSIBLE FOR ALL COSTS ASSOCIATED WITH ELECTRICAL CHANGES REQUIRED FOR EQUIPMENT PROPOSED THAT DIFFERS FROM THE BASIS OF DESIGN.
- REFER TO ARCHITECTURAL REFLECTED CEILING PLAN, ELECTRICAL TECHNOLOGY AUDIOVISUAL, AND OTHER MECHANICAL PLANS FOR EXACT LOCATIONS OF ALL CEILING MOUNTED DEVICES, OTHER THAN SPRINKLERS.
- EACH CONTRACTOR IS RESPONSIBLE FOR DAMAGE CAUSED BY THEIR ACTIONS TO WALLS, FLOORS, CEILINGS, AND ROOMS. THE CONTRACTOR WHOSE WORK CAUSES DAMAGE IS RESPONSIBLE FOR PATCHING TO MATCH ORIGINAL CONSTRUCTION, FIRE RATING, AND FINISH.
- IN AREAS WITH DRYWALL CEILINGS COORDINATE LOCATIONS OF ACCESS PANELS WITH THE DRY WALL CONTRACTOR FOR ACCESS TO VALVES, DUCTWORK ACCESSORIES, DAMPERS, ETC. COORDINATE PANEL TYPE AND COLOR WITH ARCHITECT. NOTIFY THE DRY WALL CONTRACTOR OF THE REQUIRED ACCESS PANELS PRIOR TO BIDDING.
- SEAL ALL FLOOR, WALL, AND ROOF PENETRATIONS AIRTIGHT WHERE CONDUITS, PIPING, AND DUCTS PENETRATE. PENETRATIONS THROUGH EXTERIOR WALLS AND ROOF SHALL BE SEALED AIRTIGHT WITH WATERPROOFING MATERIALS RECOMMENDED BY MANUFACTURER FOR OUTDOOR USE.
- CAULK ALL PIPE AND DUCT PENETRATIONS OF FULL HEIGHT NON-FIRE RATED WALL, PARTITION, FLOOR, AND ROOF ASSEMBLIES. THIS IS ESSENTIAL TO PREVENT NOISE TRANSMISSION FROM ONE ROOM TO ANOTHER AND TO PROVIDE THE DESIRED NC LEVELS WITHIN ROOMS.
- WHERE PIPES AND DUCTS ARE SHOWN TO PENETRATE FLOORS, PROVIDE SLEEVED OPENINGS WITH THE TOP EDGE RAISED ABOVE FLOOR SURFACE IN ACCORDANCE WITH ALL RELEVANT SPEC SECTIONS. SEAL SLEEVE PERIMETER TO BE WATERTIGHT.
- EQUIPMENT SIZES AND SERVICE CLEARANCE REQUIREMENTS VARY AMONG DIFFERENT MANUFACTURERS. CONSULT APPROVED SHOP DRAWINGS FOR EQUIPMENT SIZES AND REQUIRED SERVICE CLEARANCES. COORDINATE WITH LAYOUT OF EQUIPMENT PADS, PIPING, DUCTWORK, ETC.
- DO NOT BLOCK TUBE PULL OR EQUIPMENT SERVICE CLEARANCES.
- MAINTAIN A MINIMUM WORKING CLEARANCE OF 3'-6" IN FRONT OF ALL ELECTRICAL EQUIPMENT REQUIRING MAINTENANCE, INSPECTION, AND TESTING INCLUDING BUT NOT LIMITED TO PANELS, DISTRIBUTION PANELS, SWITCHBOARDS, MOTOR CONTROL CENTERS, TRANSFORMERS, EQUIPMENT DISCONNECTS AND STARTERS.
- MAINTAIN THE DEDICATED ELECTRICAL EQUIPMENT SPACE DEFINED BY THE WIDTH / DEPTH OF ELECTRICAL EQUIPMENT MEASURED FROM THE FLOOR TO A HEIGHT 6'-0" ABOVE THE EQUIPMENT OR THE STRUCTURAL CEILING, WHICHEVER IS LOWER. SYSTEMS FOREIGN TO THE ELECTRICAL DISTRIBUTION SYSTEM ARE NOT ALLOWED IN THE DEDICATED ELECTRICAL SPACE INCLUDING: DUCTWORK, PIPING, ETC.
- PROVIDE CONCRETE EQUIPMENT PAD FOR ALL FLOOR MOUNTED EQUIPMENT. PAD SHALL EXTEND MINIMUM 6" BEYOND ALL SIDES OF EQUIPMENT.
- DO NOT SUPPORT EQUIPMENT, PIPING, OR DUCTWORK FROM METAL DECKING OR OTHER NON-STRUCTURAL BUILDING ELEMENTS. ANCHORS EMBEDDED IN CONCRETE SHALL BE CRACKED CONCRETE, APPROVED IN ACCORDANCE WITH SPECIFICATIONS.

FIRE PROTECTION SHEET INDEX	
F0.0	FIRE PROTECTION COVERSHEET
F1.1	LEVEL 01 PLAN - AREA A - FIRE PROTECTION
F1.2	LEVEL 01 PLAN - AREA B - FIRE PROTECTION
F1.3	LEVEL 02 PLAN - AREA A - FIRE PROTECTION
F1.4	LEVEL 02 PLAN - AREA B - FIRE PROTECTION
F4.1	FIRE PROTECTION DETAILS & SCHEDULES
GRAND TOTAL: 6	




www.imegcorp.com

IMEG CORP. RESERVES PROPRIETARY RIGHTS, INCLUDING COPYRIGHTS, TO THIS DRAWING AND THE DATA SHOWN THEREIN. SAID DRAWING AND/OR DATA ARE THE EXCLUSIVE PROPERTY OF IMEG CORP. AND SHALL NOT BE LOANED OR REPRODUCED FOR ANY OTHER PROJECT WITHOUT THE EXPRESS WRITTEN APPROVAL AND PARTICIPATION OF IMEG CORP. ©2024 IMEG CORP.

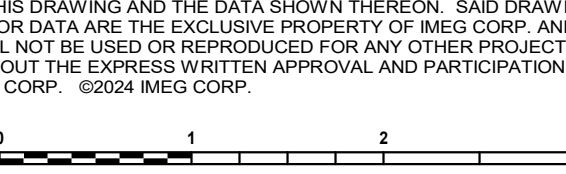

0 1 2 3
FEET SCALE IN INCHES PROJECT #21007888.00

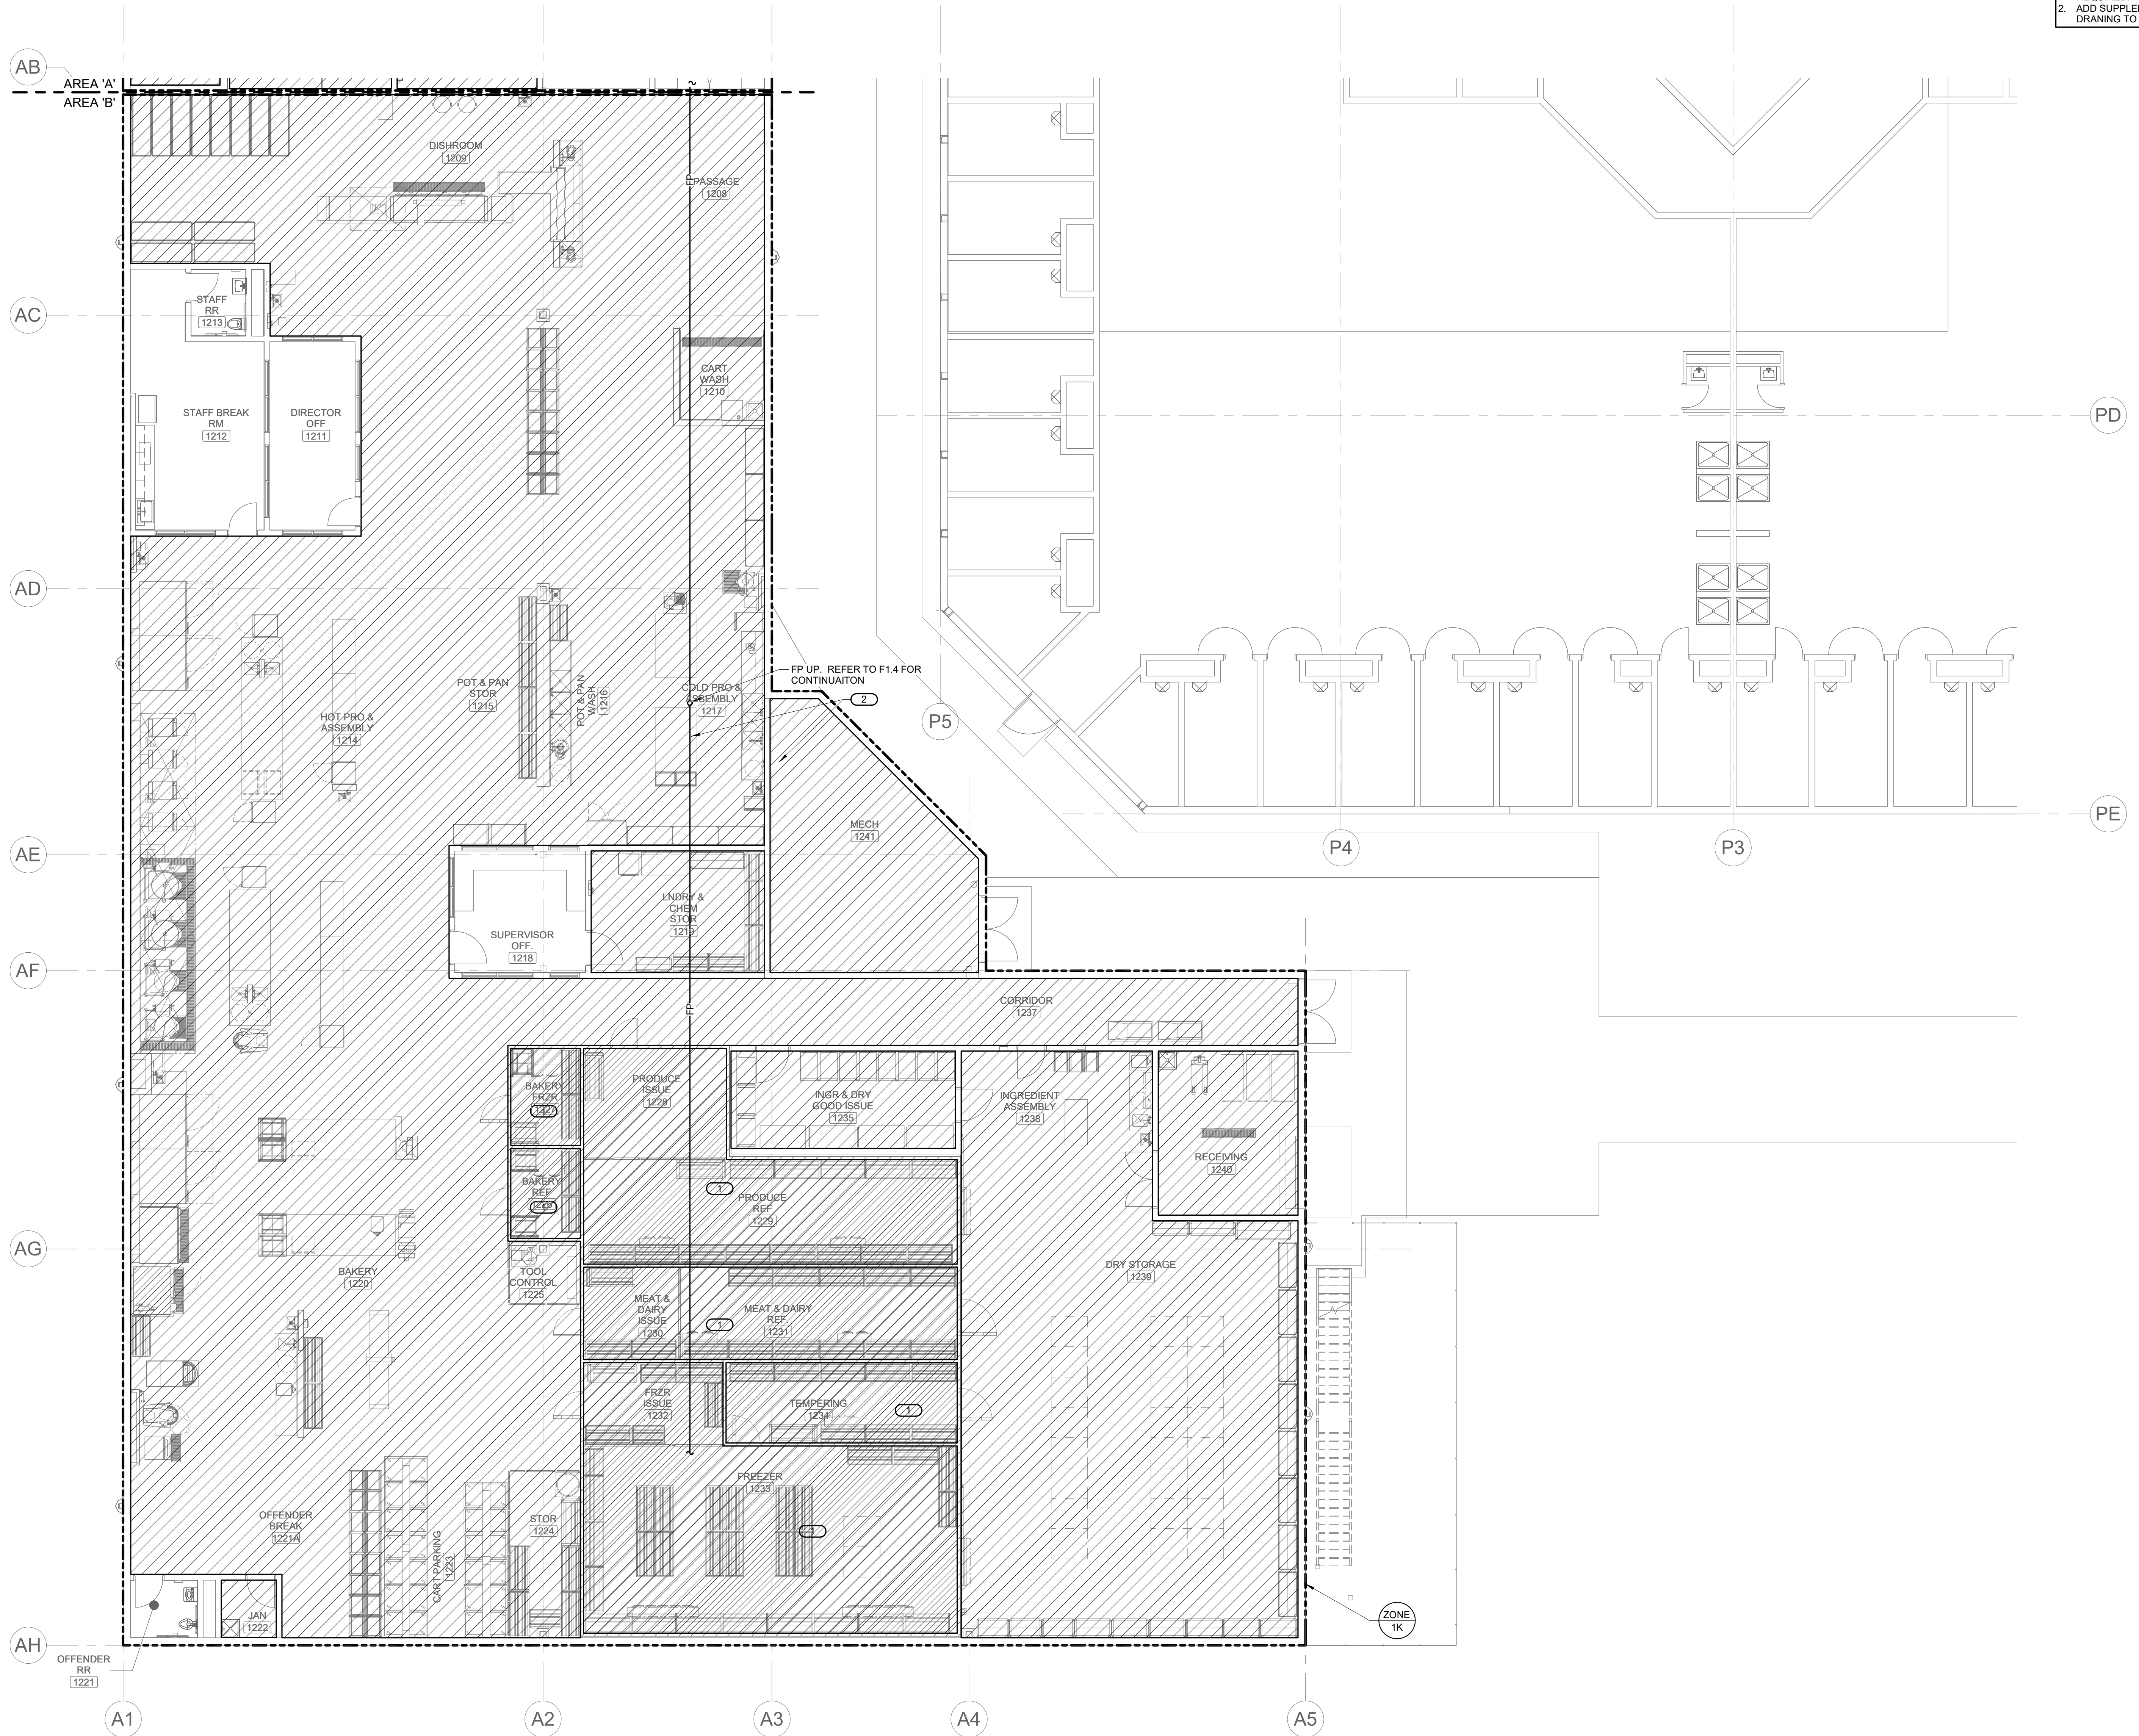

- GENERAL NOTES:**
1. REFER TO F4.1 FOR SPRINKLER USAGE SCHEDULE AND FIRE PROTECTION MATERIAL LIST.
 2. REFER TO DETAILS 1/F4.1, 2/F4.2 AND 3/F4.3 FOR SPRINKLER MOUNTING DETAILS AND PIPING THROUGH FIRE RATED WALL DETAIL.
 3. REFER TO F0.0 FOR GENERAL FIRE PROTECTION NOTES.
- KEYNOTES:** (#)
1. PROVIDE DRY TYPE SPRINKLER (SPR-4) IN COOLER OR FREEZER. F.S.C. SHALL PROVIDE PENETRATION, TRIM RING AND SEAL AROUND SPRINKLER. F.P.C. SHALL COORDINATE WITH F.S.C. ON LOCATIONS WHERE PENETRATIONS ARE REQUIRED.
 2. ADD SUPPLEMENTAL DRAIN VALVE TO ALLOW DRAINING TO FLOOR SINK IN ROOM 1241.




1 LEVEL 01 PLAN - AREA B - FIRE PROTECTION
1/8" = 1'-0"

IMEG
www.imegcorp.com
IMEG CORP. RESERVES PROPRIETARY RIGHTS, INCLUDING COPYRIGHTS, TO THIS DRAWING AND THE DATA SHOWN THEREIN. SAID DRAWING AND/OR DATA ARE THE EXCLUSIVE PROPERTY OF IMEG CORP. AND SHALL NOT BE USED OR REPRODUCED FOR ANY OTHER PROJECT WITHOUT THE EXPRESS WRITTEN APPROVAL AND PARTICIPATION OF IMEG CORP. ©2024 IMEG CORP.

2882 100TH STREET
DES MOINES, IA 50322
P: 515.334.9008 F: 515.334.9008

0 1 2 3
REF. SCALE IN INCHES PROJECT #21007888.00

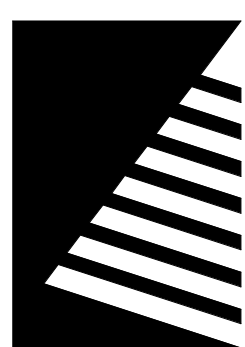

Farnsworth
GROUP

14225 UNIVERSITY AVENUE, SUITE 110
WALKEE, IOWA 50263
(515) 225-3469 / info@f-w.com

www.f-w.com
Engineers | Architects | Surveyors | Scientists

RIPPE ASSOCIATES
FOODSERVICE DESIGN + CONSULTING

kpff

IMEG

Bishop Engineering

ISSUE:
DATE: DESCRIPTION:

BID SET

PROJECT:
STATE OF IOWA - DEPARTMENT
OF CORRECTIONS

**CLARINDA
CORRECTIONAL
FACILITY - KITCHEN &
LAUNDRY ADDITION**

2000 N 16TH ST, CLARINDA, IA
51632

DATE: 02/09/2024

DESIGNED: MIKMCC

DRAWN: MIKMCC

REVIEWED: DELLE

SHEET TITLE:

**LEVEL 01 PLAN -
AREA B - FIRE
PROTECTION**

SHEET NUMBER:


F1.2

PROJECT NO.:

0240202.00

RFB922300-02

GENERAL NOTES:
1. REFER TO F4.1 FOR SPRINKLER USAGE
SCHEDULE AND FIRE PROTECTION MATERIAL LIST.
2. REFER TO F0.0 FOR GENERAL FIRE PROTECTION
NOTES.

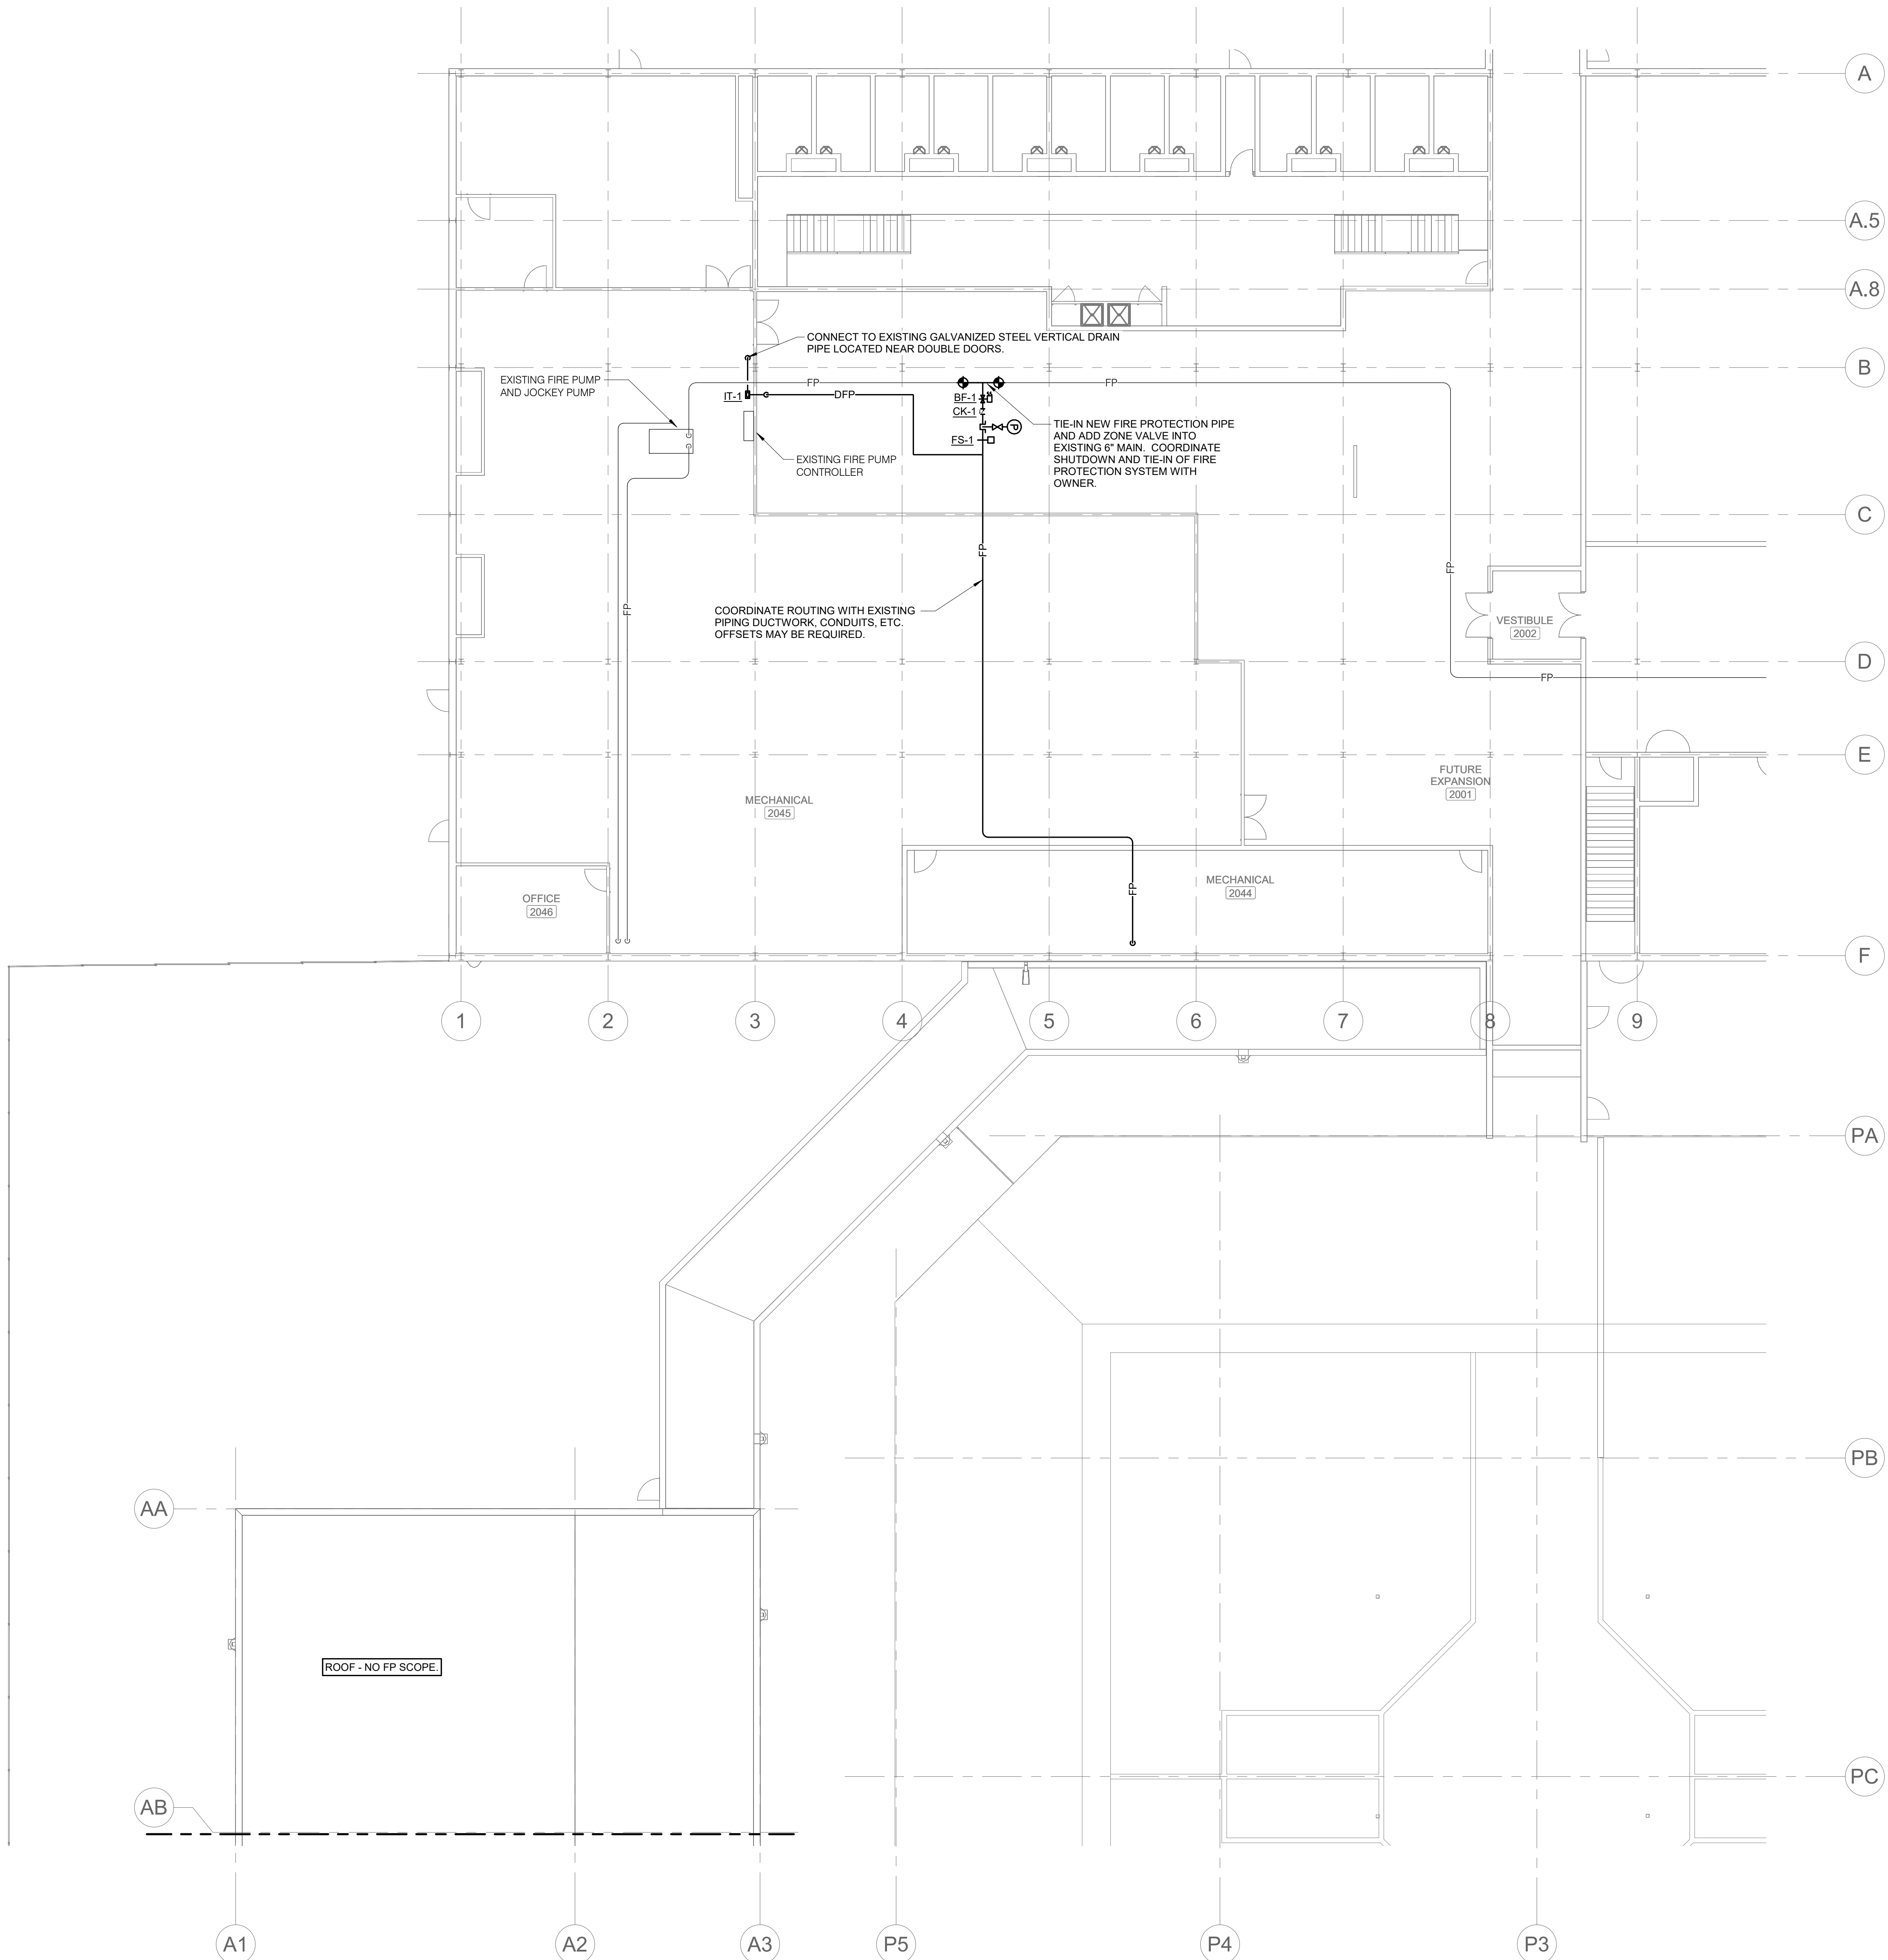

1 LEVEL 02 PLAN - AREA A - FIRE PROTECTION
3/32" = 1'-0"

IMEG
2882 10TH STREET
DES MOINES, IA 50322
P: 515.334.9900 F: 515.334.9908
www.imegcorp.com
IMEG CORP. RESERVES PROPRIETARY RIGHTS, INCLUDING COPYRIGHTS, TO THIS DRAWING AND THE DATA SHOWN THEREIN. SAID DRAWING AND/OR DATA ARE THE EXCLUSIVE PROPERTY OF IMEG CORP. AND SHALL NOT BE USED OR REPRODUCED FOR ANY OTHER PROJECT WITHOUT THE EXPRESS WRITTEN APPROVAL AND PARTICIPATION OF IMEG CORP. ©2024 IMEG CORP.

0 1 2 3
REF. SCALE IN INCHES PROJECT #21007888.00

Farnsworth GROUP
14225 UNIVERSITY AVENUE, SUITE 110
WALKEE, IOWA 50263
(515) 225-3469 / info@f-w.com
www.f-w.com
Engineers | Architects | Surveyors | Scientists

RIPPE ASSOCIATES
FOODSERVICE DESIGN + CONSULTING

kpff

IMEG

Bishop Engineering

ISSUE:	#	DATE:	DESCRIPTION:
--------	---	-------	--------------

BID SET

PROJECT:
STATE OF IOWA - DEPARTMENT
OF CORRECTIONS

**CLARINDA
CORRECTIONAL
FACILITY - KITCHEN &
LAUNDRY ADDITION**

2000 N 16TH ST, CLARINDA, IA
51632


DATE:	02/09/2024
DESIGNED:	MIKMCC
DRAWN:	MIKMCC
REVIEWED:	DELLE

SHEET TITLE:
**LEVEL 02 PLAN -
AREA A - FIRE
PROTECTION**

SHEET NUMBER:


F1.3

PROJECT NO.: 0240202.00
RFB922300-02

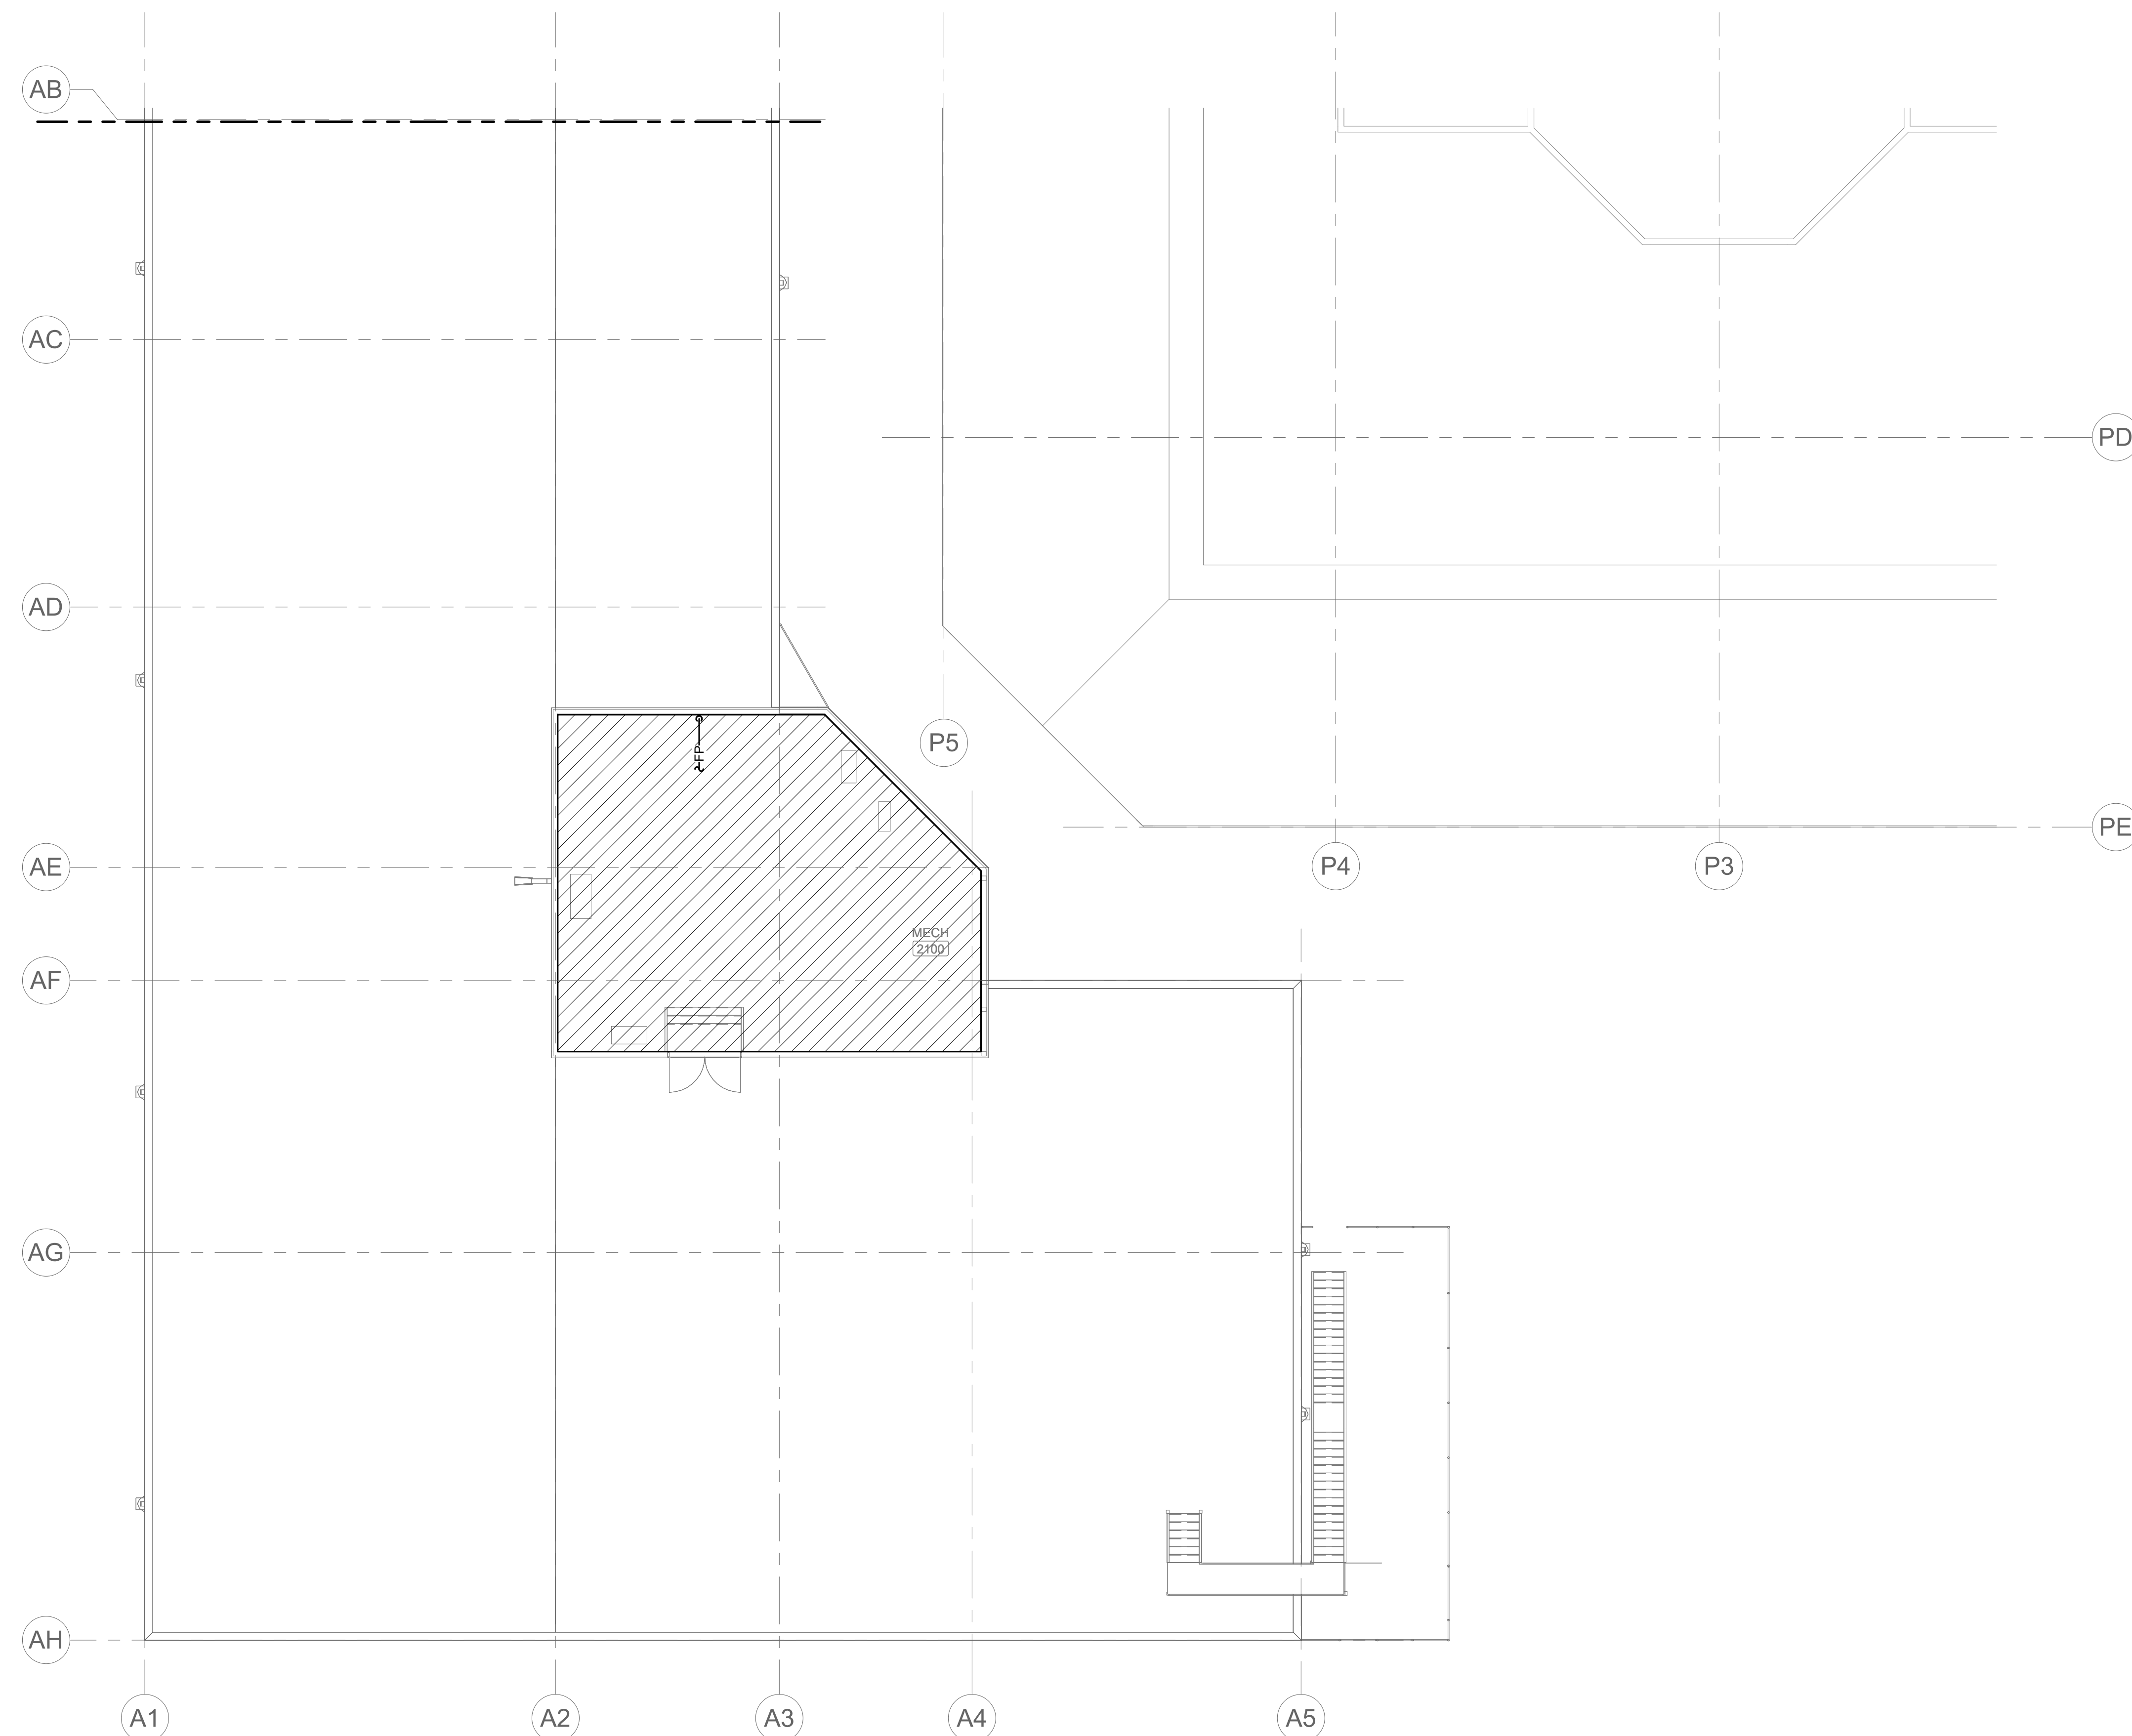

GENERAL NOTES:

1. REFER TO F4.1 FOR SPRINKLER USAGE SCHEDULE AND FIRE PROTECTION MATERIAL LIST
2. REFER TO F0.0 FOR GENERAL FIRE PROTECTION NOTES.

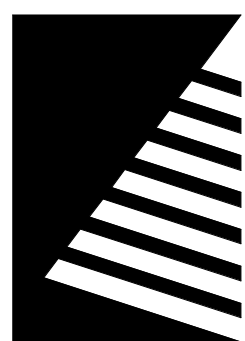

RIPPE ASSOCIATES
FOODSERVICE DESIGN + CONSULTING

kpff



Bishop Engineering

ISSUE:	#	DATE:	DESCRIPTION:
--------	---	-------	--------------

BID SET

PROJECT:
STATE OF IOWA - DEPARTMENT
OF CORRECTIONS

**CLARINDA
CORRECTIONAL
FACILITY - KITCHEN &
LAUNDRY ADDITION**

2000 N 16TH ST, CLARINDA, IA
51632

DATE: 02/09/2024

DESIGNED: MIKMCC

DRAWN: MIKMCC

REVIEWED: _____ DELLE _____

SHEET TITLE:

**LEVEL 02 PLAN -
AREA B - FIRE
PROTECTION**

SHEET NUMBER: _____

F1.4

PROJECT NO.: 0240202.0
RFB922300-0




IMEG 2882 100TH STREET
DES MOINES, IA 50322
P: 515.334.9008 F: 515.334.9009

www.imegcorp.com

IMEG CORP. RESERVES PROPRIETARY RIGHTS, INCLUDING COPYRIGHT TO THIS DRAWING AND THE DATA SHOWN THEREON. SAID DRAWING AND/OR DATA ARE THE EXCLUSIVE PROPERTY OF IMEG CORP. AND SHALL NOT BE USED OR REPRODUCED FOR ANY OTHER PROJECT WITHOUT THE EXPRESS WRITTEN APPROVAL AND PARTICIPATION OF IMEG CORP. ©2004 IMEG CORP.

0 1 2 3 4 5 6 7 8 9 10
FEET SCALE IN INCHES

PROJECT #11007688.00

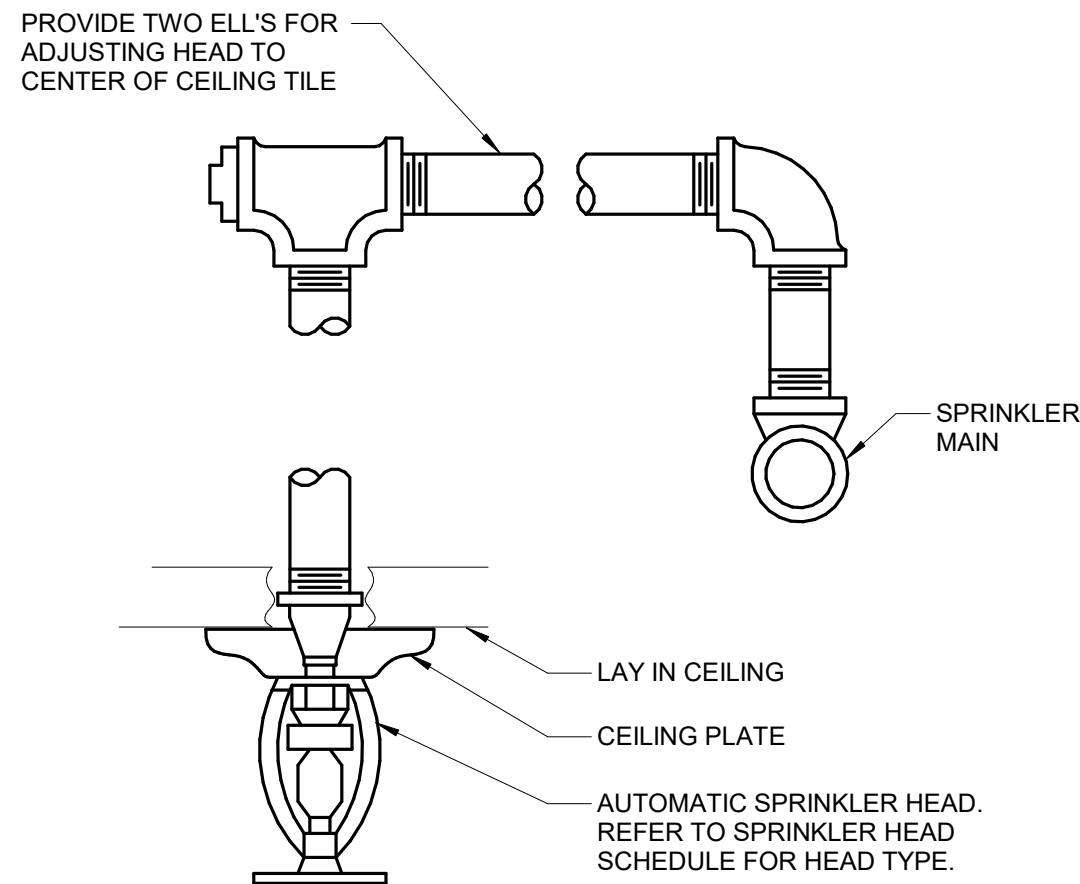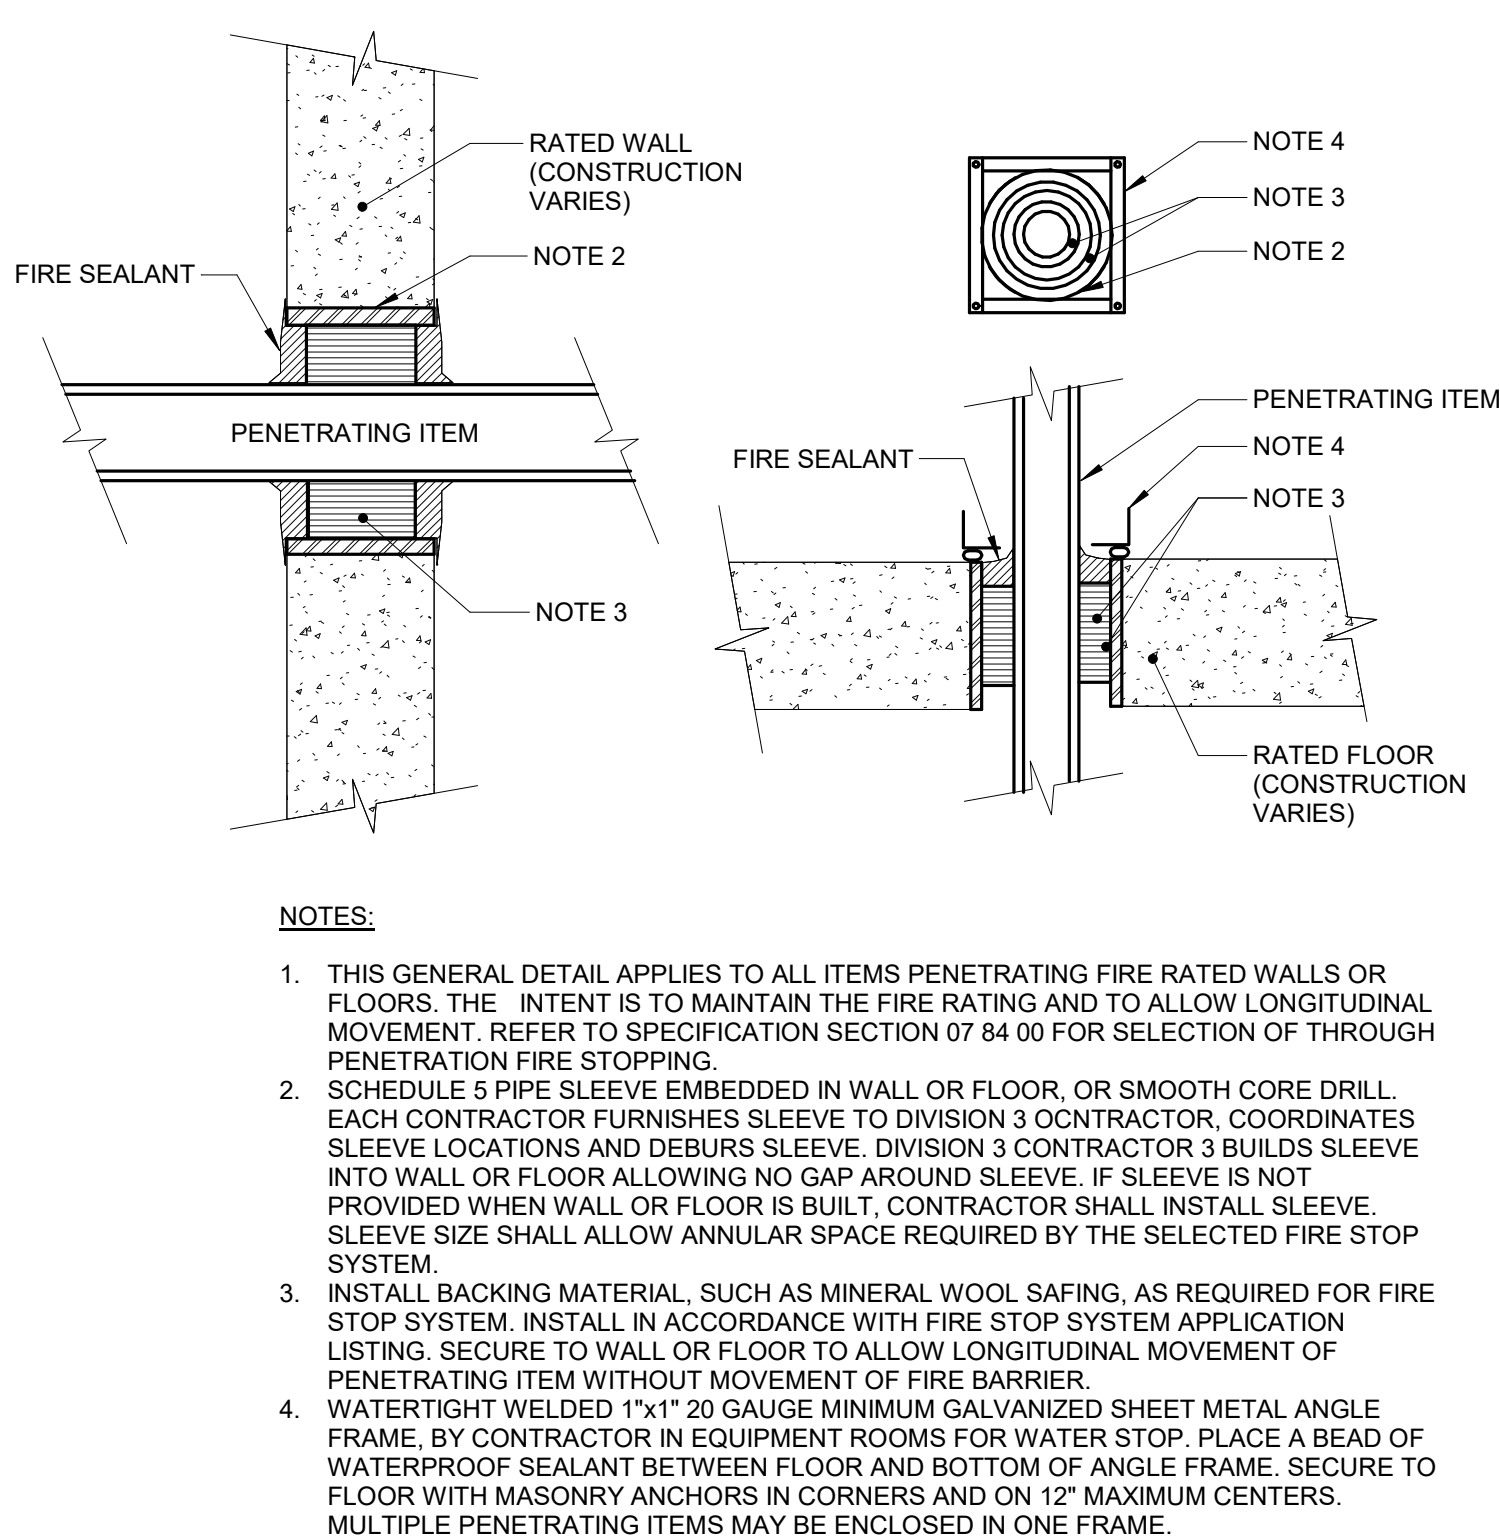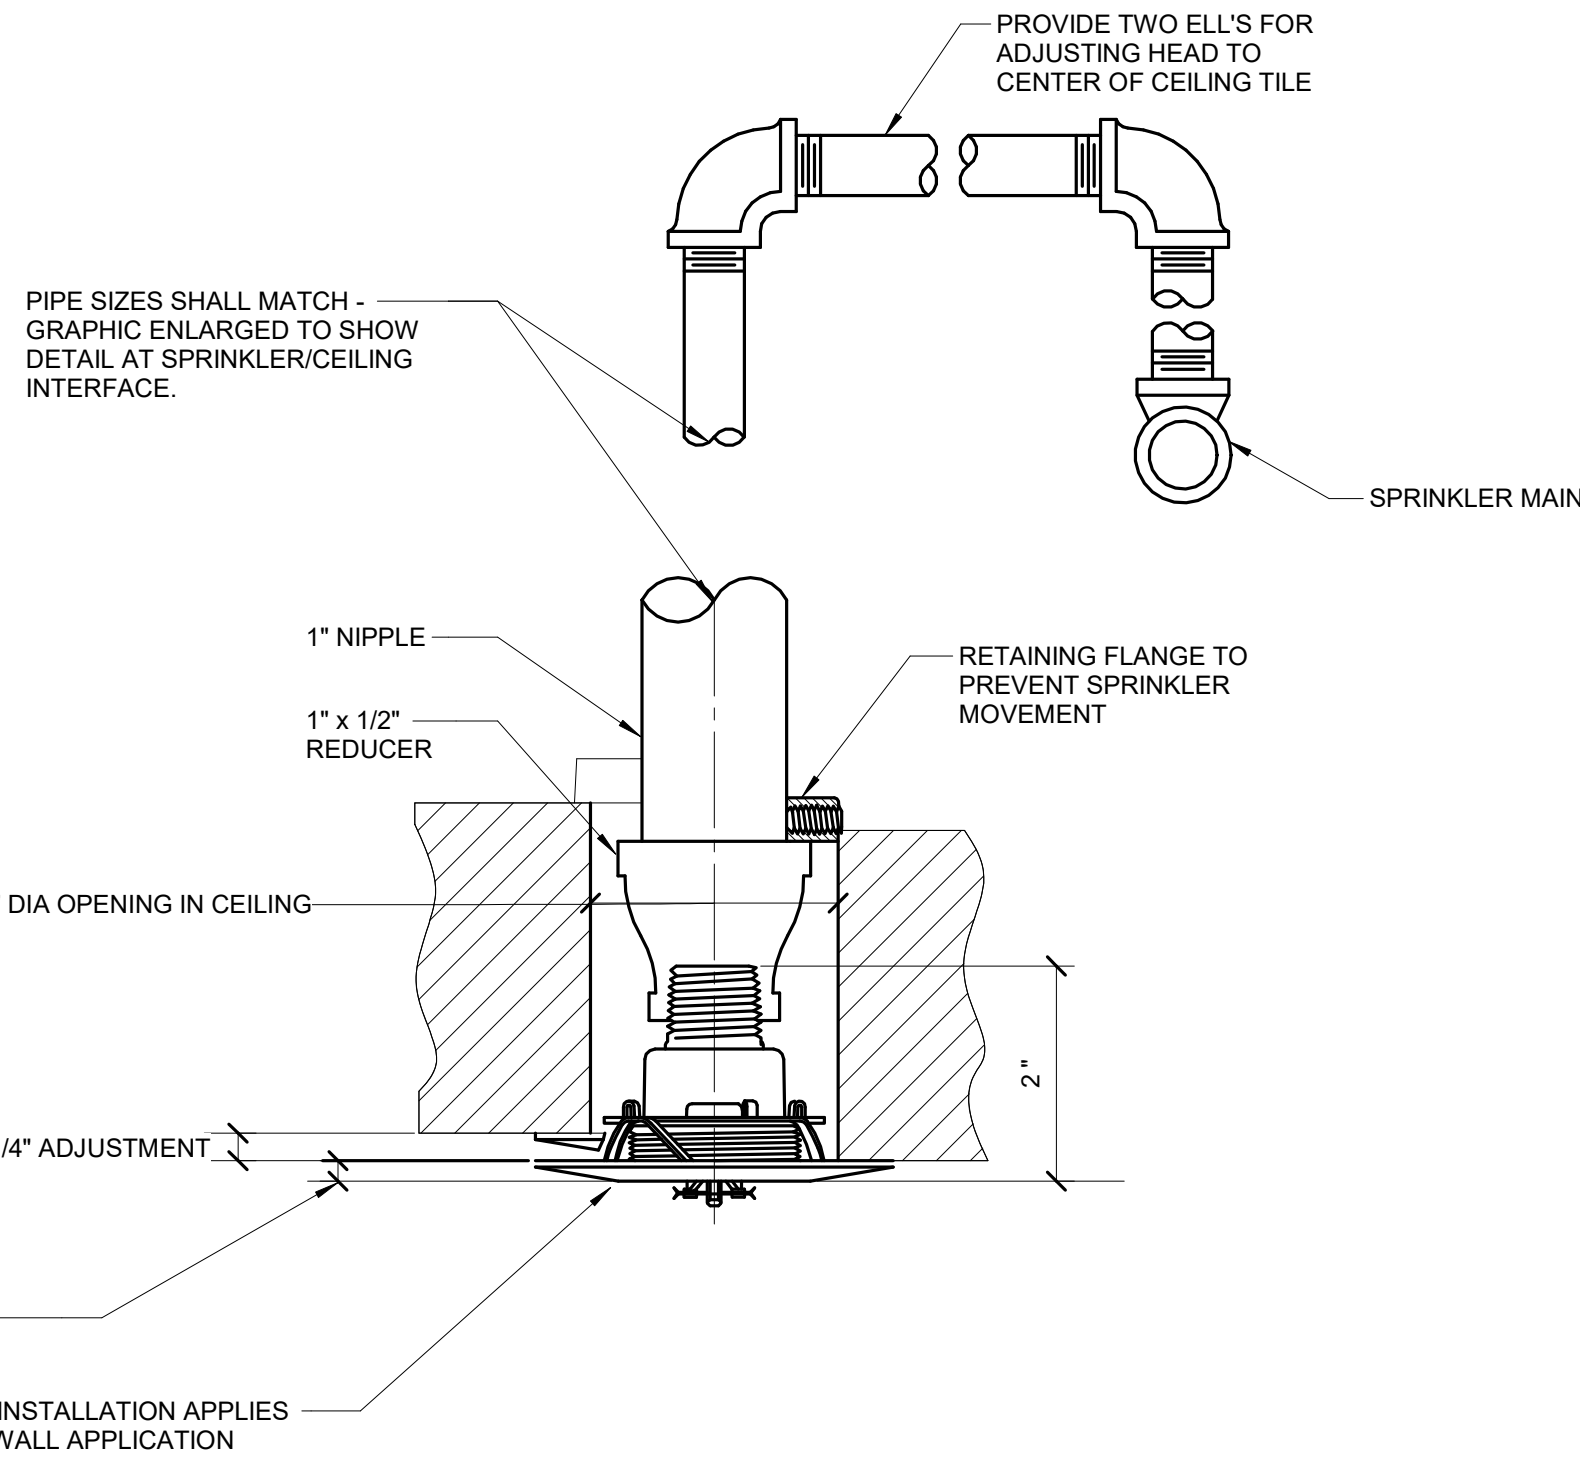

1 INSTITUTIONAL QUICK RESPONSE STANDARD COVERAGE FLUSH PENDENT SPRINKLER DETAIL
NO SCALE

2 FLOOR/WALL PENETRATION - RATED FIRE BARRIER
NO SCALE

4 DRY SPRINKLER HEAD MOUNTING DETAIL
NO SCALE

FIRE SPRINKLER USAGE SCHEDULE								
NOTES: 1. SEE FLOOR PLANS FOR ZONING REQUIREMENTS. 2. SPRINKLER SHALL HAVE COLOR CODED BULB THERMAL ELEMENT. 3. ALL SPRINKLERS SHALL BE UL LISTED. 4. CONTRACTOR TO VERIFY SPRINKLER REQUIREMENTS BASED ON ACTUAL INSTALLATION, USAGE, ARCHITECTURAL CEILING PLAN AND NFPA 13 REQUIREMENTS. 5. TAG NAME IS PRIMARILY FOR IDENTIFYING SPRINKLERS IN SUBMITTALS. IT MAY OR MAY NOT BE FOUND ELSEWHERE ON THE DRAWINGS. CONTRACTOR TO SUBMIT ALL SPRINKLER TYPES TO BE USED. 6. AREAS ARE GENERAL IN NATURE. CONTRACTOR TO MATCH UNSCHEDULED AREAS TO SIMILAR SPACES. 7. SPRINKLERS SHALL HAVE A 3mm QUICK RESPONSE BULB. 8. SPRINKLERS SPECIFIED WITHIN FIRE SPRINKLER USAGE SCHEDULE ARE STANDARD COVERAGE TYPE. EXTENDED COVERAGE SPRINKLERS ARE PERMITTED PROVIDED SPRINKLERS MEET THE REQUIREMENTS OF UL.								
AREA TYPE (NOTE 1 & 6)	AREA HAZARD	SPRINKLER (NOTE 4 & 5)			TEMPERATURE RATING	MANUFACTURER & MODEL	NOTES	
AREAS WITHOUT CEILING UNLESS NOTED OTHERWISE	SEE PLANS	SPR-1	UPRIGHT	QUICK	ROUGH BRASS	PER NFPA VIKING VK, RELIABLE F1FR, TYCO TY-FRB, VICTAULIC V2704	NOTE 2, 3, 7, 8	
AREAS WITH CEILINGS UNLESS NOTED OTHERWISE	SEE PLANS	SPR-2	INSTITUTIONAL PENDENT	QUICK	WHITE	PER NFPA TYCO RAVEN, VIKING VK426	NOTE 2, 3, 7, 8	
SIDEWALL APPLICATIONS	SEE PLANS	SPR-3	INSTITUTIONAL SIDEWALL	QUICK	WHITE	PER NFPA TYCO RAVEN, VIKING VK427	NOTE 2, 3, 7, 8	
COOLER AND FREEZER AREAS, DRYER CHASE	SEE PLANS	SPR-4	DRY CONCEALED W/ WHITE FLAT COVERPLATE	QUICK	WHITE	PER NFPA VIKING VK, RELIABLE F3QR, VICTAULIC V3618	NOTE 2, 3, 7, 8	
DRYER CHASE	SEE PLANS	SPR-5	DRY SIDEWALL	QUICK	ROUGH BRASS	PER NFPA VIKING VK, RELIABLE F3QR, TYCO DS, VICTAULIC V3610	NOTE 2, 3, 7, 8	


FIRE PROTECTION MATERIAL LIST		
TAG NAME	DESCRIPTION	MANUFACTURER AND MODEL
BF-1	INDICATING BUTTERFLY VALVE, NORMALLY OPEN, 175 PSI WWP, GROOVED TYPE, DUCTILE IRON BODY WITH PROTECTIVE COATING, ELECTROLESS NICKEL OR EPDM COATED DUCTILE IRON DISC, STAINLESS STEEL STEM AND SCREWS, CAST OR DUCTILE IRON HANDWHEEL, EPDM SEAT, INDICATOR FLAG, FACTORY MOUNTED INTEGRAL MONITOR SWITCHES, UL/FM.	NIBCO GD-476S-8N, VICTAULIC SERIES 705, TYCO BPN-300, KENNEDY G300, GLOBE GLR300G, REL-BFG-300
CK-1	SWING CHECK VALVE, 300 PSI WWP, GROOVED/FLANGED TYPE, DUCTILE IRON BODY, STAINLESS STEEL HINGE ASSOCIATED WITH RUBBER FACED CLAPPER, BRASS SEAT RING, ACCESS COVER, 1/2" OR 3/4" TAPPED BOSSES, VALVE LISTED FOR HORIZONTAL OR VERTICAL INSTALLATION, UL/FM.	VIKING G-1, TYCO CV-1F
FS-1	FLOW SWITCH - VANE TYPE, 450 PSI, FLOW SENSITIVITY OF 4-10 GPM, TWO SINGLE POLE DOUBLE THROW SWITCHES, PNEUMATIC RETARD ADJUSTABLE FROM 0-90 SECONDS WITH AUTOMATIC RESET, NEMA 4 INDOOR/OUTDOOR RATED METAL HOUSING, UL/FM.	POTTER VSR, SYSTEM SENSOR WFD
IT-1	COMBINATION INSPECTOR'S TEST AND DRAIN VALVE, 300 PSI, INTEGRAL SIGHT GLASS, BALL VALVE PLATE INDICATING OFF-TEST-DRAIN POSITIONS, FURNISHED WITH TEST ORIFICE GIVING FLOW EQUIVALENT TO ONE SPRINKLER OF A TYPE HAVING THE SMALLEST ORIFICE INSTALLED ON THE SYSTEM, PRESSURE RELIEF VALVE, UL/FM.	AGF M1011A, RELIABLE MODEL TD, VICTAULIC TESTMASTER, GLOBE UTD W/ MODEL ARV PRV



2882 10TH STREET
DES MOINES, IA 50322
P: 515.334.9900 F: 515.334.9908


www.imegcorp.com

 IMEG CORP. RESERVES PROPRIETARY RIGHTS, INCLUDING COPYRIGHTS, TO THIS DRAWING AND THE DATA SHOWN THEREIN. SAID DRAWING AND/OR DATA ARE THE EXCLUSIVE PROPERTY OF IMEG CORP. AND SHALL NOT BE USED OR REPRODUCED FOR ANY OTHER PROJECT WITHOUT THE EXPRESS WRITTEN APPROVAL AND PARTICIPATION OF IMEG CORP. ©2024 IMEG CORP.



REF. SCALE IN INCHES

PROJECT #21007888.00

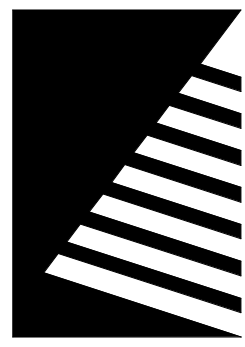

Farnsworth
GROUP

14225 UNIVERSITY AVENUE, SUITE 110
WALKEE, IOWA 50263
(515) 225-3469 / info@f-w.com

www.f-w.com

Engineers | Architects | Surveyors | Scientists

RIPPE ASSOCIATES
FOODSERVICE DESIGN + CONSULTING

kpff

IMEG

Bishop Engineering

ISSUE:
DATE: DESCRIPTION:

BID SET

PROJECT:
STATE OF IOWA - DEPARTMENT
OF CORRECTIONS

**CLARINDA
CORRECTIONAL
FACILITY - KITCHEN &
LAUNDRY ADDITION**

2000 N 16TH ST, CLARINDA, IA
51632

DATE: 02/09/2024
DESIGNED: MIKMCC
DRAWN: MIKMCC
REVIEWED: DELLLE

SHEET TITLE:
**FIRE PROTECTION
DETAILS &
SCHEDULES**

SHEET NUMBER:

F4.1

PROJECT NO.: 0240202.00
RFB922300-02

NAME

10'-0"

LEVEL NAME

HEIGHT ABOVE PROJECT 0'-0"

INDICATES NOTE USED TO DESCRIBE ADDITIONAL INFORMATION ABOUT WORK REQUIRED, SPECIFIC TO THE SHEET AND/OR DETAIL

INDICATES DIRECTION OF TRUE NORTH

PLAN OR DETAIL NUMBER

PLAN OR DETAIL NAME

1

VIEW NAME

1/8" = 1'-0"

PLAN OR DETAIL SCALE

SIM

INDICATES SIMILAR DETAIL REFERENCED IN MULTIPLE LOCATIONS

DETAIL REFERRED TO BY SECTION CUT

SHEET DETAIL IS LOCATED ON

T101

LINE TYPE AND TAG KEY:

NEW WORK BY THIS CONTRACTOR (WIDE LINE)

NEW

EXISTING TO BE REMOVED (SHORT DASHED PATTERN)

NEW UNDERFLOOR OR UNDERGROUND (LONG DASHED PATTERN)

EXISTING TO REMAIN OR WORK BY OTHERS (NARROW LINE)

EXISTING TO BE REMOVED BY OTHERS (SHORT DASHED PATTERN)

EXISTING UNDERFLOOR OR UNDERGROUND (LONG DASHED PATTERN)

HALFTONING DOES NOT MODIFY SCOPE

TAG-E

TAGS WITH DASH 'E' INDICATES THE REFERENCED OBJECT IS EXISTING

TAG

UNDERLINED TAG INDICATES OBJECT IS IN-SCOPE. IF NEW, ADDITIONAL INFORMATION IS AVAILABLE IN A SCHEDULE, MATERIAL LIST, OR SYMBOL LIST

INDICATES AN EXISTING SYSTEM'S POINT OF CONNECTION/REMOVAL

INDICATES A PLUMBING CONNECTION TO A FOOD SERVICE EQUIPMENT REFERENCE FOOD SERVICE DRAWINGS FOR ADDITIONAL INFORMATION IN REGARDS TO TYPE OF EQUIPMENT, ROUGH-IN SIZES, AND ADDITIONAL COMMENTS

APPLICABLE CODES

CONTRACTOR SHALL COMPLY WITH APPLICABLE CODES AND LOCAL AMENDMENTS.

BUILDING CODE:

IBC 2015 EDITION

FIRE CODE:

IFC 2015 EDITION

PLUMBING CODE:

UPC 2021 EDITION

MECHANICAL CODE:

IMC 2021 EDITION

ELECTRICAL CODE:

NFPA 70 (NEC) 2020 EDITION

LIFE SAFETY CODE:

NFPA 101 2012 EDITION

ENERGY CONSERVATION CODE:

IECC 2012

HEALTH DEPARTMENT CODE:

CURRENT EDITION

LOCAL BUILDING CODE:

CURRENT EDITION

CONTRACTOR ABBREVIATION KEY

ABBR:	DESCRIPTION:
C.C.	CIVIL CONTRACTOR
C.M.	CONSTRUCTION MANAGER
E.C.	ELECTRICAL CONTRACTOR
F.P.C.	FIRE PROTECTION CONTRACTOR
FSEC	FOOD SERVICE EQUIPMENT CONTRACTOR
M.C.	MECHANICAL CONTRACTOR
P.C.	PLUMBING CONTRACTOR
S.C.	SECURITY CONTRACTOR
T.C.	TECHNOLOGY CONTRACTOR
T.C.C.	TEMPERATURE CONTROLS CONTRACTOR

CONTACT PERSONS:

DESCRIPTION:	PERSON:
PROJECT MANAGER	MIKE MCCARTY
MECHANICAL	MIKE MCCARTY
ELECTRICAL	KRISTEN SPINA
TECHNOLOGY	MIKE MCCARTY

PLUMBING SYMBOL LIST

NOT ALL SYMBOLS MAY APPLY.

SYMBOL:	DESCRIPTION:
—AV—	ACID VENT
—AW—	ACID WASTE
—CA—	COMPRESSED AIR
—CW—	COLD WATER - POTABLE
—D—	DRAIN
—DI—	DEIONIZED WATER
—DT—	DRAIN TILE
—FOR—	FUEL OIL RETURN
—FOS—	FUEL OIL SUPPLY
—G—	NATURAL GAS
—GRV—	GAS REGULATOR VENT
—GSAN—	SANITARY DRAINAGE (GREASE SANITARY DRAINAGE)
—GV—	GREASE VENT
—HW—	HOT WATER - POTABLE
—HWC—	HOT WATER CIRCULATING - POTABLE
—HW140—	HOT WATER - POTABLE NUMBER INDICATES TEMP
—HWC140—	HOT WATER CIRC. - POTABLE NUMBER INDICATES TEMP
—IA—	INSTRUMENT AIR
—MA—	MEDICAL AIR
—MFG—	MEDIUM PRESSURE GAS
—MV—	MEDICAL VACUUM
—N—	NITROGEN
—NCW—	NON-POTABLE COLD WATER
—NHW—	NON-POTABLE HOT WATER
—NO—	NITROUS OXIDE
—O—	OXYGEN
—P—	PROPANE GAS
—PD—	PUMPED DISCHARGE
—PW—	PURE WATER
—RO—	REVERSE OSMOSIS WATER
—SAN—	SANITARY DRAINAGE
—SCW—	SOFT COLD WATER
—SHW—	SOFT HOT WATER
—ST1 (1,000)—	STORM DRAINAGE (ROOF SQUARE FOOTAGE)
—STS—	STORM DRAINAGE (SECONDARY)
—STW—	SOFT TEMPERED WATER
—TW—	TEMPERED WATER
—V—	VENT
—VAC—	LAB VACUUM
—W—	SERVICE WATER - POTABLE
—WAGD—	WASTE ANESTHESIA GAS DISPOSAL
→	PIPE CONTINUATION
—	PIPE CAP
↓	PIPE DOWN
↑	PIPE UP OR UP/DOWN
○	PIPE SERVING FIXTURE ON FLOOR ABOVE (EXAMPLE: FD = FLOOR DRAIN)
→○	PITCH PIPE IN DIRECTION
→	DIRECTION OF FLOW IN PIPE
→	ROUTE TO DRAIN
RD-1 (1/1000)	ROOF DRAIN PROPERTIES SYMBOL SIZE (ROOF SQ. FT.)
—H—	DIELECTRIC CONNECTION
—	UNION/FLANGE
—	SHUTOFF VALVE NORMALLY OPEN
—	SHUTOFF VALVE NORMALLY CLOSED
—GPM—	BALANCING VALVE (NUMBER INDICATES GPM)
—	CHECK VALVE
→	BACKFLOW PREVENTER
→	SOLENOID VALVE
→	SAFETY/RELIEF VALVE
→	VACUUM BREAKER
→	PRESSURE GAUGE (FURNISHED WITH BALL VALVE)
→	PRESSURE SENSOR (FURNISHED WITH BALL VALVE)
→	TEMPERATURE SENSOR WITH WELL
→	THERMOMETER WITH WELL (DIAL TYPE)
→	THERMOMETER WITH WELL (FILLED TYPE)
→	REDUCER - REFERENCE SPECIFICATION FOR CONCENTRIC/ECCENTRIC AND POT/FOB
→	PRESSURE REDUCING VALVE (LIQUID/GAS)
→	PUMP
→	METER
→	ALIGNMENT GUIDE
→	PIPE ANCHOR
→	EXPANSION JOINT #.#" IS THE EXPANSION TRAVEL INCHES
→	AIR ADMITTANCE VALVE

PLUMBING ABBREVIATION KEY

ABBR:	DESCRIPTION:
AD	ACCESS DOOR
AFF	ABOVE FINISHED FLOOR
BFP	BACKFLOW PREVENTER
BATHUB	BATHTUB
CB	CATCH BASIN
CI	CAST IRON
CO	CLEANOUT
CS	CUNICAL SINK
DB	DIALYSIS BOX
DI	DRINKING FOUNTAIN
DF	DUCTILE IRON
E	EXISTING
EE	EMERGENCY EYEWASH
ES	EMERGENCY SHOWER
ESE	EMERGENCY SHOWER/EYEWASH
EW	ELECTRIC WATER COOLER
FCO	FLOOR CLEANOUT
FD	FLOOR DRAIN
FM	FLOOR METER
FS	FLOOR SINK
FSP	FOOD SERVICE PLANS
GD	GARBAGE DISPOSER
GI	GREASE INTERCEPTOR
HB	HOSE BIBB
IE	INVERT ELEVATION (FOR REFERENCE ONLY)
IW	INDIRECT WASTE
LAV	LAVATORY
MB	MOP BASIN
MH	MANHOLE
MV	MIXING VALVE
NIC	NOT IN CONTRACT
NT	NEUTRALIZATION TANK
OS	OIL SEPARATOR
RD	ROOF DRAIN
SCCR	SHORT CIRCUIT CURRENT RATING
SH	SHOWER
SK	SINK
SS	SERVICE SINK
TD	TRENCH DRAIN
TP	TRAP PRIMER
TYR	TYPICAL
UR	URNAL
VTR	VENT THROUGH ROOF
WC	WATER CLOSET
WCO	WALL CLEANOUT
WF	WASH FOUNTAIN
WH	WATER HEATER
WMF	WASHING MACHINE FIXTURE
WM	WATER METER
WS	WATER SOFTENER
UB	UTILITY BOX
YCN	UNLESS OTHERWISE NOTES
YD	YARD CLEANOUT

PLUMBING ROUGH-IN SCHEDULE

NOTES: (APPLIES TO ALL PLUMBING FIXTURES LISTED BELOW)
1) SIZES SHOWN ARE MINIMUMS. LARGER SIZES SHOWN ON THE DRAWING SHALL DICTATE THE ROUGH-IN SIZE. 2) SANITARY RISERS UP IN WALL TO FIXTURES SHALL BE A MINIMUM OF 2". 3) DOMESTIC WATER BRANCH PIPING OUTSIDE OF THE WALL/CHASE SHALL BE A MINIMUM OF 3/4" UNLESS NOTED OTHERWISE. ONLY THE FINAL RISE/DROP SHALL BE SMALLER. 4) FINAL SANITARY SIZE SHALL MATCH P-TRAP SIZE (REFER TO MATERIAL LIST).

TAG NAME	DESCRIPTION	COLD WATER	HOT WATER	SANITARY	VENT
EE-1	EMERGENCY EYE-FACE WASH	1/2"	1/2"	2"	1 1/2"
FD-1	FLOOR DRAIN	-	-	2"	1 1/2"
FD-2	FLOOR DRAIN	-	-	2"	1 1/2"
FD-3	FLOOR DRAIN	-	-	4"	2"
FD-4	FLOOR DRAIN	-	-	3"	1 1/2"
FS-1	FLOOR SINK	-	-	3"	1 1/2"
FS-2	FLOOR SINK	-	-	4"	2"
FS-3	FLOOR SINK	-	-	3"	1 1/2"
FSE-18	HAND SINK, REFER TO FSP.	1/2"	1/2"	1 1/2"	1 1/2"
FSE-22	WORK COUNTER WITH SINK, REFER TO FSP.	1/2"	1/2"	2" IW	-
FSE-62	WORK COUNTER WITH SINK, REFER TO FSP.	1/2"	1/2"	2" IW	-
FSE-64	HOSE REEL, REFER TO FSP.	1/2"	1/2"	-	-
FSE-68	HAND SINK, REFER TO FSP.	1/2"	1/2"	1 1/2"	1 1/2"
FSE-74	ROLL IN PROOFER, REFER TO FSP.	1/2"	-	3/4" IW	-
FSE-87	RACK OVEN, REFER TO FSP.	1/2"	-	3/4" IW	-
FSE-91	ICE MAKER, REFER TO FSP.	3/8"	-	1/2" IW	-
FSE-100	HAND SINK, REFER TO FSP.	1/2"	1/2"	1 1/2"	1 1/2"
FSE-104	WORK COUNTER WITH SINK, REFER TO FSP.	1/2"	1/2"	2" IW	-
FSE-107	SPRAY RINSE, REFER TO FSP.	3/4"	1/2"	-	-
FSE-118	HOSE STATION, REFER TO FSP.	1/2"	1/2"	-	-
FSE-145	WORK COUNTER WITH SINK, REFER TO FSP.	1/2"	1/2"	2" IW	-
FSE-146	WORK COUNTER WITH SINK, REFER TO FSP.	1/2"	1/2"	2" IW	-
FSE-154	HOSE REEL, REFER TO FSP.	1/2"	1/2"	-	-
FSE-155	HOSE REEL, REFER TO FSP.	1/2"	1/2"	-	-
FSE-158	STEAMER, REFER TO FSP.	3/4"	-	1 1/2" IW	-
FSE-160	STEAMER, REFER TO FSP.	3/4"	-	1 1/2" IW	-
FSE-161	STEAMER, REFER TO FSP.	3/4"	-	1 1/2" IW	-
FSE-162	HOSE REEL, REFER TO FSP.	1/2"	1/2"	-	-
FSE-163	RACK OVEN, REFER TO FSP.	1/2"	-	3/4" IW	-
FSE-173	POT & PAN SINK, REFER TO FSP.	3/4"	3/4"	2" IW	-
FSE-175	SPRAY RINSE, REFER TO FSP.	3/4"	1/2"	-	-
FSE-184	HOSE REEL, REFER TO FSP.	1/2"	1/2"	-	-
FSE-184	HOSE REEL, REFER TO FSP.	1/2"	1/2"	-	-
FSE-185	EYE/FACE WASHER, REFER TO FSP.	1/2"	1/2"	-	-
FSE-189	DISHWASHER, REFER TO FSP.	3/4"	1"	2" IW	-
FSE-191	SPRAY RINSE, REFER TO FSP.	3/4"	1/2"	-	-
L-1	LAVATORY (ACCESSIBLE)	1/2"	1/2"	1 1/2"	1 1/2"
L-2	LAVATORY (ACCESSIBLE)	1/2"	1/2"	1 1/2"	1 1/2"
MB-1	MOP BASIN	3/4"	3/4"	3"	1 1/2"
MBT-1	MOP BASIN FAUCET	3/4"	3/4"	-	-
SK-1	SINK (ACCESSIBLE)	1/2"	1/2"	1 1/2"	1 1/2"
TD-1	TRENCH DRAIN	-	-	6"	3"
TD-2	TRENCH DRAIN	-	-	6"	3"
WC-1	WATER CLOSET (ACCESSIBLE)	1 1/2"	-	4"	2"
WC-2	WATER CLOSET (ACCESSIBLE)	1 1/2"	-	4"	2"
WMF-1	UTILITY BOX (WASHING MACHINE)	3/4"	3/4"	2"	1 1/4"

MECHANICAL RENOVATION NOTES:

THESE NOTES APPLY TO ALL MECHANICAL SHEETS AND TRADES, INCLUDING BUT NOT LIMITED TO, FIRE PROTECTION, PLUMBING, VENTILATION, PIPING AND TEMPERATURE CONTROL.

- EXISTING CONDITIONS ARE SHOWN BASED ON INFORMATION OBTAINED FROM FIELD SURVEYS, EXISTING BUILDING DOCUMENTS, AND STAFF. VERIFY EXISTING CONDITIONS AND REPORT ANY CONFLICTS BEFORE PROCEEDING.
- NOT ALL EXISTING DUCTWORK AND PIPING IS SHOWN. VERIFY EXISTING CONDITIONS BEFORE STARTING WORK. NOTIFY ENGINEER OF ANY CONFLICTS WITH NEW WORK.
- FIELD VERIFY THE AVAILABLE CLEARANCES FOR DUCTWORK AND PIPING BEFORE FABRICATION. RISERS AND DROPS MAY BE NECESSARY BECAUSE OF EXISTING FIELD CONDITIONS.
- EACH CONTRACTOR SHALL FIELD VERIFY ACCESSIBILITY TO THE AREA OF THEIR WORK AND SHALL NOTIFY THE ARCHITECT/ENGINEER PRIOR TO BIDDING IF OTHER UTILITIES ARE REQUIRED TO BE REMOVED OR RELOCATED TO ALLOW ACCESS TO THEIR AREA OF WORK.
- EACH CONTRACTOR SHALL CUT AND PATCH ROOFS, WALLS, AND FLOORS ASSOCIATED WITH THEIR WORK.
- THIS CONTRACTOR IS RESPONSIBLE FOR REMOVAL AND REPLACEMENT OF CEILINGS, CEILING TILES, AND CEILING GRIDS ASSOCIATED WITH AREAS OF WORK REQUIRED BY THEIR WORK.
- WHERE EXISTING MECHANICAL SYSTEMS ARE LOCATED IN AREAS THAT CONFLICT WITH NEW EQUIPMENT, PIPING, OR DUCTWORK, EACH CONTRACTOR SHALL EITHER ARRANGE NEW EQUIPMENT, PIPING, OR DUCTWORK IN SUCH A FASHION THAT IT DOES NOT CONFLICT WITH EXISTING SYSTEMS, OR REWORK EXISTING MECHANICAL SYSTEMS TO ALLOW FOR INSTALLATION OF NEW EQUIPMENT, PIPING, OR DUCTWORK.
- PROVIDE TEMPORARY CONNECTIONS TO MAINTAIN EXISTING SYSTEMS IN SERVICE DURING CONSTRUCTION. MAINTAIN ACCESS TO EXISTING MECHANICAL INSTALLATIONS THAT REMAIN ACTIVE.
- OBTAIN PERMISSION FROM OWNER BEFORE SHUTTING DOWN ANY SYSTEM FOR ANY REASON. MAINTAIN SERVICE TO ALL COMPONENTS THAT ARE TO REMAIN UNTIL NEW SYSTEMS ARE INSTALLED.
- MAINTAIN EXISTING SYSTEM IN SERVICE UNTIL NEW SYSTEM IS COMPLETE AND READY FOR TIE IN AND SWITCHOVER. DRAIN SYSTEM ONLY TO MAKE SWITCHOVERS AND CONNECTIONS. OBTAIN PERMISSION FROM OWNER BEFORE PARTIALLY OR COMPLETELY DRAINING SYSTEM. MAKE CHANGEOVER TO NEW SYSTEMS WITH MINIMUM OUTAGE.
- DISCONNECT AND REMOVE MECHANICAL DEVICES AND EQUIPMENT SERVING EQUIPMENT THAT HAS BEEN REMOVED.

MECHANICAL GENERAL NOTES:

THESE NOTES APPLY TO ALL MECHANICAL SHEETS AND TRADES, INCLUDING BUT NOT LIMITED TO, FIRE PROTECTION, PLUMBING, VENTILATION, PIPING AND TEMPERATURE CONTROL.

- DRAWINGS SHOWING LOCATIONS OF EQUIPMENT, DUCTWORK, PIPING, ETC. ARE DIAGRAMMATIC AND MAY NOT ALWAYS REFLECT EXACT INSTALLATION CONDITIONS. DRAWINGS SHOW THE GENERAL ARRANGEMENT OF DUCTWORK, PIPING, EQUIPMENT, ETC., AND MAY NOT INCLUDE ALL OFFSETS AND FITTINGS REQUIRED FOR COMPLETE INSTALLATION. THE DRAWINGS SHALL BE FOLLOWED AS CLOSELY AS ACTUAL BUILDING CONSTRUCTION AND THE WORK OF OTHERS WILL PERMIT.
- DO NOT SCALE DRAWINGS. VERIFY ALL DIMENSIONS AND CLEARANCES FROM ARCHITECTURAL, STRUCTURAL, SUBMITTALS, AND OTHER APPROPRIATE DRAWINGS OR PHYSICALLY AT SITE. REVIEW ALL DRAWINGS, INCLUDING THOSE OF OTHER TRADES.
- COORDINATE ALL WORK WITH ALL OTHER TRADES PRIOR TO INSTALLATION TO PROVIDE CLEARANCES REQUIRED FOR OPERATION, MAINTENANCE, CODE COMPLIANCE, AND TO VERIFY NON-INTERFERENCE WITH OTHER WORK. DO NOT FABRICATE PRIOR TO VERIFICATION OF NECESSARY CLEARANCES FOR ALL TRADES. BRING ANY INTERFERENCES OR CONFLICTS TO THE ATTENTION OF THE ARCHITECT/ENGINEER BEFORE PROCEEDING WITH FABRICATION OR EQUIPMENT ORDERS.
- REVIEW SPACE REQUIREMENTS OF EQUIPMENT SPECIFIED OR SUBSTITUTED AND MAKE REASONABLE ACCOMMODATIONS IN LAYOUT AND POSITIONING TO PROVIDE PROPER ACCESS.
- ANY CHANGES REQUIRED TO ELIMINATE CONFLICTS OR THAT RESULT FROM A FAILURE TO COORDINATE SHALL BE MADE BY THE CONTRACTOR WITHOUT ADDITIONAL COST OR EXPENSE TO OTHERS.
- EACH CONTRACTOR IS RESPONSIBLE FOR ALL COSTS ASSOCIATED WITH ELECTRICAL CHARGES REQUIRED FOR EQUIPMENT PROPOSED THAT DIFFERS FROM THE BASIS OF DESIGN.
- REFER TO ARCHITECTURAL, REFLECTED CEILING PLAN, ELECTRICAL, TECHNOLOGY AUDIOVISUAL, AND OTHER MECHANICAL PLANS FOR EXACT LOCATIONS OF ALL CEILING MOUNTED DEVICES, OTHER THAN SPRINKLERS.
- EACH CONTRACTOR IS RESPONSIBLE FOR DAMAGE CAUSED BY THEIR ACTIONS TO WALLS, FLOORS, CEILINGS, AND ROOFS. THE CONTRACTOR WHOSE WORK CAUSES DAMAGE IS RESPONSIBLE FOR PATCHING TO MATCH ORIGINAL CONSTRUCTION, FIRE RATING, AND FINISH.
- IN AREAS WITH DRYWALL CEILINGS COORDINATE LOCATIONS OF ACCESS PANELS WITH THE DRY WALL CONTRACTOR FOR ACCESS TO VALVES, DUCTWORK ACCESSORIES, DAMPERS, ETC. COORDINATE PANEL TYPE AND COLOR WITH ARCHITECT. NOTIFY THE DRY WALL CONTRACTOR OF THE REQUIRED ACCESS PANELS PRIOR TO BIDDING.
- SEAL ALL FLOOR, WALL, AND ROOF PENETRATIONS AIRTIGHT WHERE CONDUITS, PIPING, AND DUCTS PENETRATE. PENETRATIONS THROUGH EXTERIOR WALLS AND ROOF SHALL BE SEALED AIRTIGHT WITH WATERPROOFING MATERIALS RECOMMENDED BY MANUFACTURER FOR OUTDOOR USE.
- CAULK ALL PIPE AND DUCT PENETRATIONS OF FULL HEIGHT NON-FIRE RATED WALL, PARTITION, FLOOR, AND ROOF ASSEMBLIES. THIS IS ESSENTIAL TO PREVENT NOISE TRANSMISSION FROM ONE ROOM TO ANOTHER AND TO PROVIDE THE DESIRED NC LEVELS WITHIN ROOMS.
- WHERE PIPES AND DUCTS ARE SHOWN TO PENETRATE FLOORS, PROVIDE SLEEVED OPENINGS WITH THE TOP EDGE RAISED ABOVE FLOOR SURFACE IN ACCORDANCE WITH ALL RELEVANT SPEQ SECTIONS. SEAL SLEEVE PERIMETER TO BE WATERTIGHT.
- EQUIPMENT SIZES AND SERVICE CLEARANCE REQUIREMENTS VARY AMONG DIFFERENT MANUFACTURERS. CONSULT APPROVED SHOP DRAWINGS FOR EQUIPMENT SIZES AND REQUIRED SERVICE CLEARANCES. COORDINATE WITH LAYOUT OF EQUIPMENT PADS, PIPING, DUCTWORK, ETC.
- DO NOT BLOCK TUBE PULL OR EQUIPMENT SERVICE CLEARANCES.
- MAINTAIN A MINIMUM WORKING CLEARANCE OF 3'-0" IN FRONT OF ALL ELECTRICAL EQUIPMENT REQUIRING MAINTENANCE, INSPECTION, AND TESTING INCLUDING BUT NOT LIMITED TO PANELS, DISTRIBUTION PANELS, SWITCHBOARDS, MOTOR CONTROL CENTERS, TRANSFORMERS, EQUIPMENT DISCONNECTS AND STARTERS.
- MAINTAIN THE DEDICATED ELECTRICAL EQUIPMENT SPACE DEFINED BY THE WIDTH / DEPTH OF ELECTRICAL EQUIPMENT MEASURED FROM THE FLOOR TO A HEIGHT 6'-0" ABOVE THE EQUIPMENT OR THE STRUCTURAL CEILING, WHICHEVER IS LOWER. SYSTEMS FOREIGN TO THE ELECTRICAL DISTRIBUTION SYSTEM ARE NOT ALLOWED IN THE DEDICATED ELECTRICAL SPACE INCLUDING, DUCTWORK, PIPING, ETC.
- PROVIDE CONCRETE EQUIPMENT PAD FOR ALL FLOOR MOUNTED EQUIPMENT. PAD SHALL EXTEND MINIMUM 6" BEYOND ALL SIDES OF EQUIPMENT.
- DO NOT SUPPORT EQUIPMENT, PIPING, OR DUCTWORK FROM METAL DECKING OR OTHER NON-STRUCTURAL BUILDING ELEMENTS. ANCHORS EMBEDDED IN CONCRETE SHALL BE CRACKED CONCRETE APPROVED IN ACCORDANCE WITH SPECIFICATIONS.

PLUMBING GENERAL NOTES:

1. THE SYMBOLS AND THE MATERIAL LIST ARE FOR THE CONVENIENCE OF THE CONTRACTOR. CONTRACTOR SHALL VERIFY QUANTITIES AND FURNISH ALL MATERIALS REQUIRED FOR FULLY OPERATIONAL SYSTEMS, WHETHER SPECIFIED OR NOT.

2. CATALOG NUMBERS SHALL NOT BE CONSIDERED COMPLETE, BUT ARE GIVEN AS AN AID TO THE CONTRACTOR AND TO INDICATE THE QUALITY REQUIRED. CONTRACTOR IS RESPONSIBLE FOR A COMPLETE DESCRIPTION OF MATERIAL ON THESE DRAWINGS AND IN THE SPECIFICATIONS BEFORE ORDERING. THE DESCRIPTION OF THE MATERIAL TAKES PRECEDENCE OVER THE CATALOG NUMBER. THE FIRST MANUFACTURER LISTED IS THE BASIS OF DESIGN.

3. CONTRACTOR SHALL VERIFY THAT FIXTURES SUPPLIED ARE APPROVED PER ALL APPLICABLE STATE, LOCAL AND GOVERNING AUTHORITIES.

4. ALL FIXTURES SHALL CONFORM TO FEDERAL ACT 5-3874.

5. INVERT ELEVATIONS ARE FROM EXISTING DRAWINGS AND MAY NOT BE ACCURATE. VERIFY ALL ELEVATIONS BEFORE BEGINNING WORK.

6. VERIFY UNDERGROUND PIPE SIZES, INVERT ELEVATIONS, AND LOCATIONS PRIOR TO BEGINNING ANY WORK.

7. REFER TO THE PLUMBING ROUGH-IN SCHEDULE FOR THE SIZES OF BRANCH PIPES TO PLUMBING FIXTURES.

8. EXISTING CONDITIONS ON DEMOLITION PLANS ARE PROVIDED TO INDICATE THE GENERAL SCOPE OF ITEMS TO BE REMOVED. REFER TO SPECIFICATION SECTION 22 05 05 FOR ADDITIONAL DEMOLITION INFORMATION.

9. P.C. SHALL CUT AND PATCH EXISTING AS REQUIRED FOR NEW OR DEMOLITION WORK UNLESS NOTED OTHERWISE. REFER TO SPECIFICATION SECTION 22 05 05 FOR ADDITIONAL INFORMATION.

10. P.C. SHALL REFERENCE ALL PLANS WITHIN DRAWINGS SET FOR SCOPE OF WORK. P.C. SHALL REVIEW FOOD SERVICE DRAWINGS FOR COORDINATION OF WORK BETWEEN P.C. AND FSEC.

11. P.C. SHALL PROVIDE ALL NECESSARY SHUT-OFF VALVES, PRESSURE REGULATORS, INDIVIDUAL EQUIPMENT SUPPLY STOPS, ETC. REQUIRED UPSTREAM OF FINAL SUPPLY CONNECTIONS TO FOOD SERVICE EQUIPMENT UNLESS NOTED OTHERWISE.

12. ALL INDIRECT WASTES FOR FOODSERVICE EQUIPMENT WILL BE EXTENDED TO FLOOR DRAINS BY MECHANICAL TRADES, EXCEPT FOR THE WALK-IN REFRIGERATOR/FREEZER BLOWER COIL. DRAINLINES AND DRAINLINES WITHIN THE CUSTOM FABRICATED COUNTERS WHICH WILL BE EXTENDED TO FLOOR DRAINS BY THE FSEC.

13. THE FSEC IS RESPONSIBLE FOR SETTING FOOD SERVICE EQUIPMENT IN PLACE. FINAL CONNECTIONS AND INTERCONNECTIONS FOR THIS EQUIPMENT ARE THE RESPONSIBILITY OF THE P.C.

14. SINK FAUCETS FURNISHED LOOSE BY FSEC FOR INSTALLATION BY P.C. SINK ROTARY DRAIN & OVERFLOW FURNISHED AND INSTALLED BY FSEC. TAILPIECE, P-TRAP, ESCUTCHEON PLATES AND DRAIN CONNECTION FURNISHED AND INSTALLED BY P.C. EXCEPT FOR TAILPIECE AND P-TRAP FOR WALL MOUNTED HANDSINKS WHICH ARE PROVIDED BY FSEC AND INSTALLED BY P.C.

15. HEALTH CODES REQUIRE THAT ALL PLUMBING BE ENCLOSED IN WALLS OR FLOOR AND THAT EXPOSED PIPING RUNS BE AS SHORT AS POSSIBLE. GAS PIPING TO BE SLEEVED AND VENTED PER CODE SO IT IS CONCEALED WITHIN THE WALL. EXPOSED HORIZONTAL PIPING MUST BE 6" ABOVE THE FLOOR AND AT LEAST 1" OFF THE WALL. ANY EXPOSED HAND SINK PIPING (BOTH DRAIN AND SUPPLY LINES) ARE TO BE CHROME PLATED.

16. RECOMMENDED HOT WATER TEMPERATURES FOR SINKS SHOULD AS FOLLOWS: POT & PAN SINKS SET AT 120° F MAXIMUM, HAND SINKS SET AT 110° F MAXIMUM AND ALL OTHER SINKS SET AT 110-120° F MAXIMUM. HOT WATER TEMPERATURES MUST CONFORM TO CODE REQUIREMENTS.

17. FLOOR TROUGHS NOTED ON FOOD SERVICE PLANS SHALL BE PROVIDED BY FSEC, INSTALLED BY P.C. REFER TO 6FS300 FOR FLOOR TROUGH DETAIL.

WATER HEATER SIZING:

1. KITCHEN WATER HEATER DEMAND
A. 3000 MEALS PER DAY SERVED
B. ASHRAE APPLICATIONS, CHAPTER 51 FOR SERVICE WATER HEATING, FIG. 20 - FOOD SERVICE INDICATES 1.5 GPH RECOVERY CAPACITY PER MAXIMUM MEALS PER HOUR
C. ESTIMATE 500 MEALS PER HOUR
D. 500*1.5 = 750 GPH RECOVERY CAPACITY REQUIRED FOR KITCHEN

2. LAUNDRY WATER HEATER DEMAND
A. AO SMITH ONLINE SIZING
B. COMMERCIAL LAUNDRY
C. (6) 100 LB WASHERS
D. PEAK DEMAND = 1680 GPH

3. MAXIMUM SYSTEM DEMAND:
A. KITCHEN = 750 GPH
B. LAUNDRY = 1680 GPH
C. TOTAL = 2,430 GPH

4. AVAILABLE SYSTEM CAPACITY:
A. WH-4 = 1572 GPH
B. WH-5 = 1572 GPH
C. TOTAL = 3144 GPH

PLUMBING SLOPE REQUIREMENTS:

BASIS ON PLUMBING CODE: UPC-2021

INTERIOR:	
SANITARY WASTE:	1/4" PER FOOT
GREASE WASTE:	1/4" PER FOOT
CONDENSATE AND INDIRECT DRAINAGE:	1/8" PER FOOT
SANITARY AND GREASE VENT:	NO SPECIFIC PITCH, PITCH TO FIXTURES
DOMESTIC WATER:	NO SPECIFIC PITCH, PITCH TO FIXTURES

PLUMBING SHEET INDEX

P0.0	PLUMBING COVERSHEET
PD1.1	LEVEL 01 DEMOLITION PLAN - PLUMBING
P0.1	UNDERFLOOR PLAN - AREA A - PLUMBING
P0.2	UNDERFLOOR PLAN - AREA B - PLUMBING
P1.1	LEVEL 01 PLAN - AREA A - PLUMBING
P1.2	LEVEL 01 PLAN - AREA B - PLUMBING
P1.3	LEVEL 02 PLAN - AREA A - PLUMBING
P1.4	LEVEL 02 PLAN - AREA B - PLUMBING
P3.0	ENLARGED PLAN - PLUMBING
P3.1	ENLARGED PLAN - PLUMBING
P4.1	PLUMBING DETAILS
P4.2	PLUMBING DETAILS
P5.1	PLUMBING DIAGRAMS
P6.1	PLUMBING SCHEDULES
P6.2	PLUMBING SCHEDULES
GRAND TOTAL: 15	

Farnsworth GROUP

14225 UNIVERSITY AVENUE, SUITE 110
WALUKEE, IOWA 50263
(515) 225-3469 / info@f-w.com

www.f-w.com
Engineers | Architects | Surveyors | Scientists

RIPPE ASSOCIATES

FOODSERVICE DESIGN + CONSULTING

kpff

IMEG

Bishop Engineering

ISSUE	#	DATE:	DESCRIPTION:
-------	---	-------	--------------

BID SET

PROJECT:
STATE OF IOWA - DEPARTMENT OF CORRECTIONS

CLARINDA CORRECTIONAL FACILITY - KITCHEN & LAUNDRY ADDITION

2000 N 16TH ST, CLARINDA, IA 51632

DATE: 02/09/2024
DESIGNED: MIKMCC
DRAWN: MIKMCC
REVIEWED: DELLLE

SHEET TITLE:
PLUMBING COVERSHEET

SHEET NUMBER:

P0.0

PROJECT NO.: 0240202.00
RFB922300-02


IMEG

www.imegcorp.com

IMEG CORP. RESERVES PROPRIETARY RIGHTS, INCLUDING COPYRIGHTS. TO THIS DRAWING AND THE DATA SHOWN THEREIN. SAID DRAWING AND/OR DATA ARE THE EXCLUSIVE PROPERTY OF IMEG CORP. AND SHALL NOT BE USED OR REPRODUCED FOR ANY OTHER PROJECT WITHOUT THE EXPRESS WRITTEN APPROVAL AND PARTICIPATION OF IMEG CORP. ©2024 IMEG CORP.

0 1 2 3

REF. SCALE IN INCHES PROJECT #21007888.00

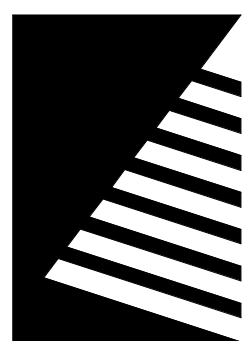

Farnsworth
GROUP

14225 UNIVERSITY AVENUE, SUITE 110
WALKEE, IOWA 50263
(515) 225-3469 / info@f-w.com

www.f-w.com
Engineers | Architects | Surveyors | Scientists

RIPPE ASSOCIATES
FOODSERVICE DESIGN + CONSULTING

kpff

IMEG

Bishop Engineering

ISSUE:
DATE: DESCRIPTION:

BID SET

PROJECT:
STATE OF IOWA - DEPARTMENT
OF CORRECTIONS

CLARINDA
CORRECTIONAL
FACILITY - KITCHEN &
LAUNDRY ADDITION

2000 N 16TH ST, CLARINDA, IA
51632

DATE: 02/09/2024

DESIGNED: MIKMCC

DRAWN: MIKMCC


REVIEWED: DELLE

SHEET TITLE:
LEVEL 01
DEMOLITION PLAN -
PLUMBING


SHEET NUMBER:

PD1.1


PROJECT NO.: 0240202.00
RFB922300-02

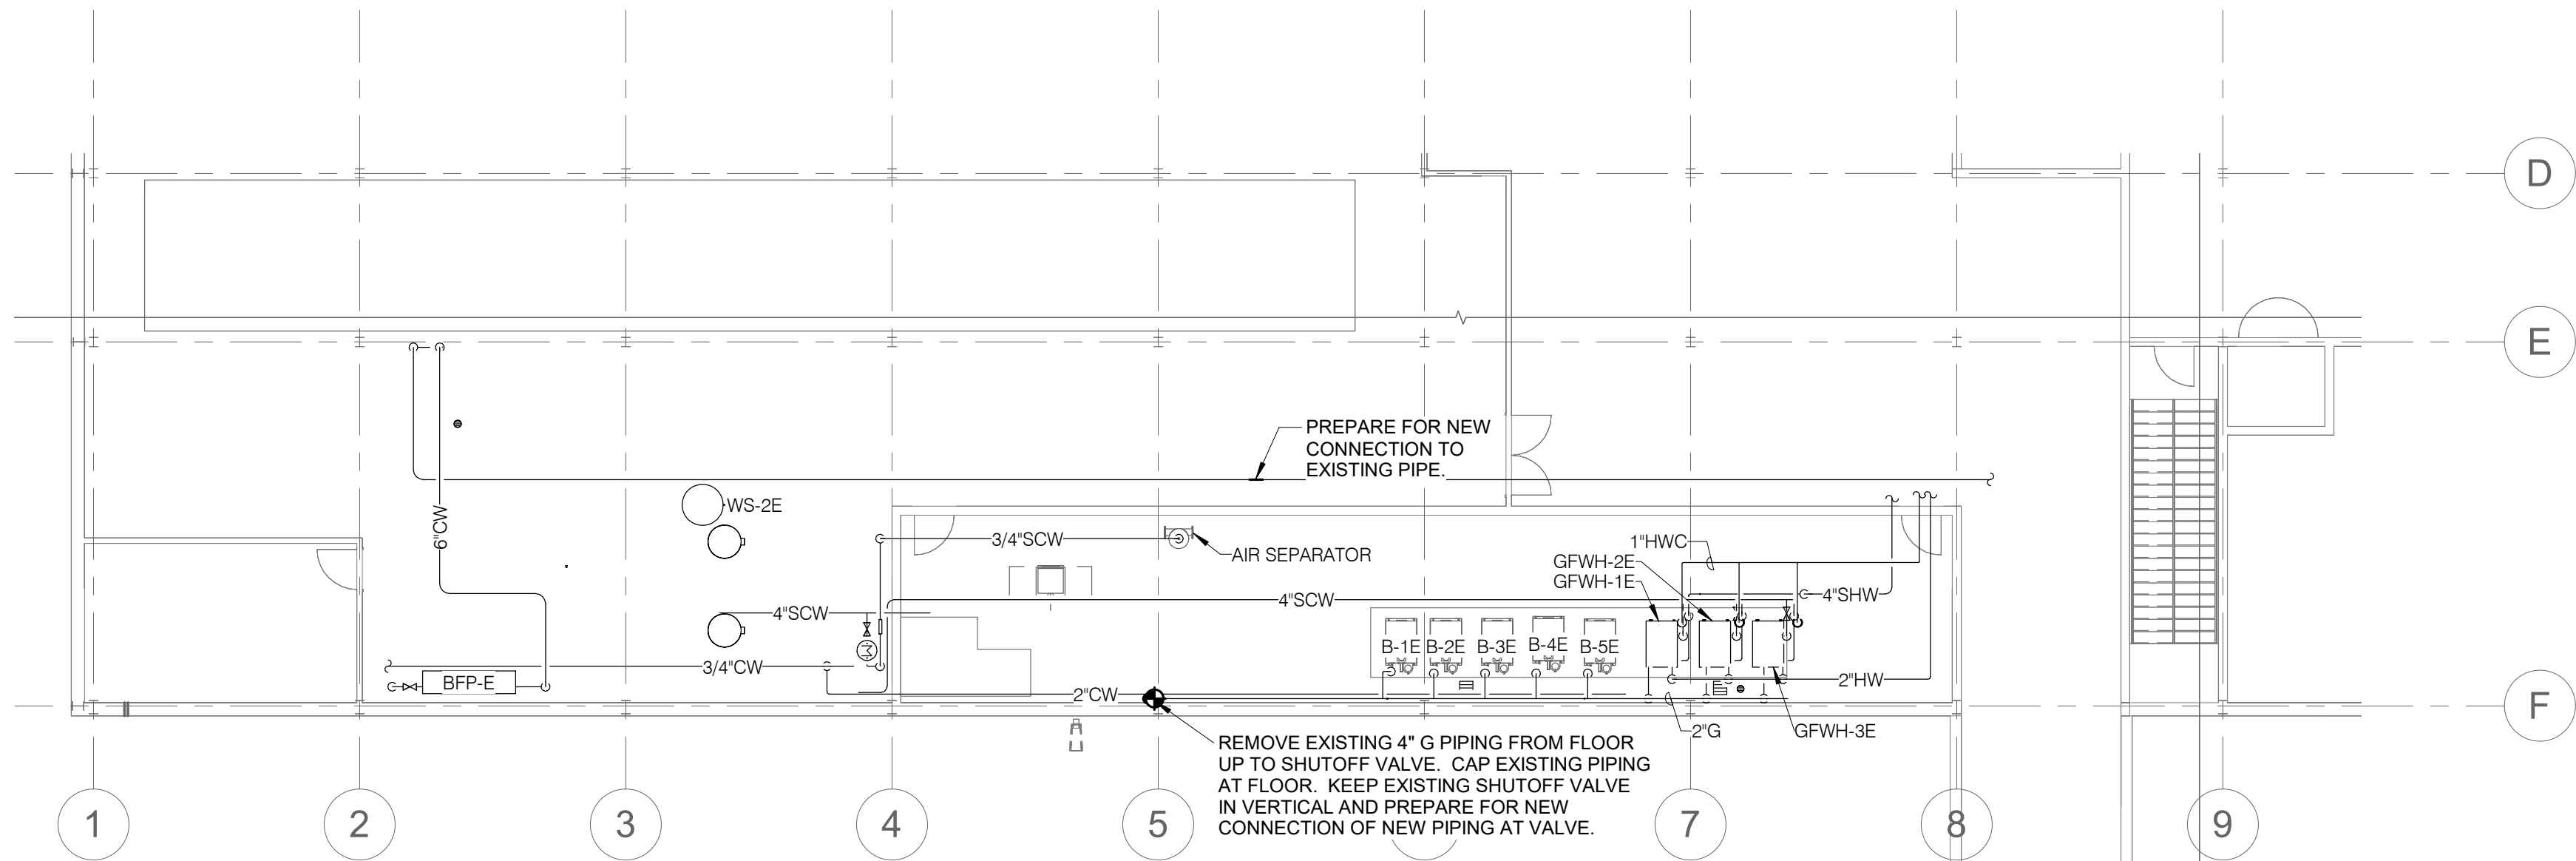

1 LEVEL 02 DEMOLITION PLAN - PLUMBING
3/32\"/>

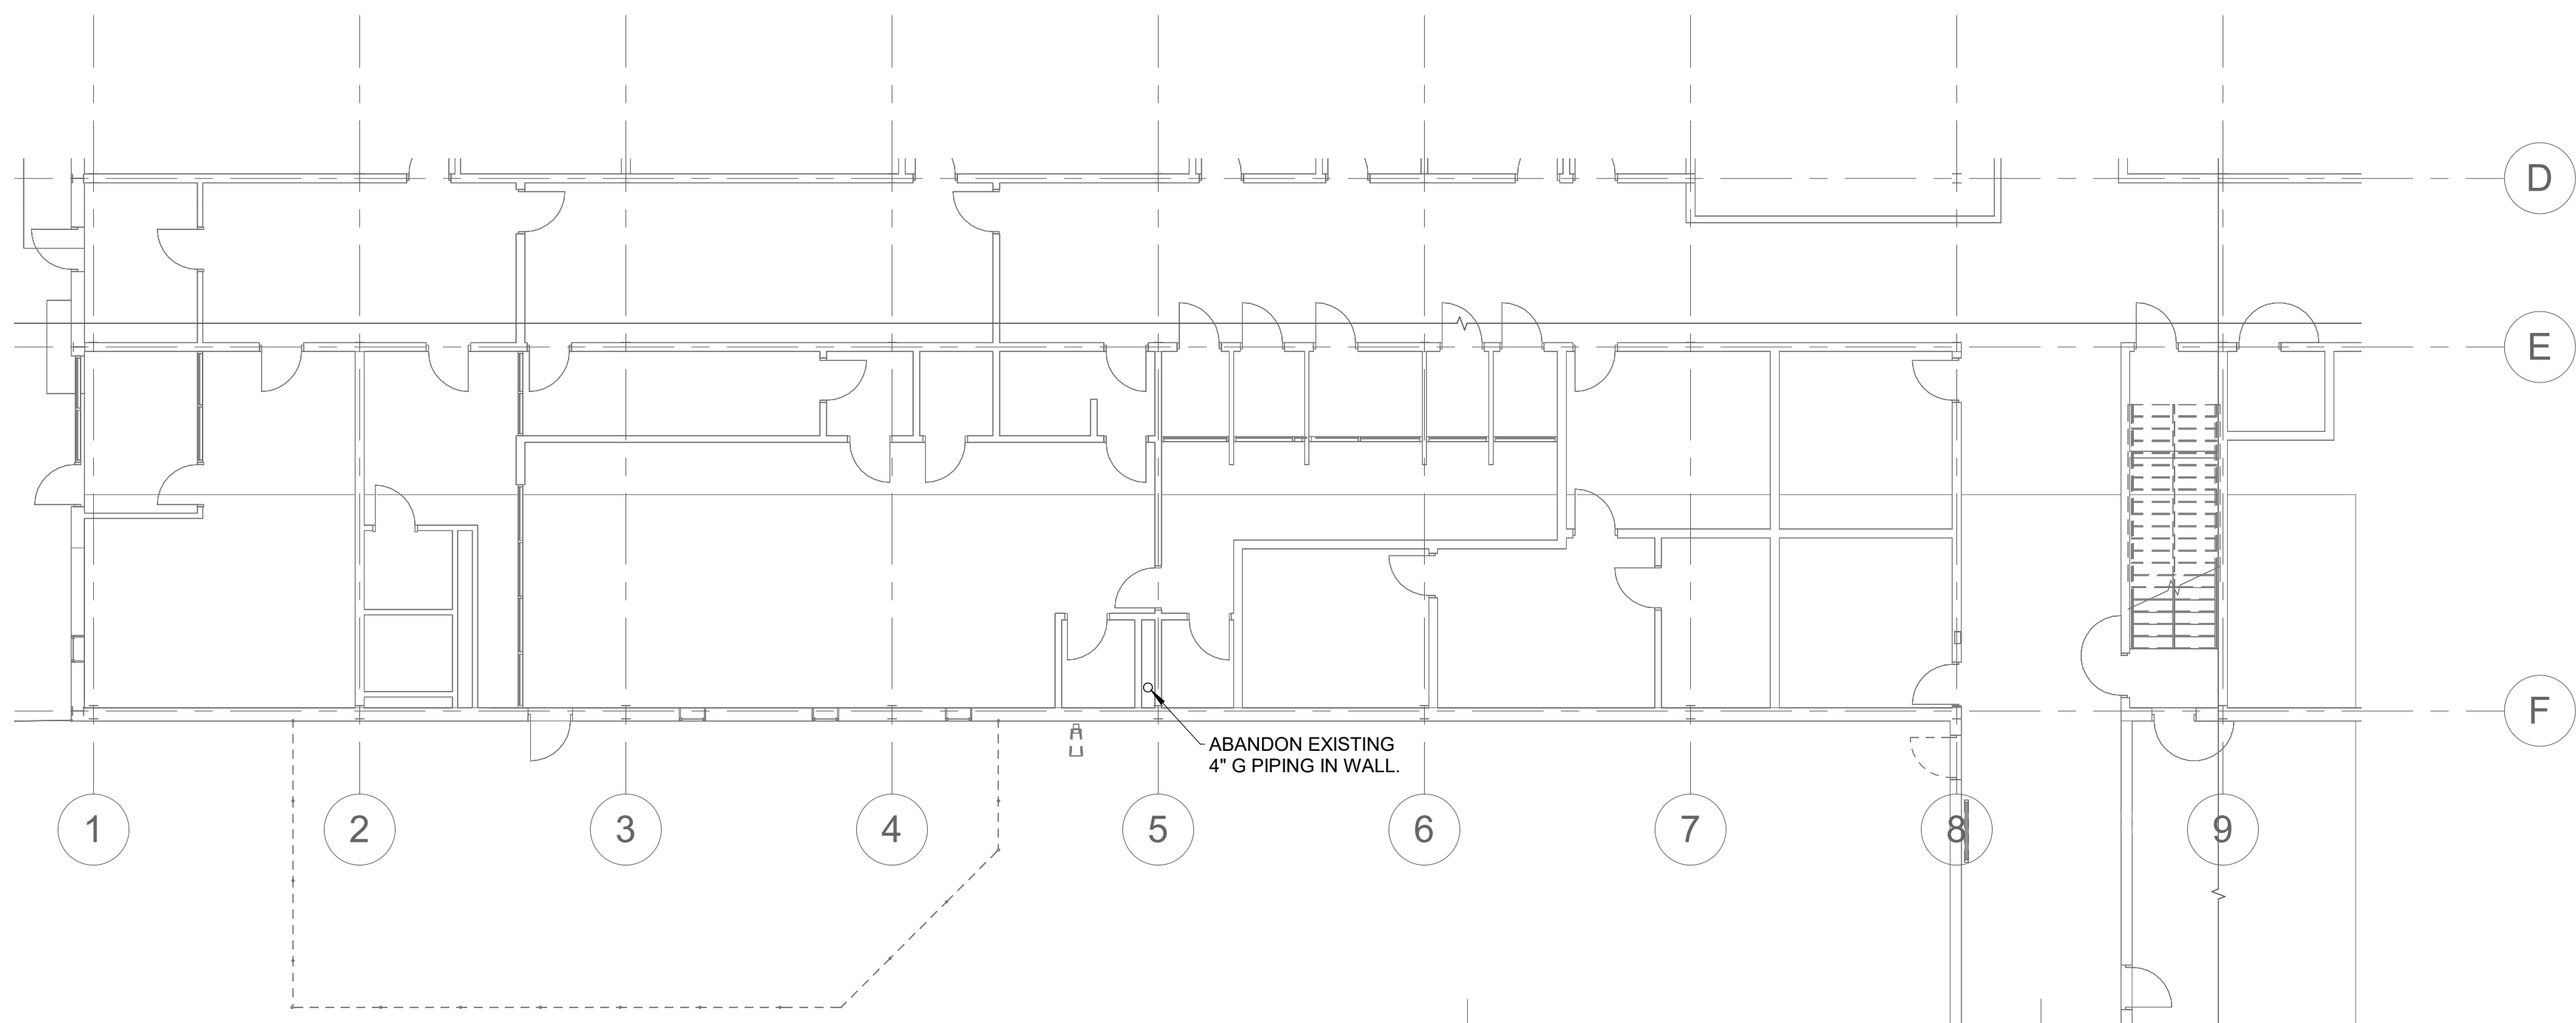

2 LEVEL 01 DEMOLITION PLAN - PLUMBING
3/32\"/>

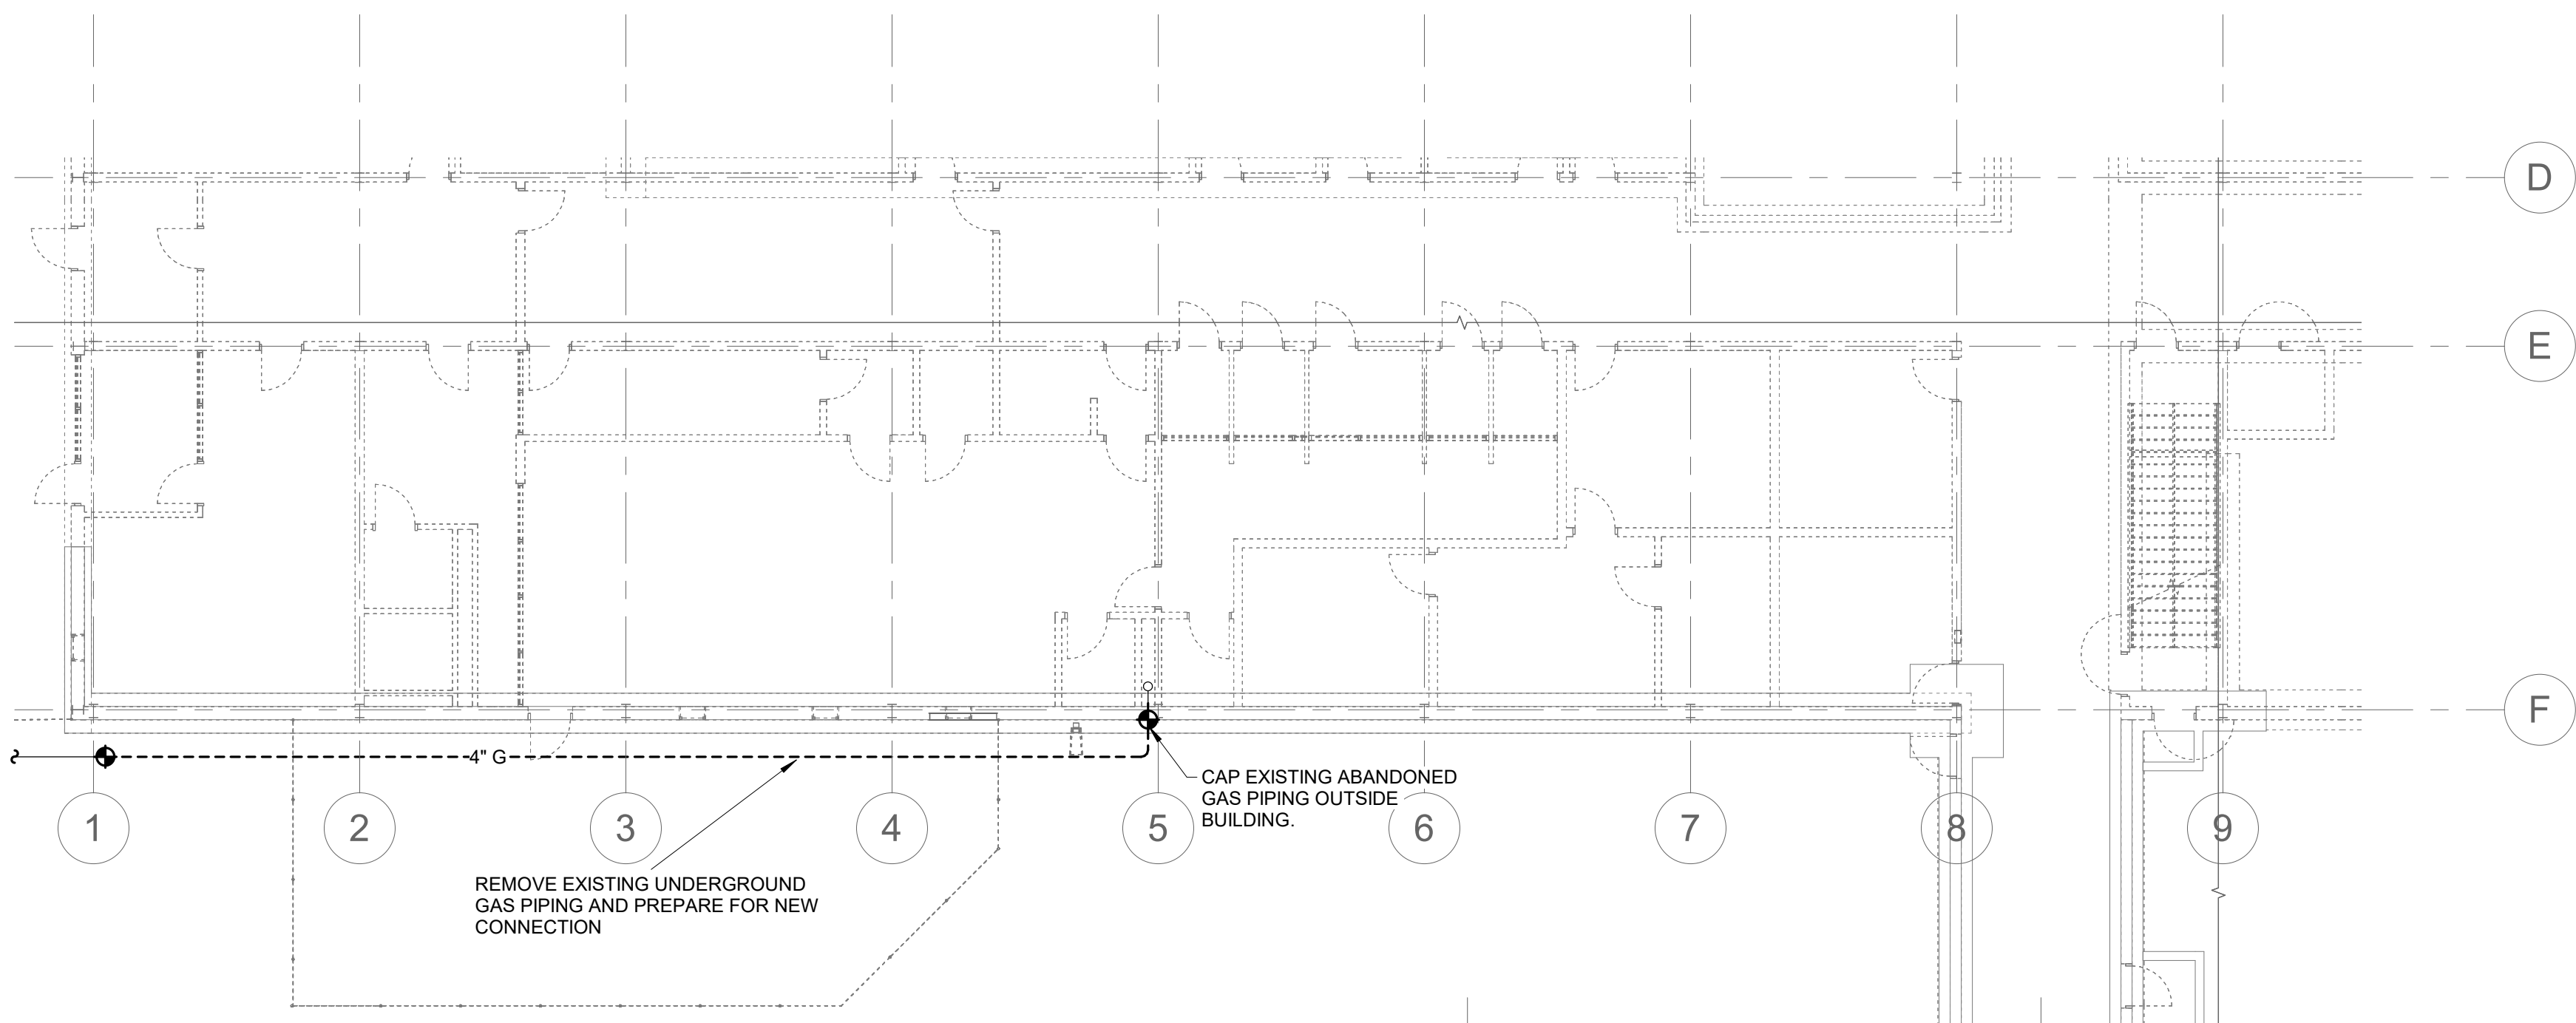


3 LEVEL 01 - UNDERFLOOR DEMOLITION PLAN - PLUMBING
3/32\"/>

IMEG
2882 10TH STREET
DES MOINES, IA 50322
P: 515.334.9000 F: 515.334.9008
www.imegcorp.com

IMEG CORP. RESERVES PROPRIETARY RIGHTS, INCLUDING COPYRIGHTS, TO THIS DRAWING AND THE DATA SHOWN THEREIN. SAID DRAWING AND/OR DATA ARE THE EXCLUSIVE PROPERTY OF IMEG CORP. AND SHALL NOT BE USED OR REPRODUCED FOR ANY OTHER PROJECT WITHOUT THE EXPRESS WRITTEN APPROVAL AND PARTICIPATION OF IMEG CORP. ©2024 IMEG CORP.

REF. SCALE IN INCHES: 0 1 2 3
PROJECT #21007888.00

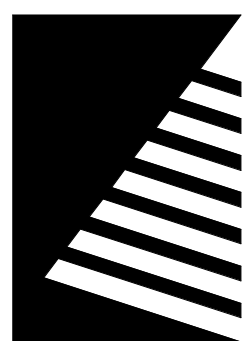

Farnsworth
GROUP

14225 UNIVERSITY AVENUE, SUITE 110
WALKEE, IOWA 50263
(515) 225-3469 / info@f-w.com

www.f-w.com
Engineers | Architects | Surveyors | Scientists

RIPPE ASSOCIATES
FOODSERVICE DESIGN + CONSULTING

kpff

IMEG

Bishop Engineering

ISSUE:
DATE: DESCRIPTION:

BID SET

PROJECT:
STATE OF IOWA - DEPARTMENT
OF CORRECTIONS

CLARINDA
CORRECTIONAL
FACILITY - KITCHEN &
LAUNDRY ADDITION

2000 N 16TH ST, CLARINDA, IA
51632

DATE: 02/09/2024

DESIGNED: MIKMCC

DRAWN: MIKMCC

REVIEWED: DELLE

SHEET TITLE:

UNDERFLOOR PLAN -
AREA A - PLUMBING

SHEET NUMBER:

P0.1

PROJECT NO.: 0240202.00

RFB922300-02

KEYNOTES: (B)

1. PROVIDE 45 DEGREE CONNECTION TO SANITARY FOR VENTING. RISE VERTICALLY A MINIMUM OF 6" ABOVE FLOOD RM BEFORE OFFSETTING HORIZONTALLY.
2. CIRCUIT VENT SHALL SERVE (2) FLOOR DRAINS. COORDINATE LOCATION OF VENT RISE WITH OPENING IN WALLS FOR DRYERS.



www.imegcorp.com
IMEG CORP. RESERVES PROPRIETARY RIGHTS, INCLUDING COPYRIGHTS, TO THIS DRAWING AND THE DATA SHOWN THEREON. SAID DRAWING AND/OR DATA ARE THE EXCLUSIVE PROPERTY OF IMEG CORP. AND SHALL NOT BE USED OR REPRODUCED FOR ANY OTHER PROJECT WITHOUT THE EXPRESS WRITTEN APPROVAL AND PARTICIPATION OF IMEG CORP. ©2024 IMEG CORP.

0 1 2 3
REF. SCALE IN INCHES PROJECT #21007888.00




1

UNDERFLOOR PLAN - AREA A - PLUMBING

1/8" = 1'-0"

2/20/2024 3:01:13 PM

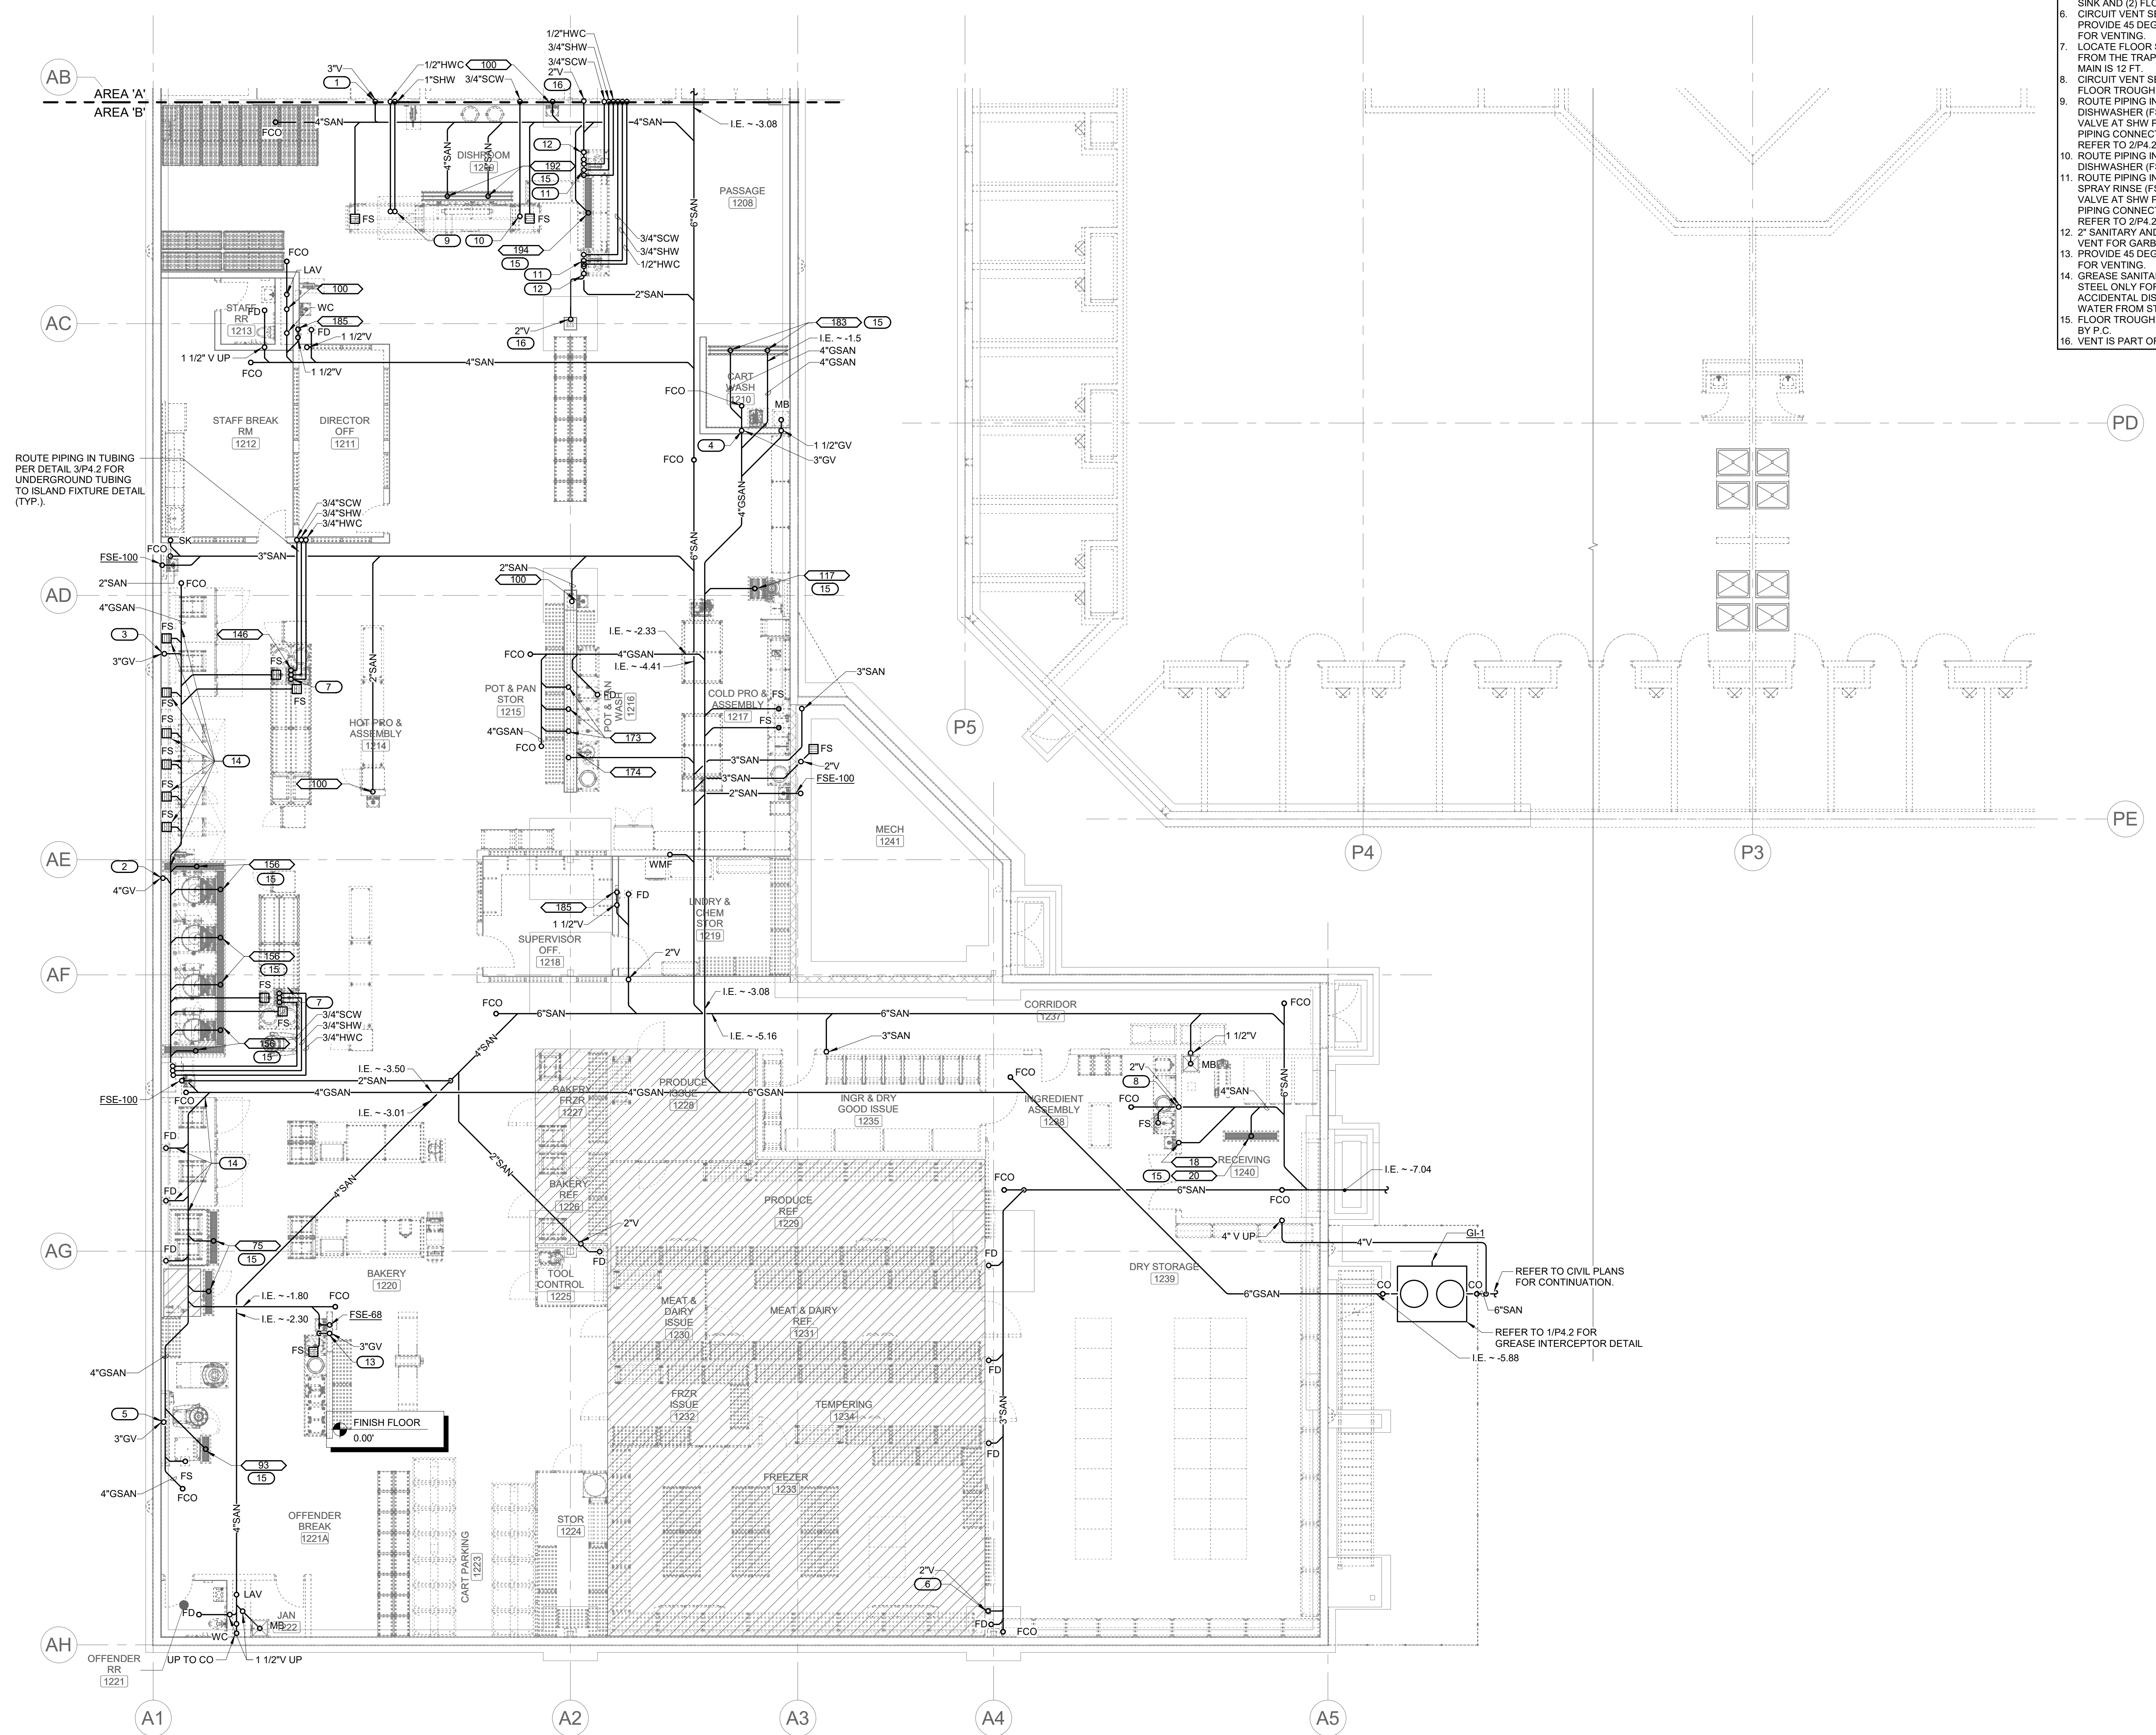

- KEYNOTES:**
1. CIRCUIT VENT SERVING (2) FLOOR SINKS, (2) 192 FLOOR TROUGHS AND (1) 194 FLOOR TROUGH. PROVIDE 45 DEGREE CONNECTION TO SANITARY FOR VENTING.
 2. CIRCUIT VENT SERVING (6) 156 FLOOR TROUGHS AND (2) FLOOR SINK.
 3. CIRCUIT VENT SERVING (8) FLOOR SINKS.
 4. CIRCUIT VENT SERVING (2) 183 FLOOR TROUGHS, (1) 117 FLOOR TROUGH AND (2) FLOOR SINKS.
 5. 3" CIRCUIT VENT SERVING (1) FSE-83 FLOOR TROUGH, (2) FSE-75 FLOOR TROUGHS, (1) FLOOR SINK AND (2) FLOOR DRAINS.
 6. CIRCUIT VENT SERVING (4) FLOOR DRAINS. PROVIDE 45 DEGREE CONNECTION TO SANITARY FOR VENTING.
 7. LOCATE FLOOR SINK SO THE MAXIMUM DISTANCE FROM THE TRAP ARM TO THE CIRCUIT VENTED MAIN IS 12 FT.
 8. CIRCUIT VENT SERVING (1) FLOOR SINK AND (1) FLOOR TROUGH.
 9. ROUTE PIPING IN UNDERGROUND TUBING UP TO DISHWASHER (FSE-189). PROVIDE SHUTOFF VALVE AT SHW PIPE ABOVE FLOOR WITH HWC PIPING CONNECTED PRIOR TO SHUTOFF VALVE. REFER TO 2/P4.2.
 10. ROUTE PIPING IN UNDERGROUND TUBING UP TO DISHWASHER (FSE-189). REFER TO 2/P4.2.
 11. ROUTE PIPING IN UNDERGROUND TUBING UP TO SPRAY RINSE (FSE-191). PROVIDE SHUTOFF VALVE AT SHW PIPE ABOVE FLOOR WITH HWC PIPING CONNECTED PRIOR TO SHUTOFF VALVE. REFER TO 2/P4.2.
 12. 2" SANITARY AND 2" VENT PIPING FROM ISLAND VENT FOR GARBAGE DISPOSAL (FSE-187).
 13. PROVIDE 45 DEGREE CONNECTION TO SANITARY FOR VENTING.
 14. GREASE SANITARY PIPING SHALL BE STAINLESS STEEL ONLY FOR THIS SECTION IN CASE OF ACCIDENTAL DISCHARGE OF EXCESSIVELY HOT WATER FROM STEAMERS AND RACK OVENS.
 15. FLOOR TROUGH PROVIDED BY FSEC, INSTALLED BY P.C.
 16. VENT IS PART OF ISLAND VENTING FOR FSE-187.

1 UNDERFLOOR PLAN - AREA B - PLUMBING
1/8" = 1'-0"

IMEG
www.imegcorp.com
IMEG CORP. RESERVES PROPRIETARY RIGHTS, INCLUDING COPYRIGHTS, TO THIS DRAWING AND THE DATA SHOWN THEREIN. SAID DRAWING AND/OR DATA ARE THE EXCLUSIVE PROPERTY OF IMEG CORP. AND SHALL NOT BE USED OR REPRODUCED FOR ANY OTHER PROJECT WITHOUT THE EXPRESS WRITTEN APPROVAL AND PARTICIPATION OF IMEG CORP. ©2024 IMEG CORP.

2882 10TH STREET
DES MOINES, IA 50322
P: 515.334.9008 F: 515.334.9008

0 1 2 3
REF. SCALE IN INCHES PROJECT #21007888.00

Farnsworth GROUP
14225 UNIVERSITY AVENUE, SUITE 110
WALKEE, IOWA 50263
(515) 225-3469 / info@f-w.com
www.f-w.com
Engineers | Architects | Surveyors | Scientists

RIPPE ASSOCIATES
FOODSERVICE DESIGN + CONSULTING

kpff

IMEG

Bishop Engineering

ISSUE:	#	DATE:	DESCRIPTION:
--------	---	-------	--------------

BID SET

PROJECT:
STATE OF IOWA - DEPARTMENT OF CORRECTIONS

CLARINDA CORRECTIONAL FACILITY - KITCHEN & LAUNDRY ADDITION

2000 N 16TH ST, CLARINDA, IA 51632



DATE:	02/09/2024
DESIGNED:	MIKMCC
DRAWN:	MIKMCC
REVIEWED:	DELLE

SHEET TITLE:
UNDERFLOOR PLAN - AREA B - PLUMBING

SHEET NUMBER:
P0.2

PROJECT NO.: 0240202.00
RFB922300-02

- KEYNOTES:** C #
- CORE DRILL THROUGH EXISTING PRECAST EXTERIOR WALL. CORES SHALL BE COORDINATED WITH EXISTING VERTICAL CABLING IN WALL. REFER TO EXISTING WALL SCANNING DATA FOUND ON STRUCTURAL PLANS. COORDINATE NEW WALL OPENING WITH PRECAST SUPPLIER SO CORE DRILLING IS NOT REQUIRED. ALL OPENINGS SHALL BE COORDINATED PRIOR TO ORDERING PRECAST AND COORDINATED TO ALIGN WITH NEW CORES IN EXISTING PRECAST WALL. REFER TO 5/P4.2 FOR FIRE RATED BARRIER PENETRATION DETAIL (TYP.)
 - ROUTE WATER PIPING EXPOSED ALONG WALL WITHIN CAGED AREA BEHIND WASHERS. PROVIDE SHUTOFF VALVES AT 60" AFF AND CAP FOR BASE BID. INCLUDE PIPING DOWNSTREAM OF SHUTOFF VALVE AND CONNECT PIPING TO WASHER FOR LAUNDRY ADD ALTERNATE. REFER TO DETAIL 3/P4.2.
 - PROVIDE 1/2" CA DROP WITH SHUTOFF AND 1/4" QUICK CONNECT/POINT OF USE COUPLING. PROVIDE FLEXIBLE HOSE AND CONNECT TO DRYER. DRYER PROVIDED WITH 1/4" COMPRESSED AIR QUICK CONNECTION BASED ON BASIS OF DESIGN (MILNOR M122). CONFIRM FINAL REQUIREMENTS WITH DRYER PROVIDED.
 - BASE BID FOR LAUNDRY AREA SHALL INCLUDE INSTALLING BRANCH PIPE WITH SHUTOFF VALVE AND CAP FOR GAS PIPING. ADD ALTERNATE FOR LAUNDRY SHALL INCLUDE ALL DOWNSTREAM GAS PIPING, REGULATORS AND FINAL CONNECTIONS TO DRYERS.
 - BASE BID FOR LAUNDRY AREA SHALL INCLUDE INSTALLING PIPING FROM THE AIR COMPRESSOR TO THE DRYER CHASE AND CAPPING THE PIPE. ADD ALTERNATE SHALL INCLUDE PIPING FROM CAP TO ALL DRYERS.
 - PROVIDE EXPANSION JOINT EJ-5 PER 22 0516 FOR ANY SHW AND HWC CPVC OR PEX PIPING INSTALLED (TYP.2). LOCATE ANCHORS AT EACH END AND PROVIDE ALIGNMENT GUIDES AS RECOMMENDED BY MANUFACTURER OF PIPING. APPROXIMATELY 3" OF EXPANSION ANTICIPATED.
 - PROVIDE EXPANSION JOINT EJ-5 PER 22 0516 FOR ANY SHW AND HWC CPVC OR PEX PIPING INSTALLED (TYP.2). LOCATE ANCHORS AT EACH END AND PROVIDE ALIGNMENT GUIDES AS RECOMMENDED BY MANUFACTURER OF PIPING. APPROXIMATELY 2" OF EXPANSION ANTICIPATED.

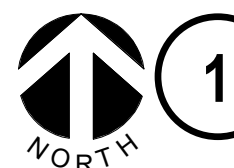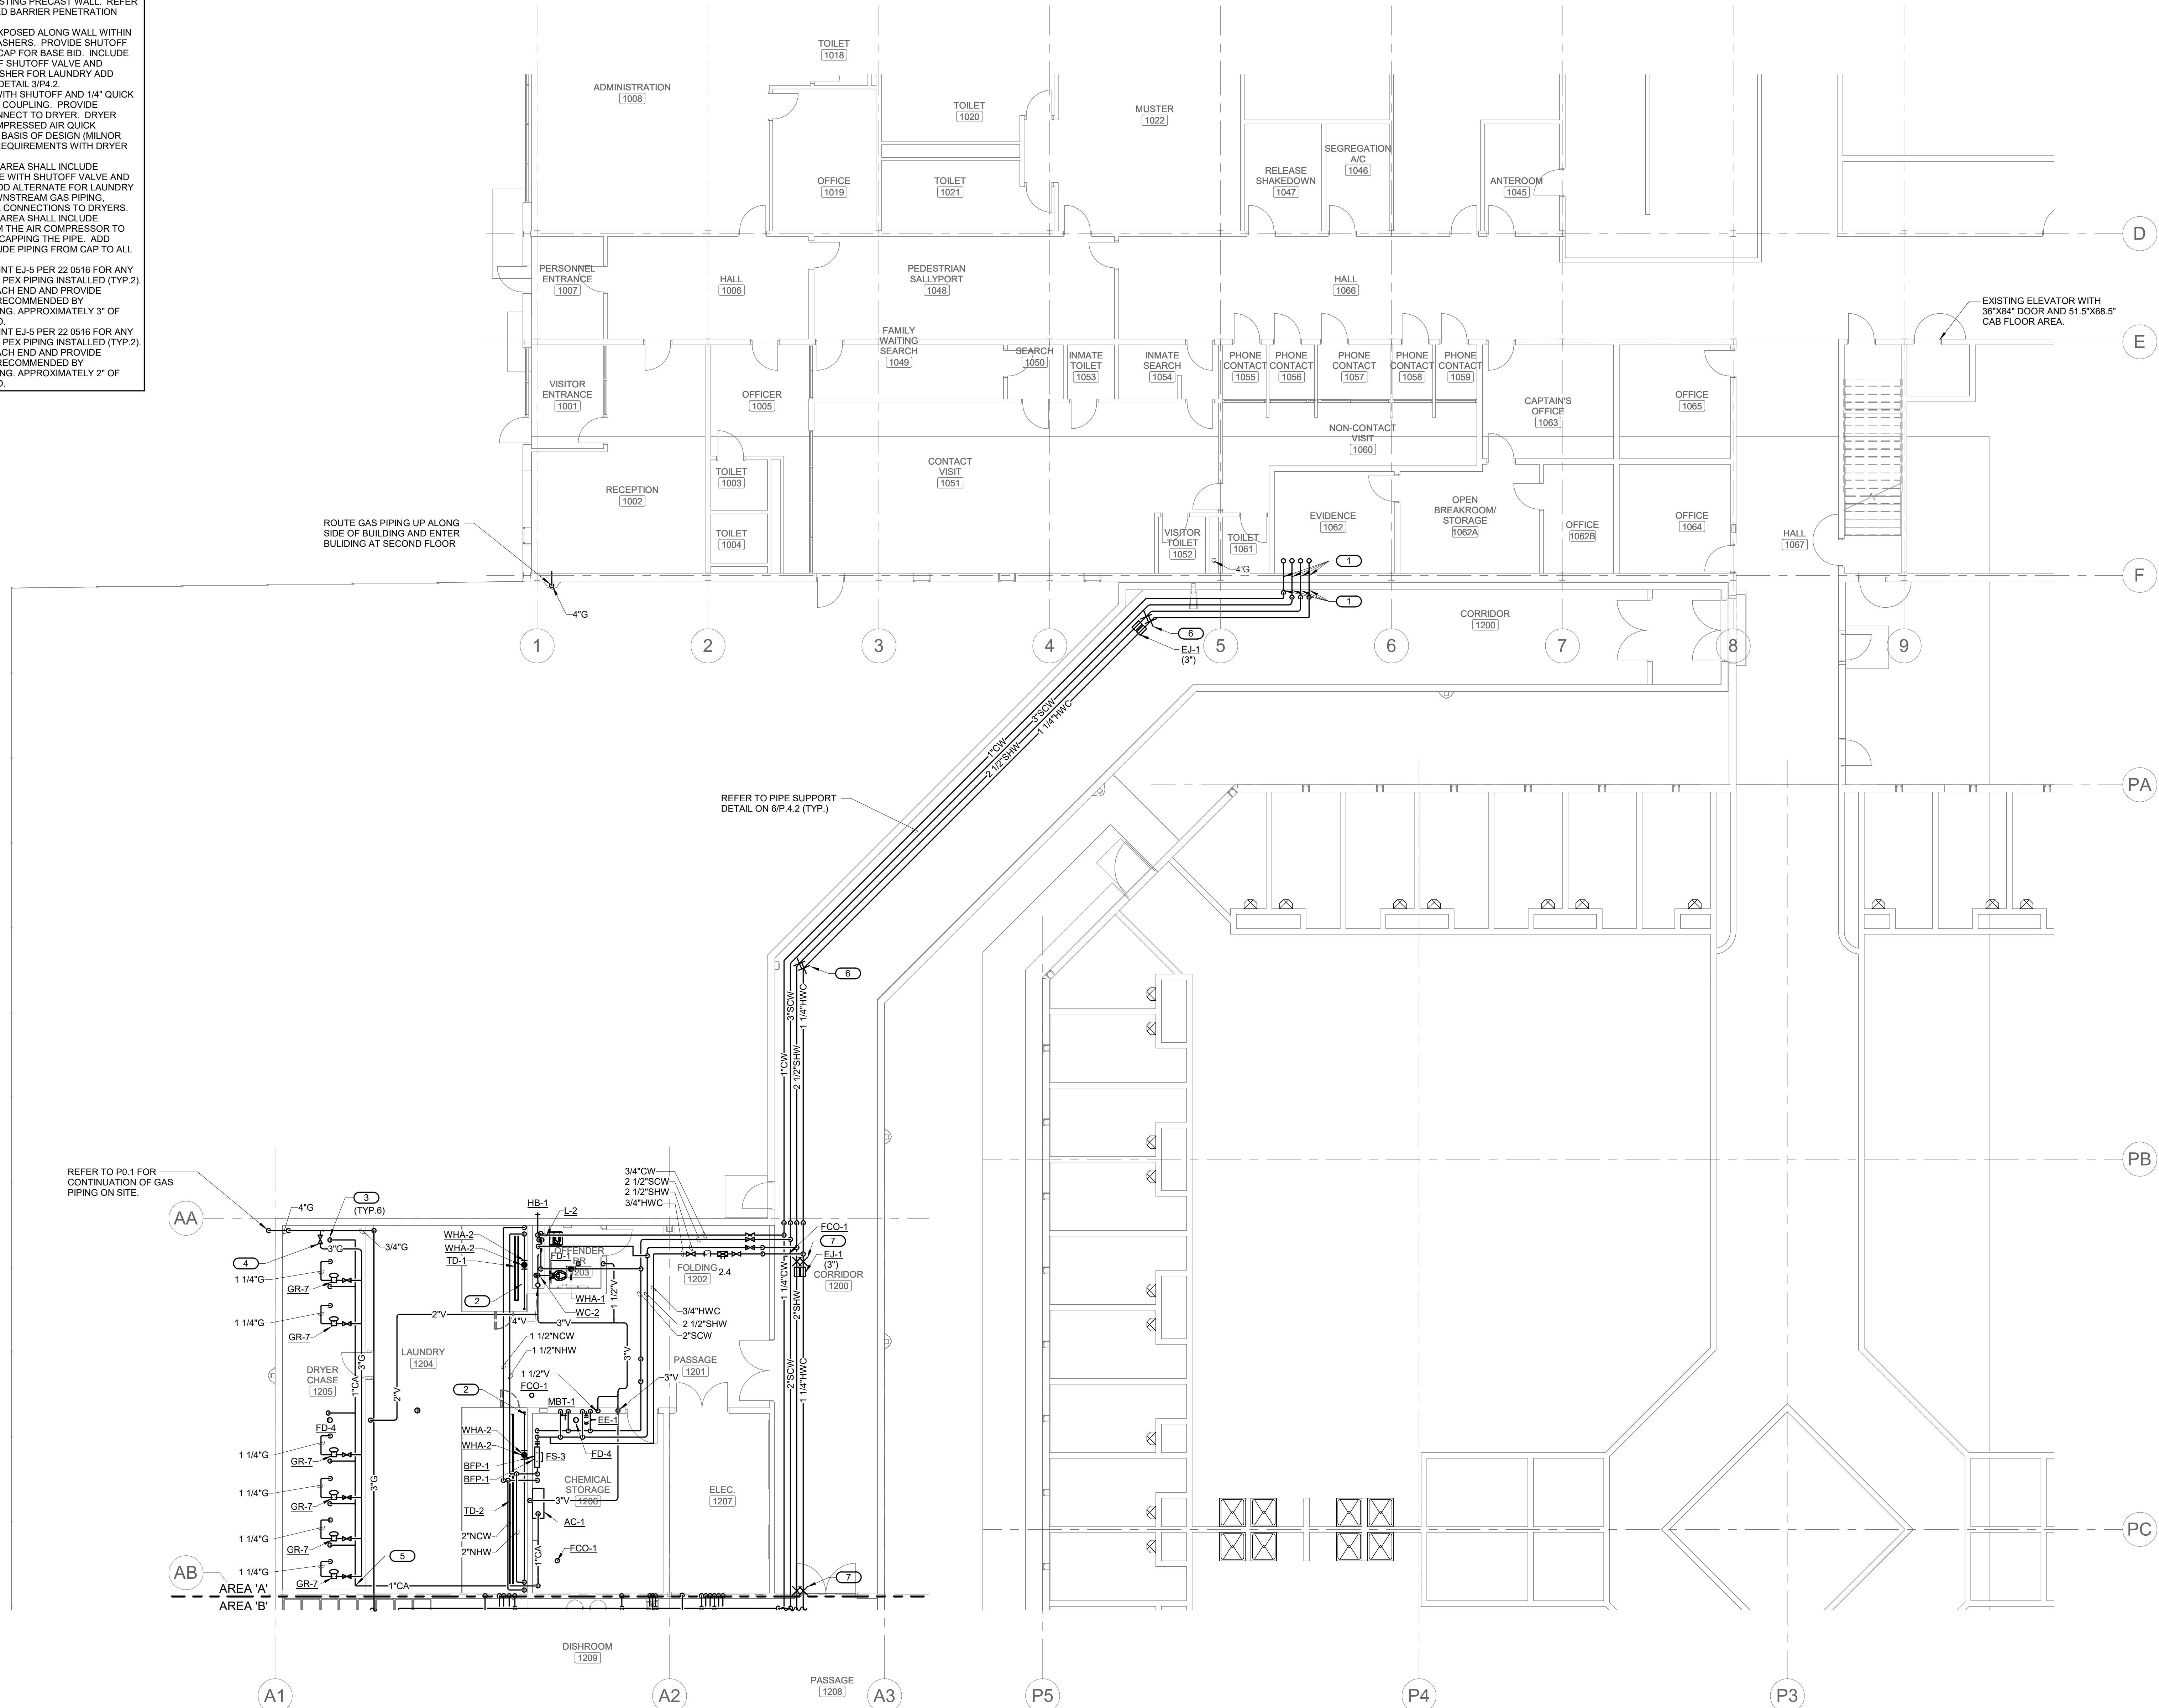


LEVEL 01 PLAN - AREA A - PLUMBING

1/8" = 1'-0"

IMEG
www.imegcorp.com
IMEG CORP. RESERVES PROPRIETARY RIGHTS, INCLUDING COPYRIGHTS, TO THIS DRAWING AND THE DATA SHOWN THEREIN. SAID DRAWING AND/OR DATA ARE THE EXCLUSIVE PROPERTY OF IMEG CORP. AND SHALL NOT BE USED OR REPRODUCED FOR ANY OTHER PROJECT WITHOUT THE EXPRESS WRITTEN APPROVAL AND PARTICIPATION OF IMEG CORP. ©2024 IMEG CORP.

2882 10TH STREET
DES MOINES, IA 50322
P: 515.334.9008 F: 515.334.9008

REF. SCALE IN INCHES PROJECT #21007888.00

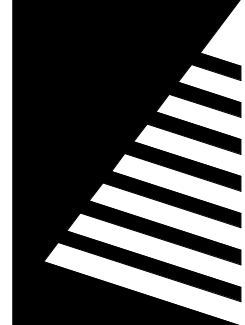

Farnsworth
GROUP

14225 UNIVERSITY AVENUE, SUITE 110
WAUKEE, IOWA 50263
(515) 225-3469 / info@f-w.com

www.f-w.com
Engineers | Architects | Surveyors | Scientists

RIPPE ASSOCIATES
FOODSERVICE DESIGN + CONSULTING

kpff

IMEG

Bishop Engineering

ISSUE:
DATE: DESCRIPTION:

BID SET

PROJECT:
STATE OF IOWA - DEPARTMENT
OF CORRECTIONS

**CLARINDA
CORRECTIONAL
FACILITY - KITCHEN &
LAUNDRY ADDITION**

2000 N 16TH ST, CLARINDA, IA
51632

DATE: 02/09/2024

DESIGNED: MIKMCC

DRAWN: MIKMCC

REVIEWED: DELLE


SHEET TITLE:

**LEVEL 01 PLAN -
AREA A - PLUMBING**

SHEET NUMBER:

P1.1

PROJECT NO.: 0240202.00
RFB922300-02

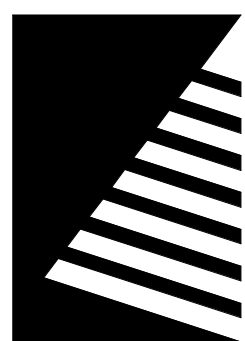

Farnsworth
GROUP

14225 UNIVERSITY AVENUE, SUITE 110
WAUKEE, IOWA 50263
(515) 225-3469 / info@f-w.com

www.f-w.com
Engineers | Architects | Surveyors | Scientists

RIPPE ASSOCIATES
FOODSERVICE DESIGN + CONSULTING

kpff

IMEG

Bishop Engineering

ISSUE:
DATE: DESCRIPTION:

BID SET

PROJECT:
STATE OF IOWA - DEPARTMENT
OF CORRECTIONS

CLARINDA
CORRECTIONAL
FACILITY - KITCHEN &
LAUNDRY ADDITION

2000 N 16TH ST, CLARINDA, IA
51632

DATE: 02/09/2024

DESIGNED: MIKMCC

DRAWN: MIKMCC

REVIEWED: DELLE

SHEET TITLE:

LEVEL 01 PLAN -
AREA B - PLUMBING

SHEET NUMBER:


P1.2

PROJECT NO.: 0240202.00

RFB922300-02

KEYNOTES: #

1. FLOOR DRAIN SHALL RECEIVE REFRIGERATION SYSTEM COIL CONDENSATE. ROUTING OF CONDENSATE PIPING TO FLOOR DRAIN SHALL BE BY FSEC.
2. PROVIDE ISLAND SINK VENT PER DETAIL 3/P4.1 FOR CONNECTION TO FSE-187.
3. PROVIDE SHUTOFF, BALANCE, CHECK AND SHUTOFF VALVES ON HWC PIPING. SET BALANCE VALVE TO 0.5 GPM.
4. P.C. SHALL COORDINATE FLOOR SINK LOCATION WITH DISHWASHER DRAIN DISCHARGE LOCATION. P.C. SHALL ROUTE INDIRECT WASTE FROM DISHWASHER TO FLOOR SINK.
5. FLOOR TROUGH PROVIDED BY FSEC, INSTALLED BY P.C. REFER TO DISPOSER DETAIL ON FSM101 FOR PIPING DETAIL AND SCOPE OF WORK BETWEEN FSEC AND P.C.
6. PROVIDE EXPANSION JOINT EJ-5 PER 22.0516 FOR ANY SHW AND HWC CPVC OR PEX PIPING INSTALLED (TYP.2). LOCATE ANCHORS AT EACH END AND PROVIDE ALIGNMENT GUIDES AS RECOMMENDED BY MANUFACTURER OF PIPING. APPROXIMATELY 3" OF EXPANSION ANTICIPATED.
7. PROVIDE EXPANSION JOINT EJ-5 PER 22.0516 FOR ANY SHW AND HWC CPVC OR PEX PIPING INSTALLED (TYP.2). LOCATE ANCHORS AT EACH END AND PROVIDE ALIGNMENT GUIDES AS RECOMMENDED BY MANUFACTURER OF PIPING. APPROXIMATELY 4" OF EXPANSION ANTICIPATED.

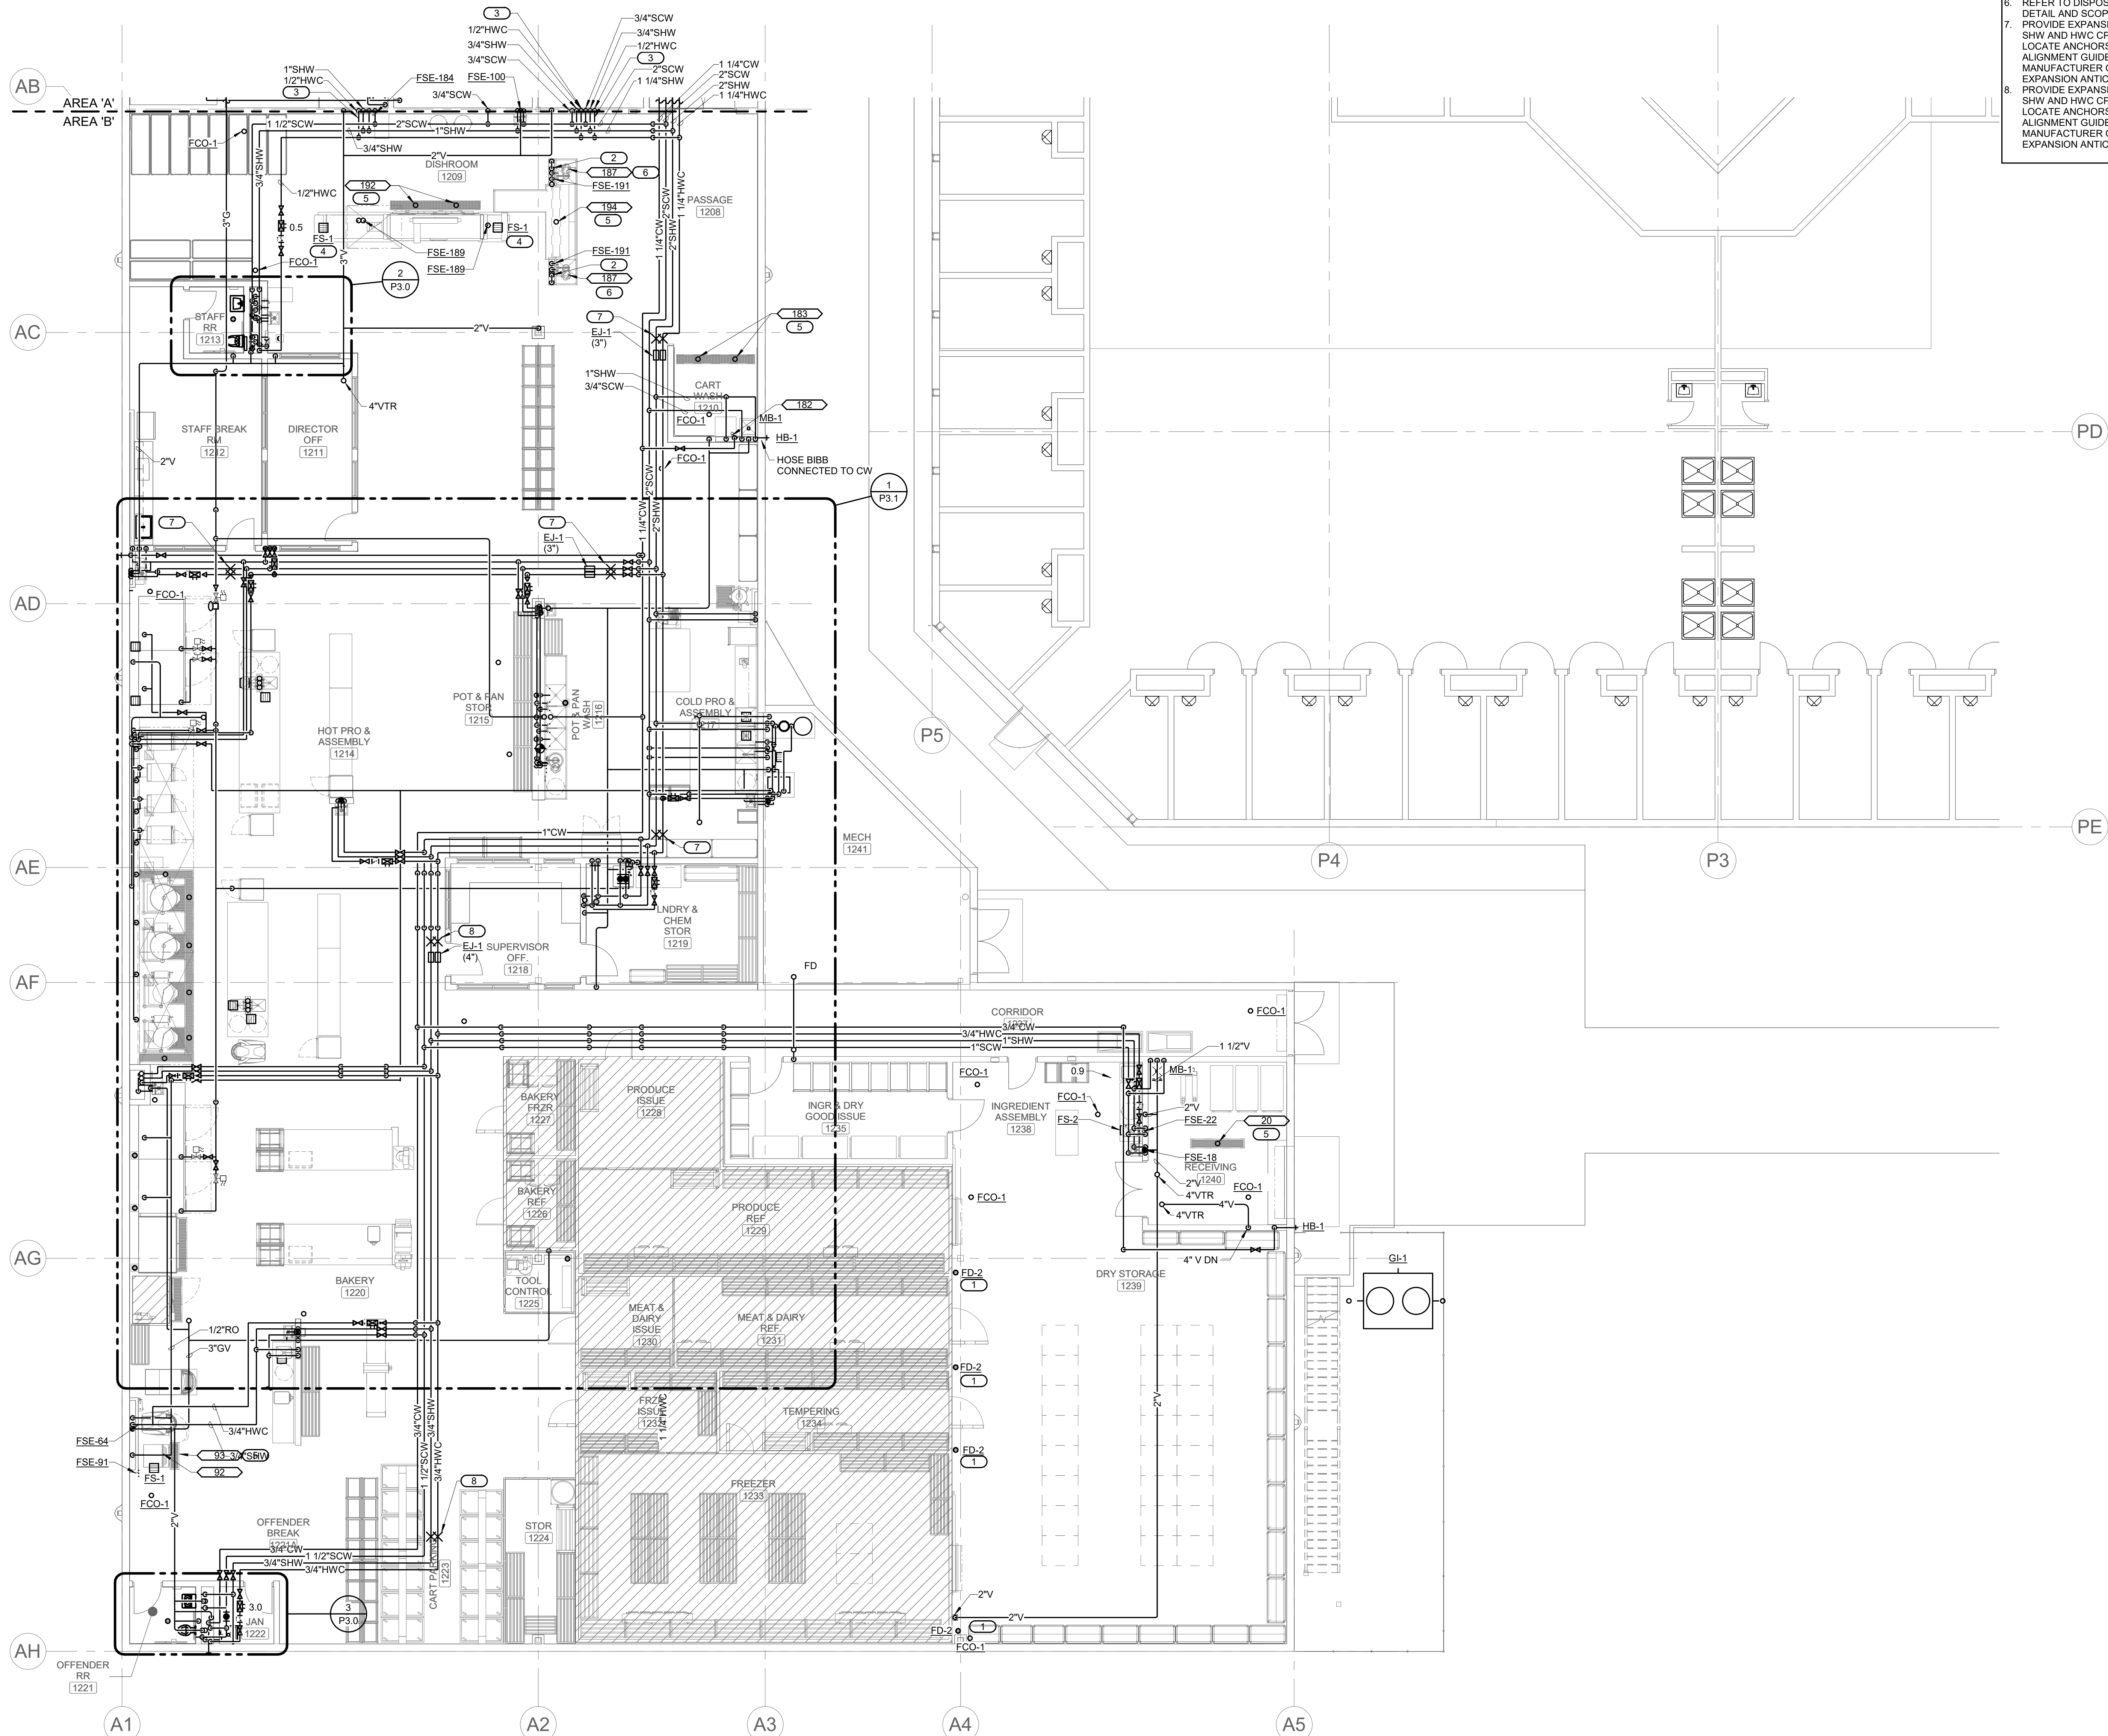


1 LEVEL 01 PLAN - AREA B - PLUMBING

1/8" = 1'-0"



IMEG GROUP
www.imegcorp.com
IMEG CORP. RESERVES PROPRIETARY RIGHTS, INCLUDING COPYRIGHTS, TO THIS DRAWING AND THE DATA SHOWN THEREIN. SAID DRAWING AND/OR DATA ARE THE EXCLUSIVE PROPERTY OF IMEG CORP. AND SHALL NOT BE USED OR REPRODUCED FOR ANY OTHER PROJECT WITHOUT THE EXPRESS WRITTEN APPROVAL AND PARTICIPATION OF IMEG CORP. ©2024 IMEG CORP.

REF. SCALE IN INCHES PROJECT #21007888.00

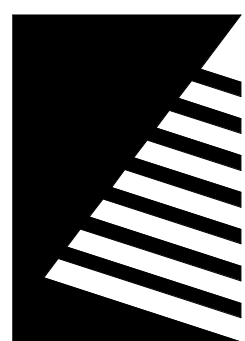

Farnsworth
GROUP

14225 UNIVERSITY AVENUE, SUITE 110
WALKEE, IOWA 50263
(515) 225-3469 / info@f-w.com

www.f-w.com
Engineers | Architects | Surveyors | Scientists

RIPPE ASSOCIATES
FOODSERVICE DESIGN + CONSULTING

kpff

IMEG

Bishop Engineering

ISSUE:
DATE: DESCRIPTION:

BID SET

PROJECT:
STATE OF IOWA - DEPARTMENT
OF CORRECTIONS

CLARINDA
CORRECTIONAL
FACILITY - KITCHEN &
LAUNDRY ADDITION

2000 N 16TH ST, CLARINDA, IA
51632

DATE: 02/09/2024

DESIGNED: MIKMCC

DRAWN: MIKMCC

REVIEWED: DELLLE


SHEET TITLE:

LEVEL 02 PLAN -
AREA A - PLUMBING

SHEET NUMBER:

P1.3

PROJECT NO.: 0240202.00
RFB922300-02

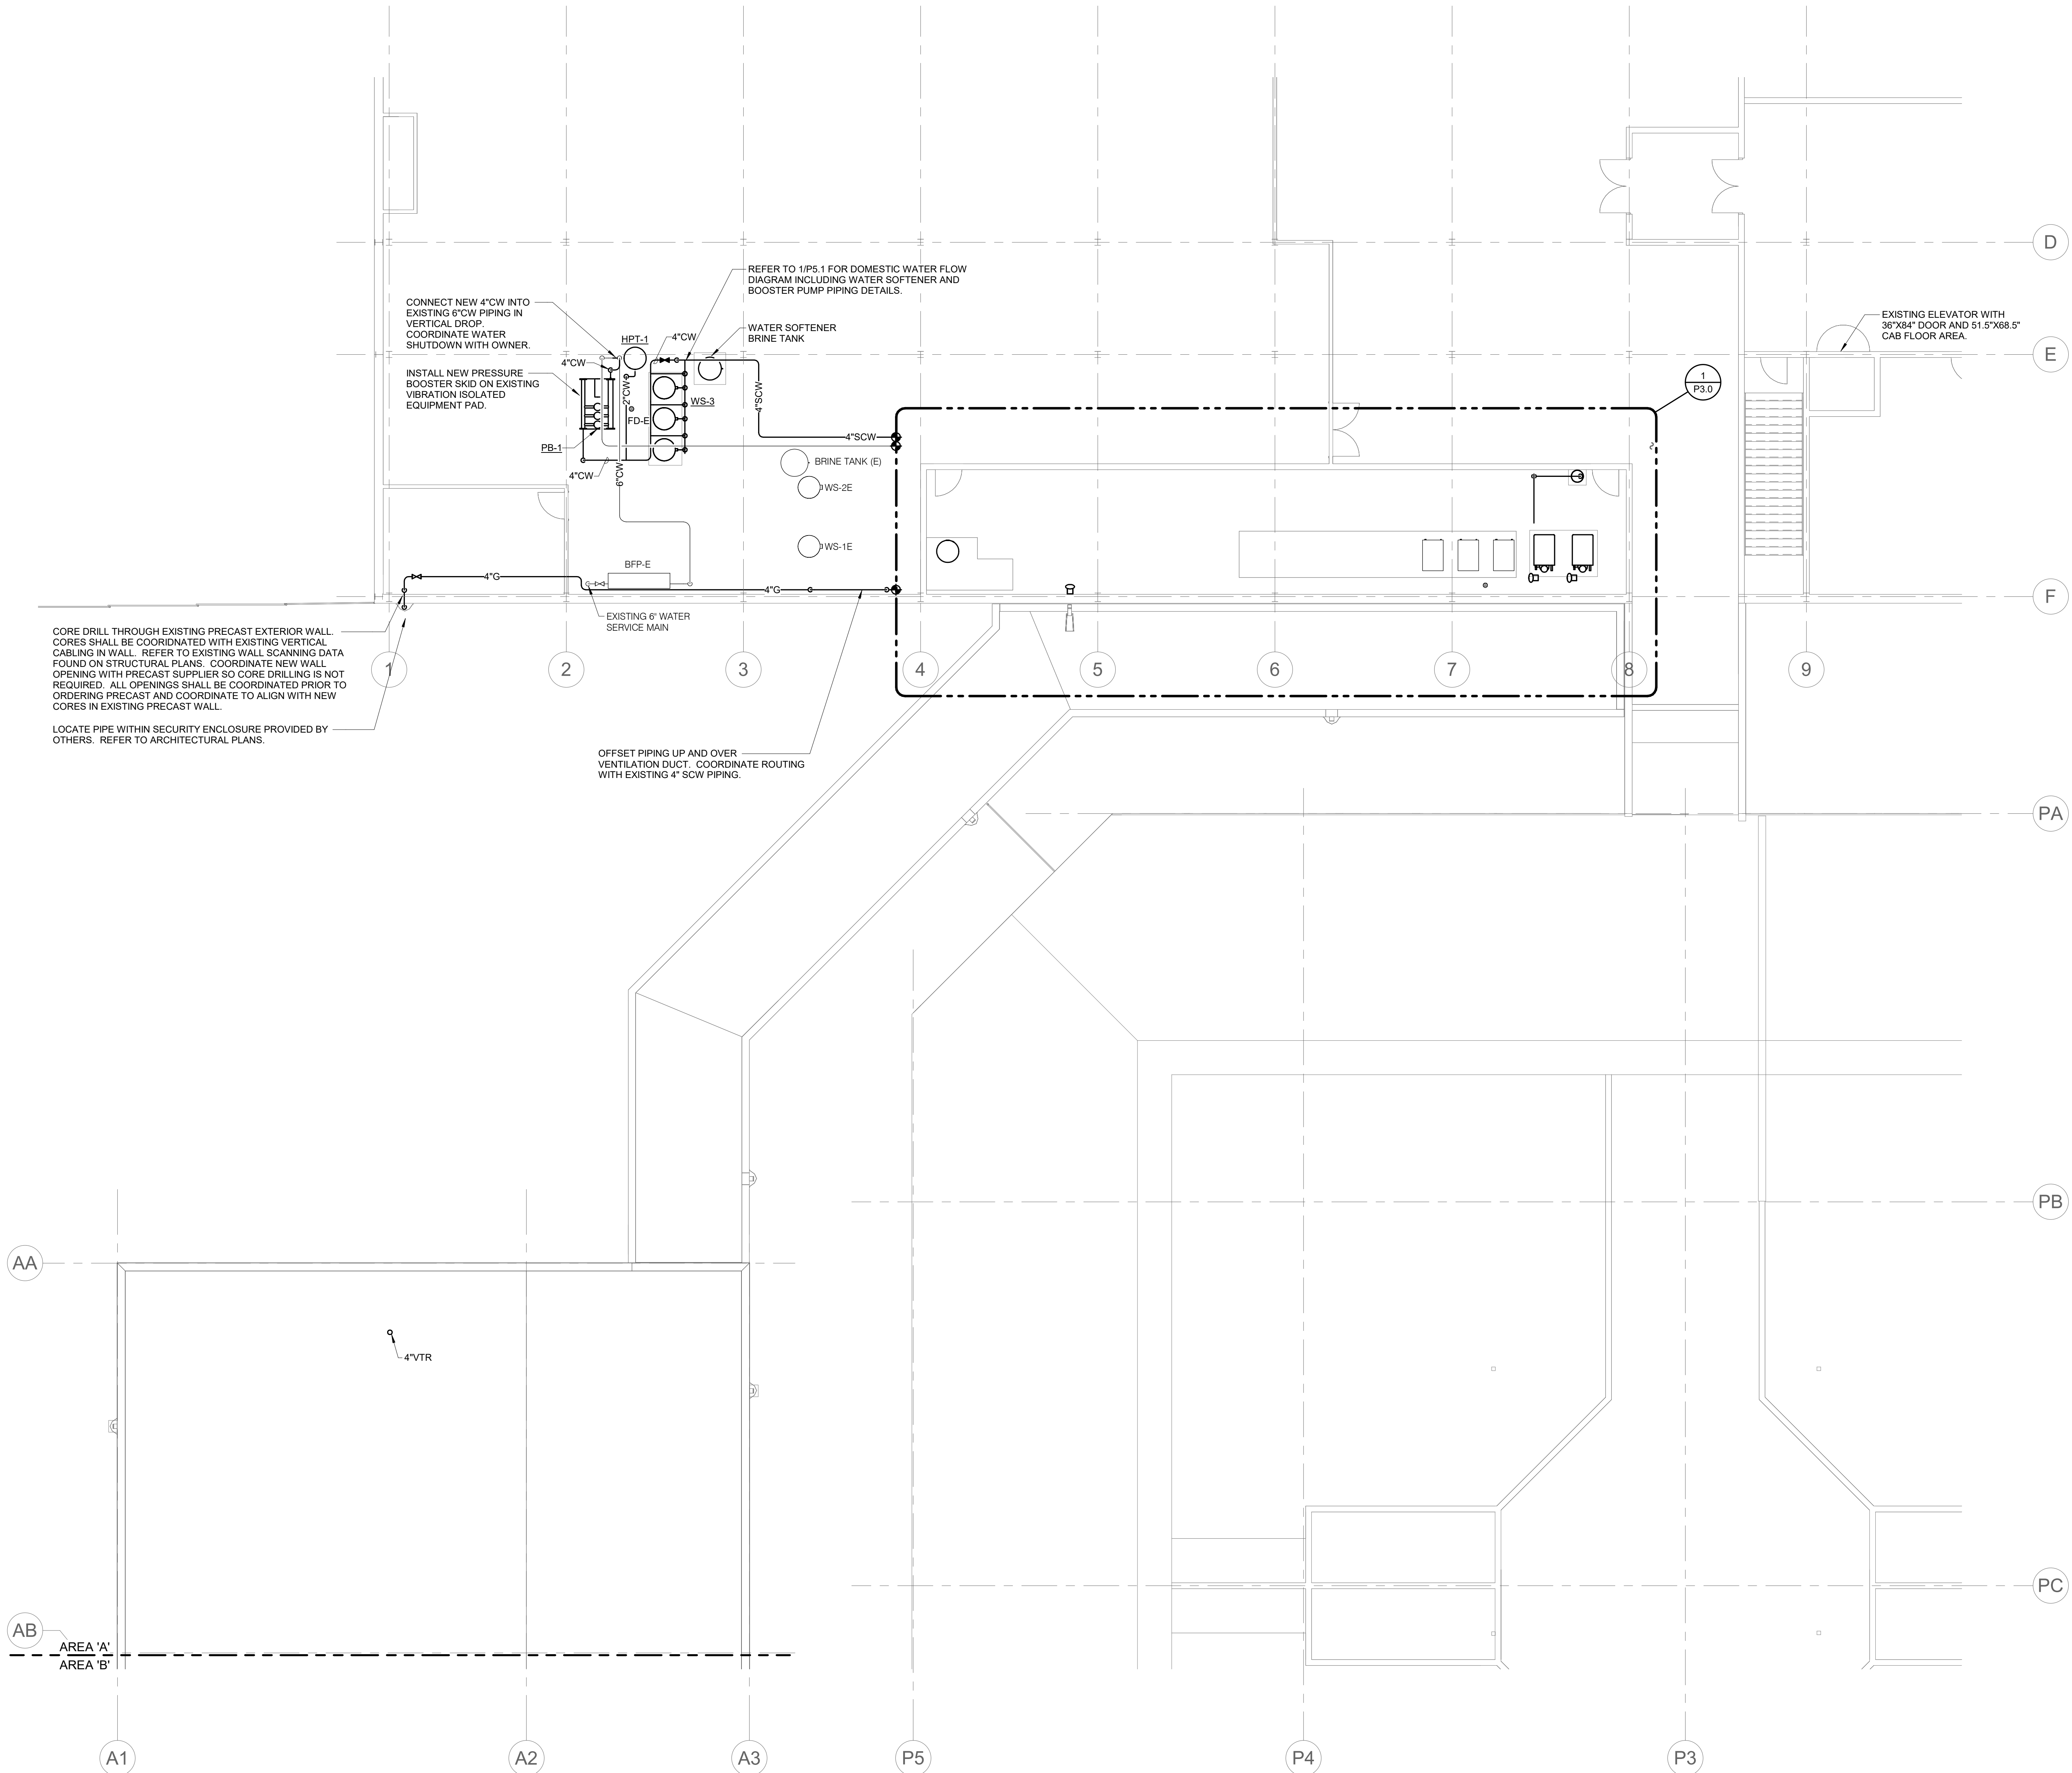

1


LEVEL 02 PLAN - AREA A - PLUMBING

1/8" = 1'-0"

IMEG
www.imegcorp.com
IMEG CORP. RESERVES PROPRIETARY RIGHTS, INCLUDING COPYRIGHTS, TO THIS DRAWING AND THE DATA SHOWN THEREIN. SAID DRAWING AND/OR DATA ARE THE EXCLUSIVE PROPERTY OF IMEG CORP. AND SHALL NOT BE USED OR REPRODUCED FOR ANY OTHER PROJECT WITHOUT THE EXPRESS WRITTEN APPROVAL AND PARTICIPATION OF IMEG CORP. ©2024 IMEG CORP.

2882 10TH STREET
DES MOINES, IA 50322
P: 515.334.9000 F: 515.334.9008

0 1 2 3
REF. SCALE IN INCHES PROJECT #21007888.00

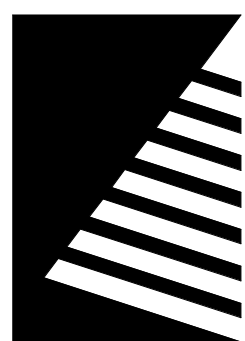

Farnsworth
GROUP

14225 UNIVERSITY AVENUE, SUITE 110
WALKEE, IOWA 50263
(515) 225-3469 / info@f-w.com

www.f-w.com
Engineers | Architects | Surveyors | Scientists

RIPPE ASSOCIATES
FOODSERVICE DESIGN + CONSULTING

kpff

IMEG

Bishop Engineering

ISSUE:
DATE: DESCRIPTION:

BID SET

PROJECT:
STATE OF IOWA - DEPARTMENT
OF CORRECTIONS

CLARINDA
CORRECTIONAL
FACILITY - KITCHEN &
LAUNDRY ADDITION

2000 N 16TH ST, CLARINDA, IA
51632


DATE: 02/09/2024
DESIGNED: MIKMCC
DRAWN: MIKMCC
REVIEWED: DELLLE

SHEET TITLE:
LEVEL 02 PLAN -
AREA B - PLUMBING

SHEET NUMBER:


P1.4

PROJECT NO.: 0240202.00
RFB922300-02

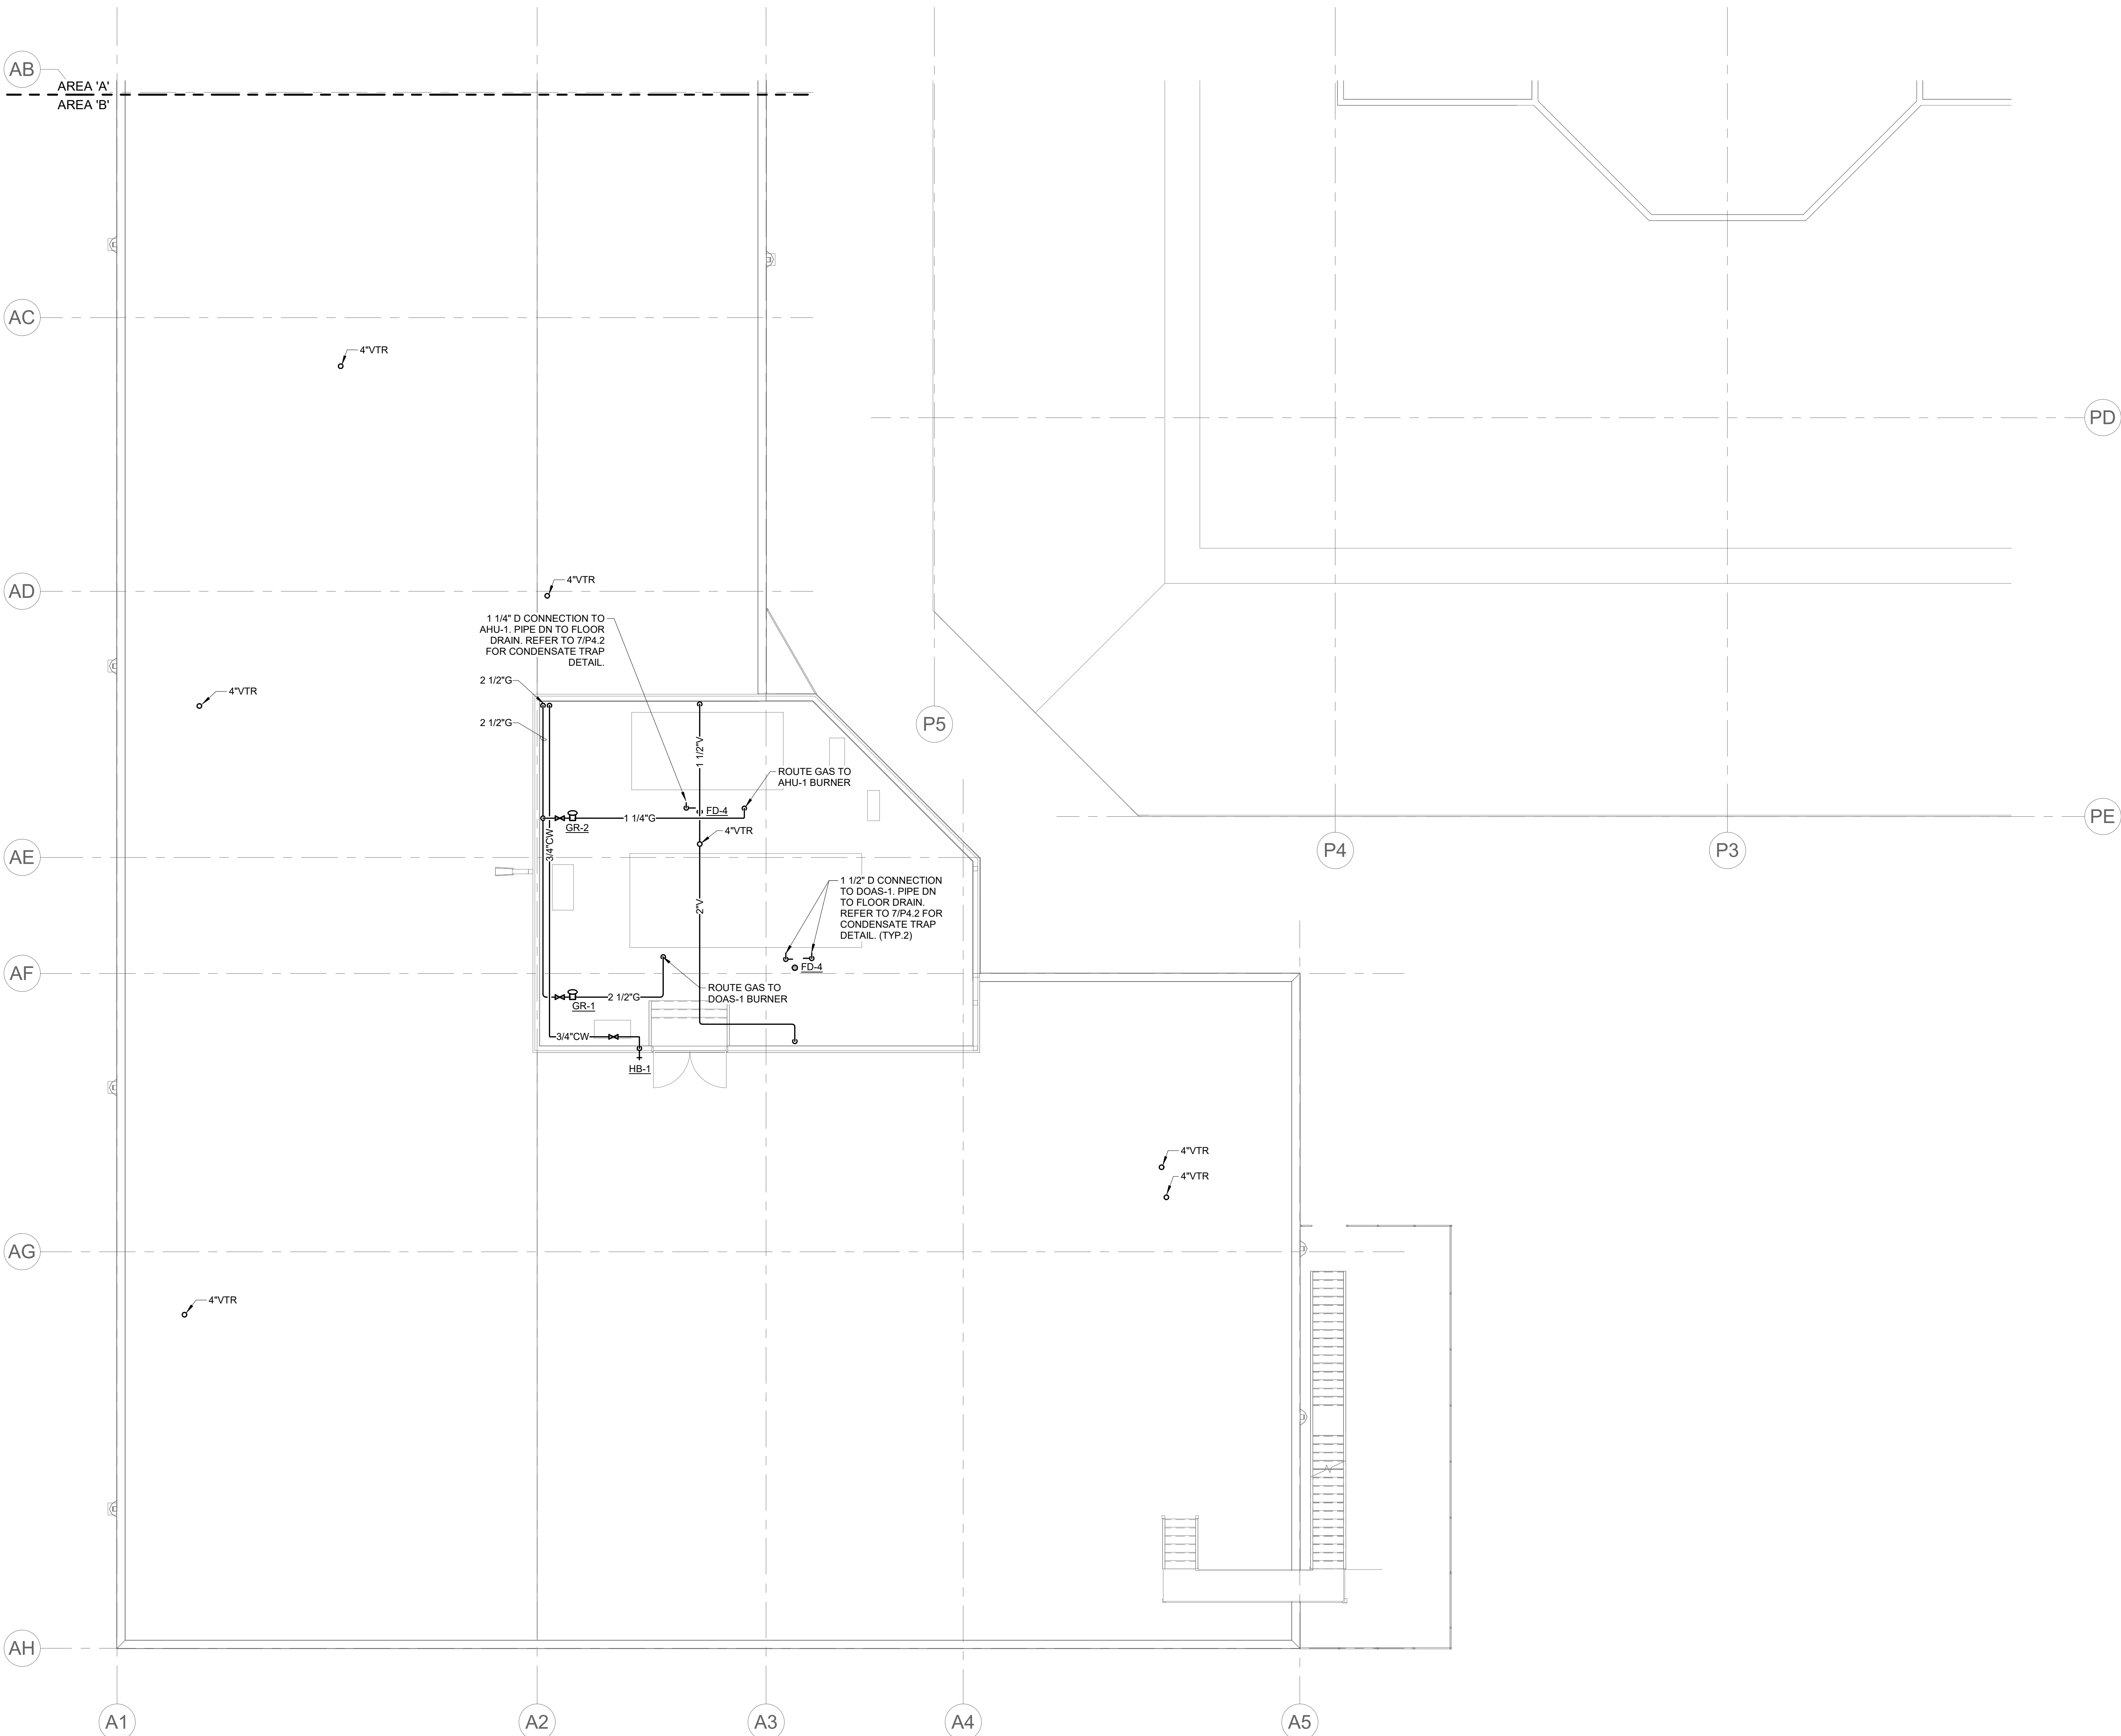


1 LEVEL 02 PLAN - AREA B - PLUMBING
1/8\" = 1'-0"


IMEG
www.imegcorp.com
IMEG CORP. RESERVES PROPRIETARY RIGHTS, INCLUDING COPYRIGHTS, TO THIS DRAWING AND THE DATA SHOWN THEREON. SAID DRAWING AND/OR DATA ARE THE EXCLUSIVE PROPERTY OF IMEG CORP. AND SHALL NOT BE USED OR REPRODUCED FOR ANY OTHER PROJECT WITHOUT THE EXPRESS WRITTEN APPROVAL AND PARTICIPATION OF IMEG CORP. ©2024 IMEG CORP.
2882 10TH STREET
DES MOINES, IA 50322
P: 515.334.9000 F: 515.334.9008
PROJECT #21007888.00
REF. SCALE IN INCHES
0 1 2 3

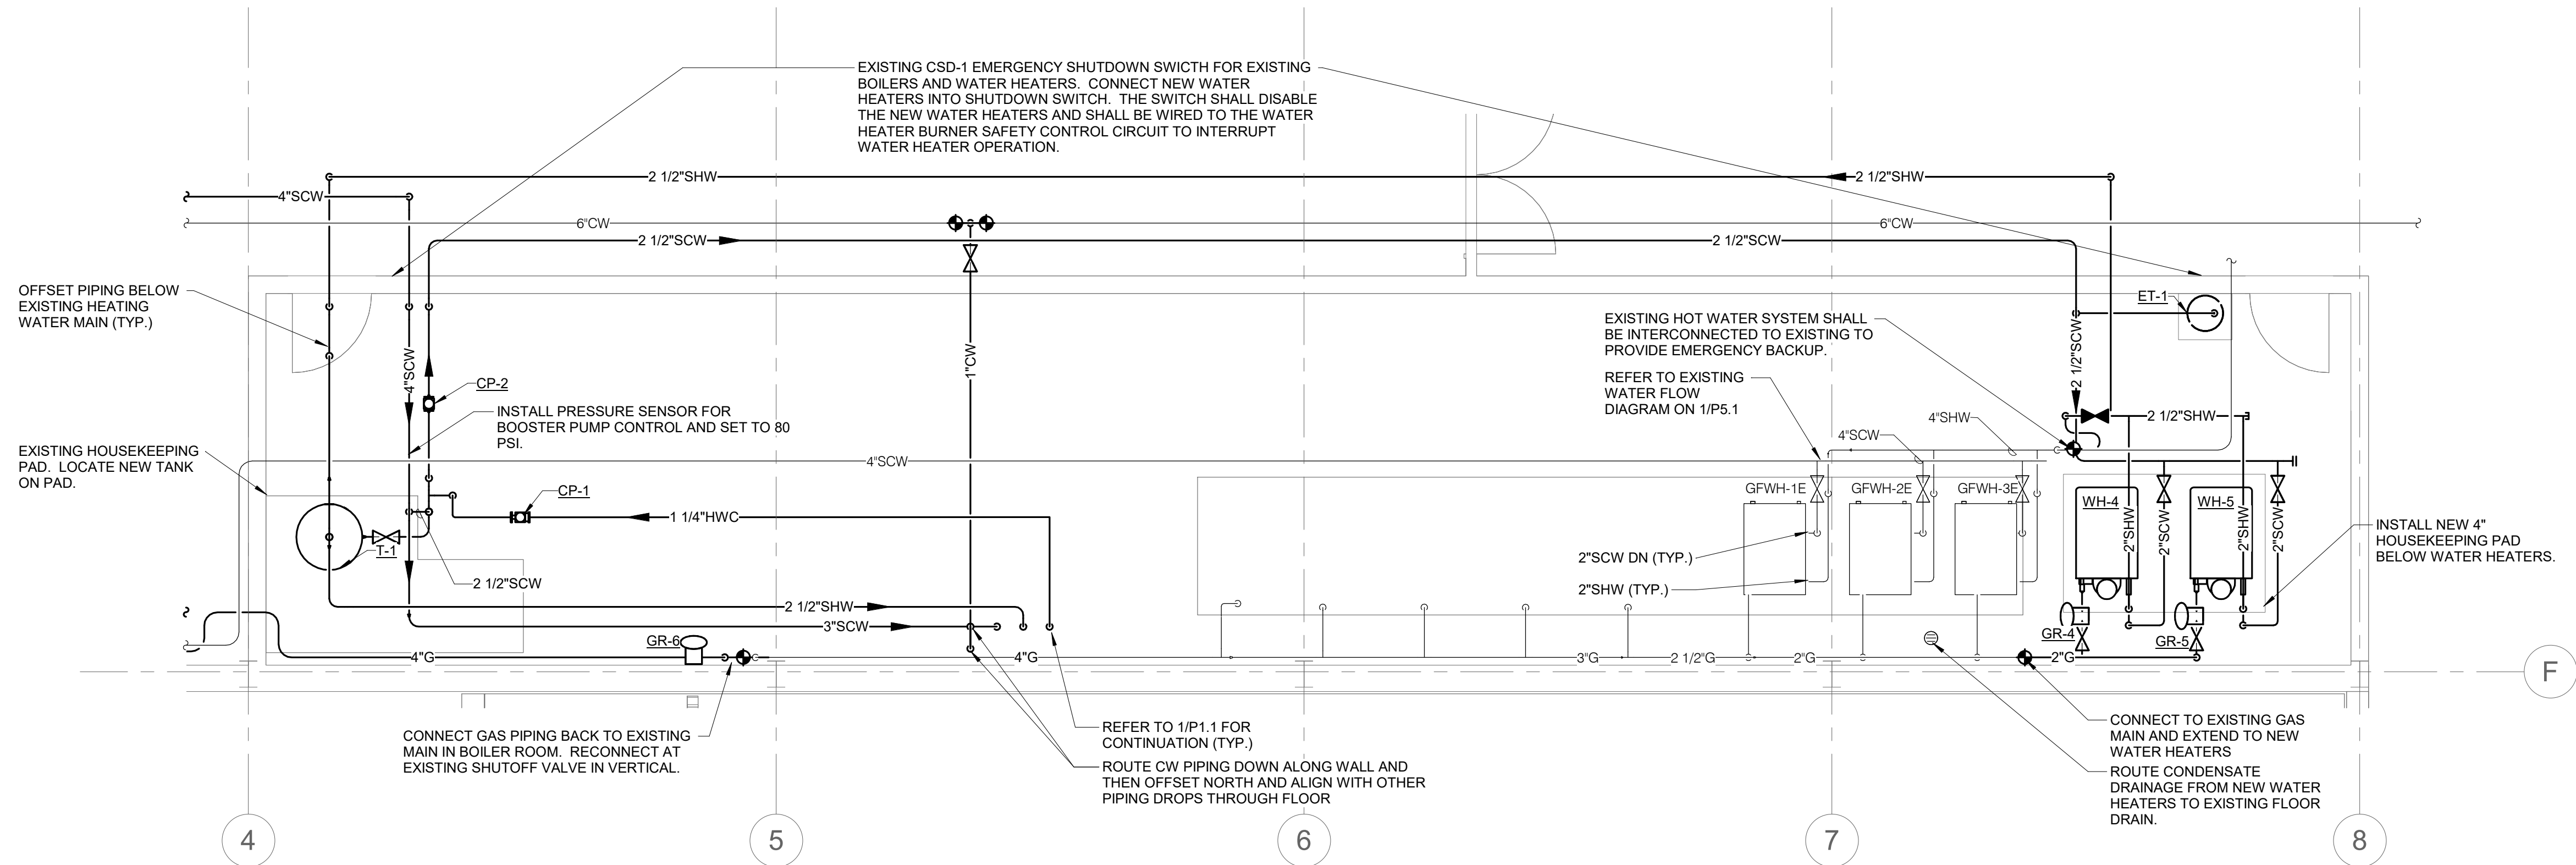


1 LEVEL 02 PLAN - AREA A - PLUMBING - EXISTING BOILER/WATER HEATER ROOM
1/4" = 1'-0"

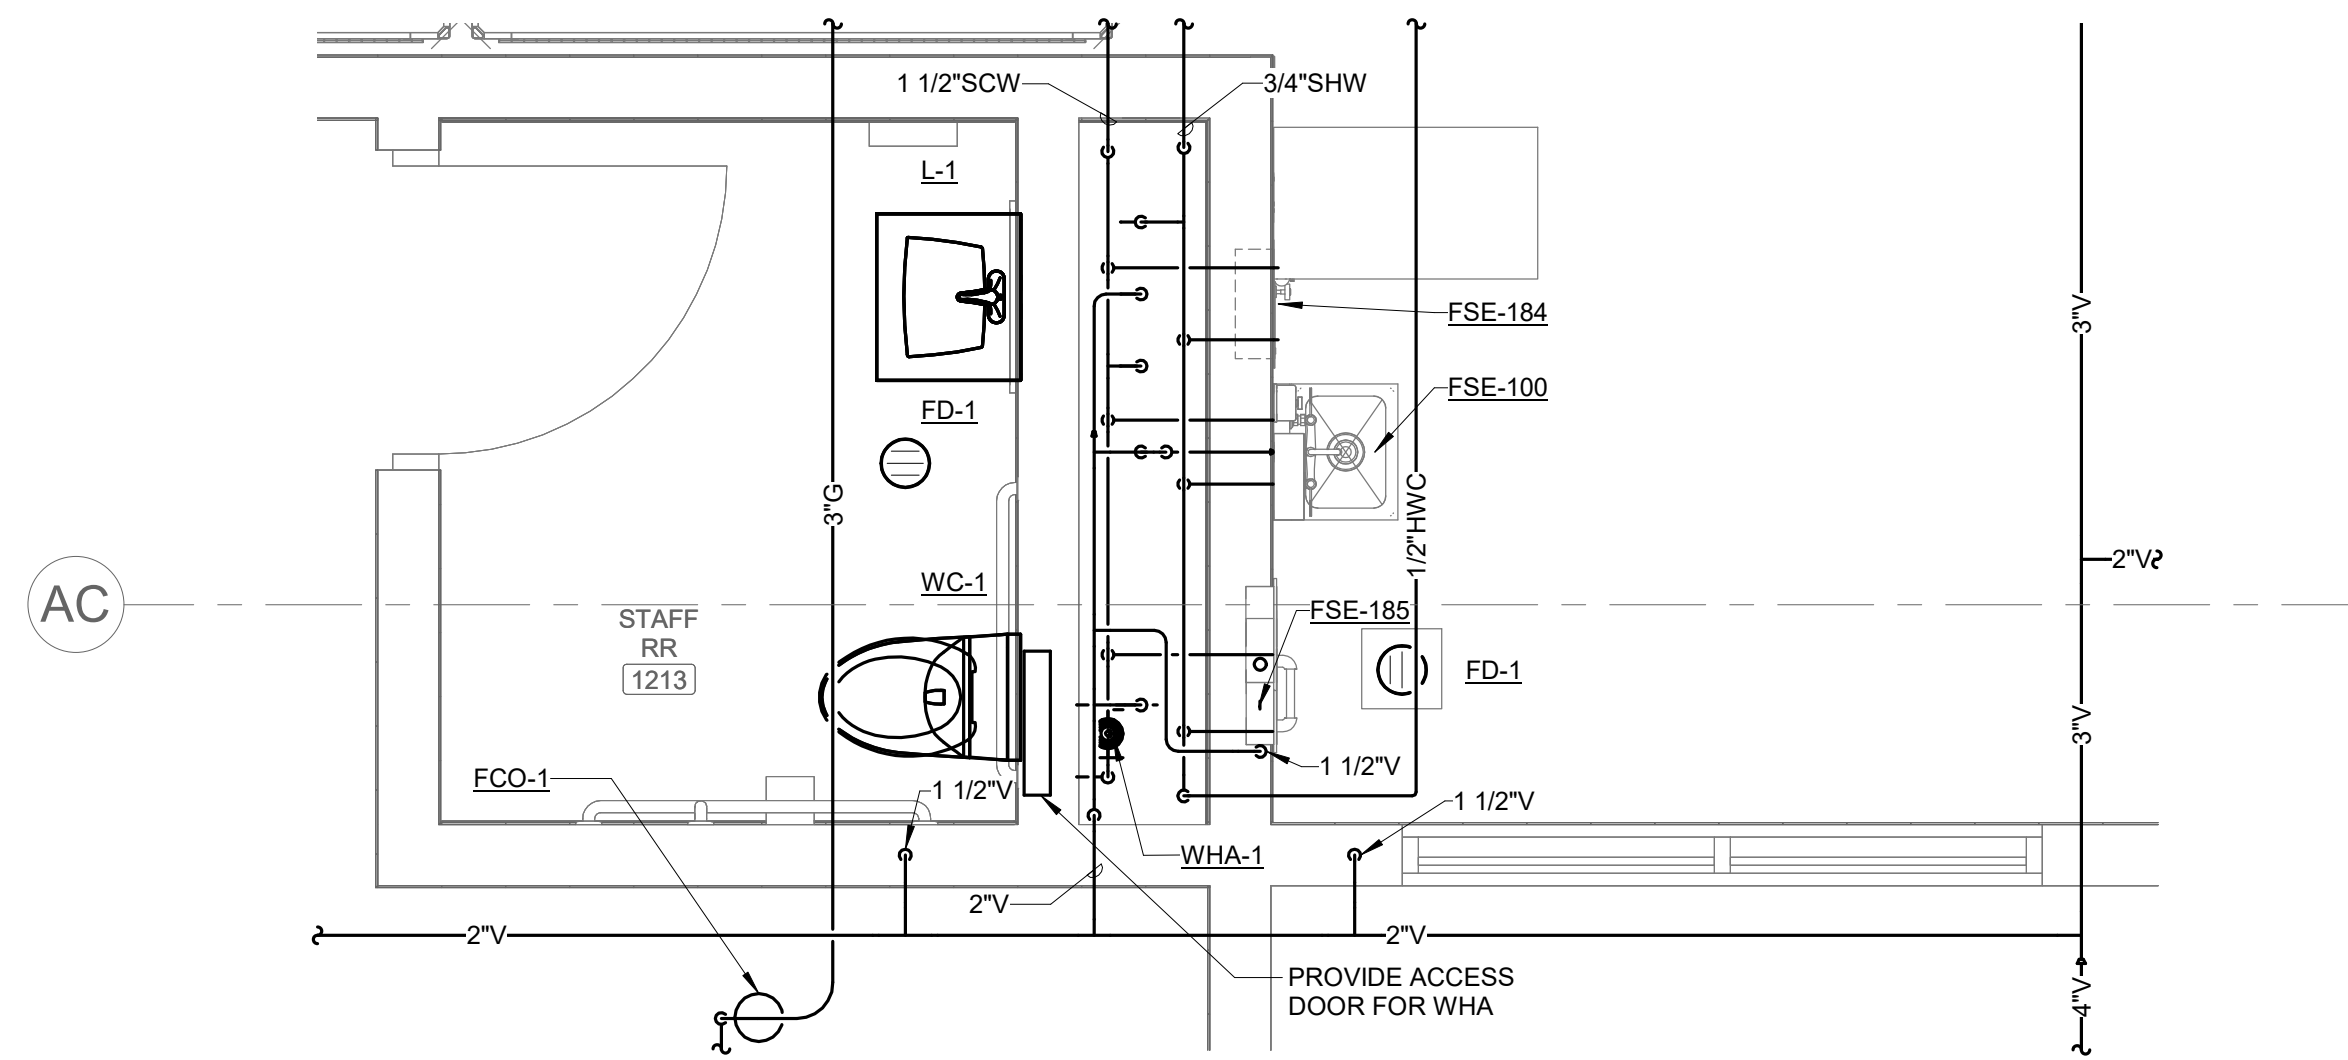

2 ENLARGED STAFF RR PLAN - AREA B - PLUMBING
1/2" = 1'-0"

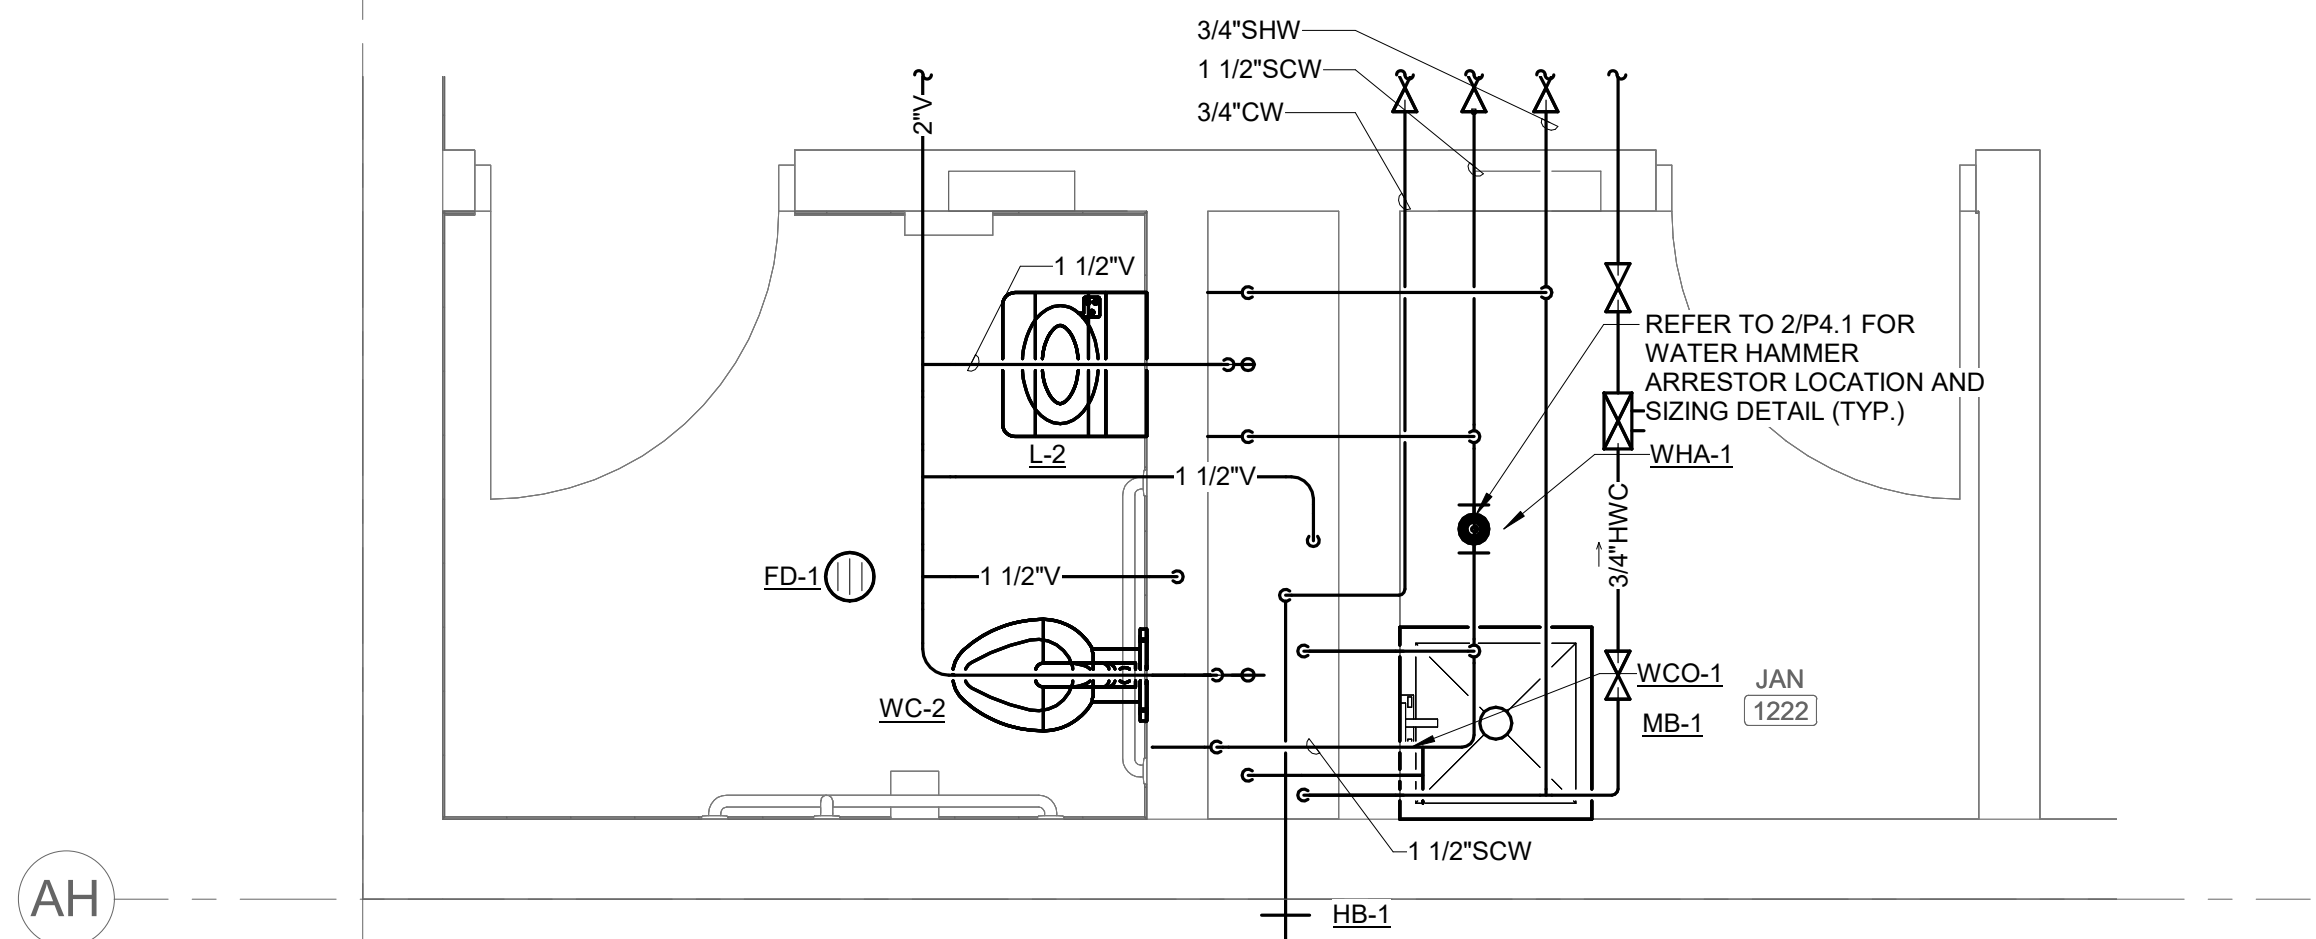

3 ENLARGED OFFENDER RR/JC PLAN - AREA B - PLUMBING
1/2" = 1'-0"

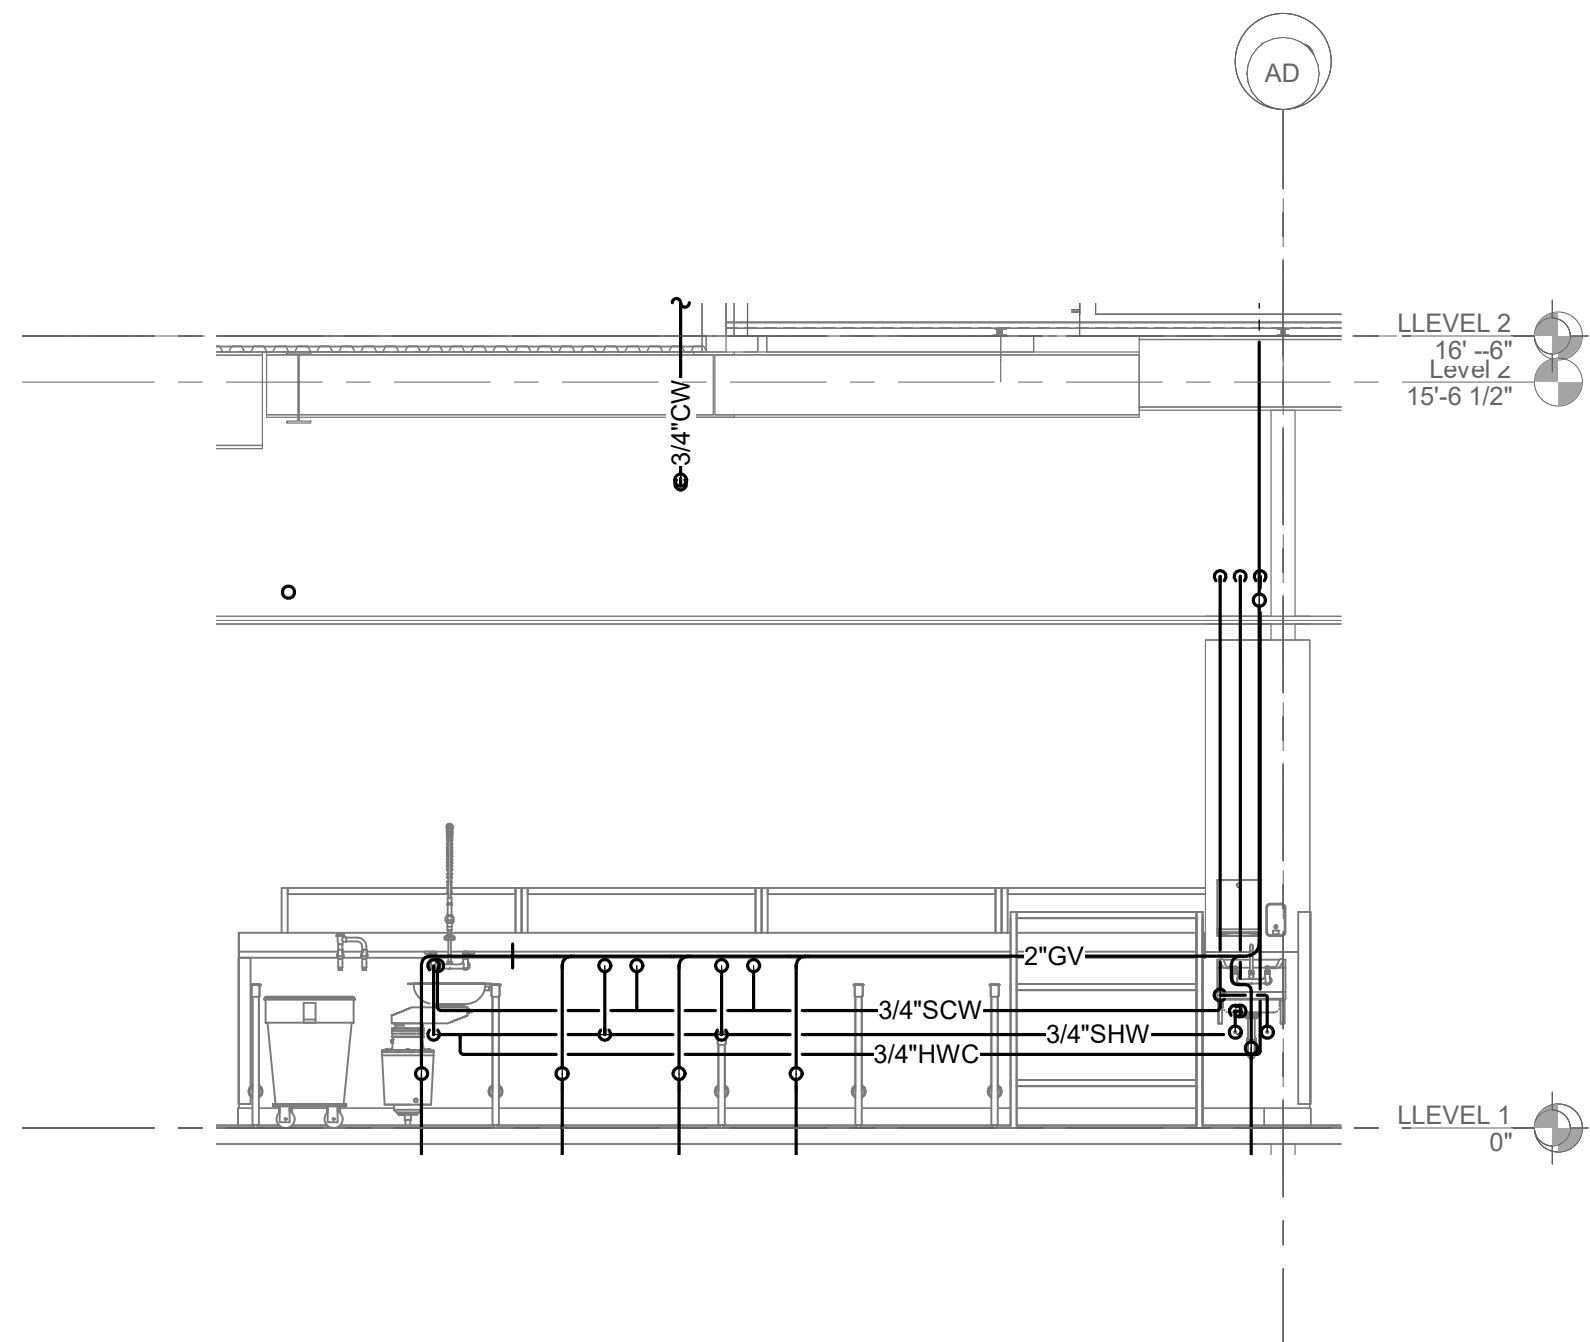


4 POT AND PAN WASHING SECTION
1/4" = 1'-0"

IMEG
www.imegcorp.com
IMEG CORP. RESERVES PROPRIETARY RIGHTS, INCLUDING COPYRIGHTS, TO THIS DRAWING AND THE DATA SHOWN THEREIN. SAID DRAWING AND/OR DATA ARE THE EXCLUSIVE PROPERTY OF IMEG CORP. AND SHALL NOT BE USED OR REPRODUCED FOR ANY OTHER PROJECT WITHOUT THE EXPRESS WRITTEN APPROVAL AND PARTICIPATION OF IMEG CORP. ©2024 IMEG CORP.

2882 10TH STREET
DES MOINES, IA 50322
P: 515.334.9000 F: 515.334.9008
PROJECT #21007888.00

0 1 2 3
REF. SCALE IN INCHES

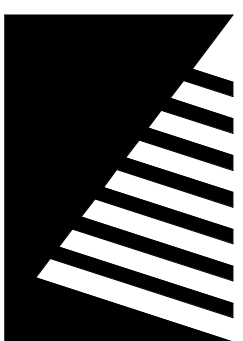

Farnsworth GROUP

14225 UNIVERSITY AVENUE, SUITE 110
WALKEE, IOWA 50263
(515) 225-3469 / info@f-w.com

www.f-w.com
Engineers | Architects | Surveyors | Scientists

RIPPE ASSOCIATES
FOODSERVICE DESIGN + CONSULTING

kpff

IMEG

Bishop Engineering

ISSUE:
DATE: DESCRIPTION:

BID SET

PROJECT:
STATE OF IOWA - DEPARTMENT
OF CORRECTIONS

**CLARINDA
CORRECTIONAL
FACILITY - KITCHEN &
LAUNDRY ADDITION**

2000 N 16TH ST, CLARINDA, IA
51632

DATE: 02/09/2024

DESIGNED: MIKMCC

DRAWN: MIKMCC

REVIEWED: DELLLE


SHEET TITLE:

**ENLARGED PLAN -
PLUMBING**

SHEET NUMBER:

P3.0

PROJECT NO.: 0240202.00
RFB922300-02

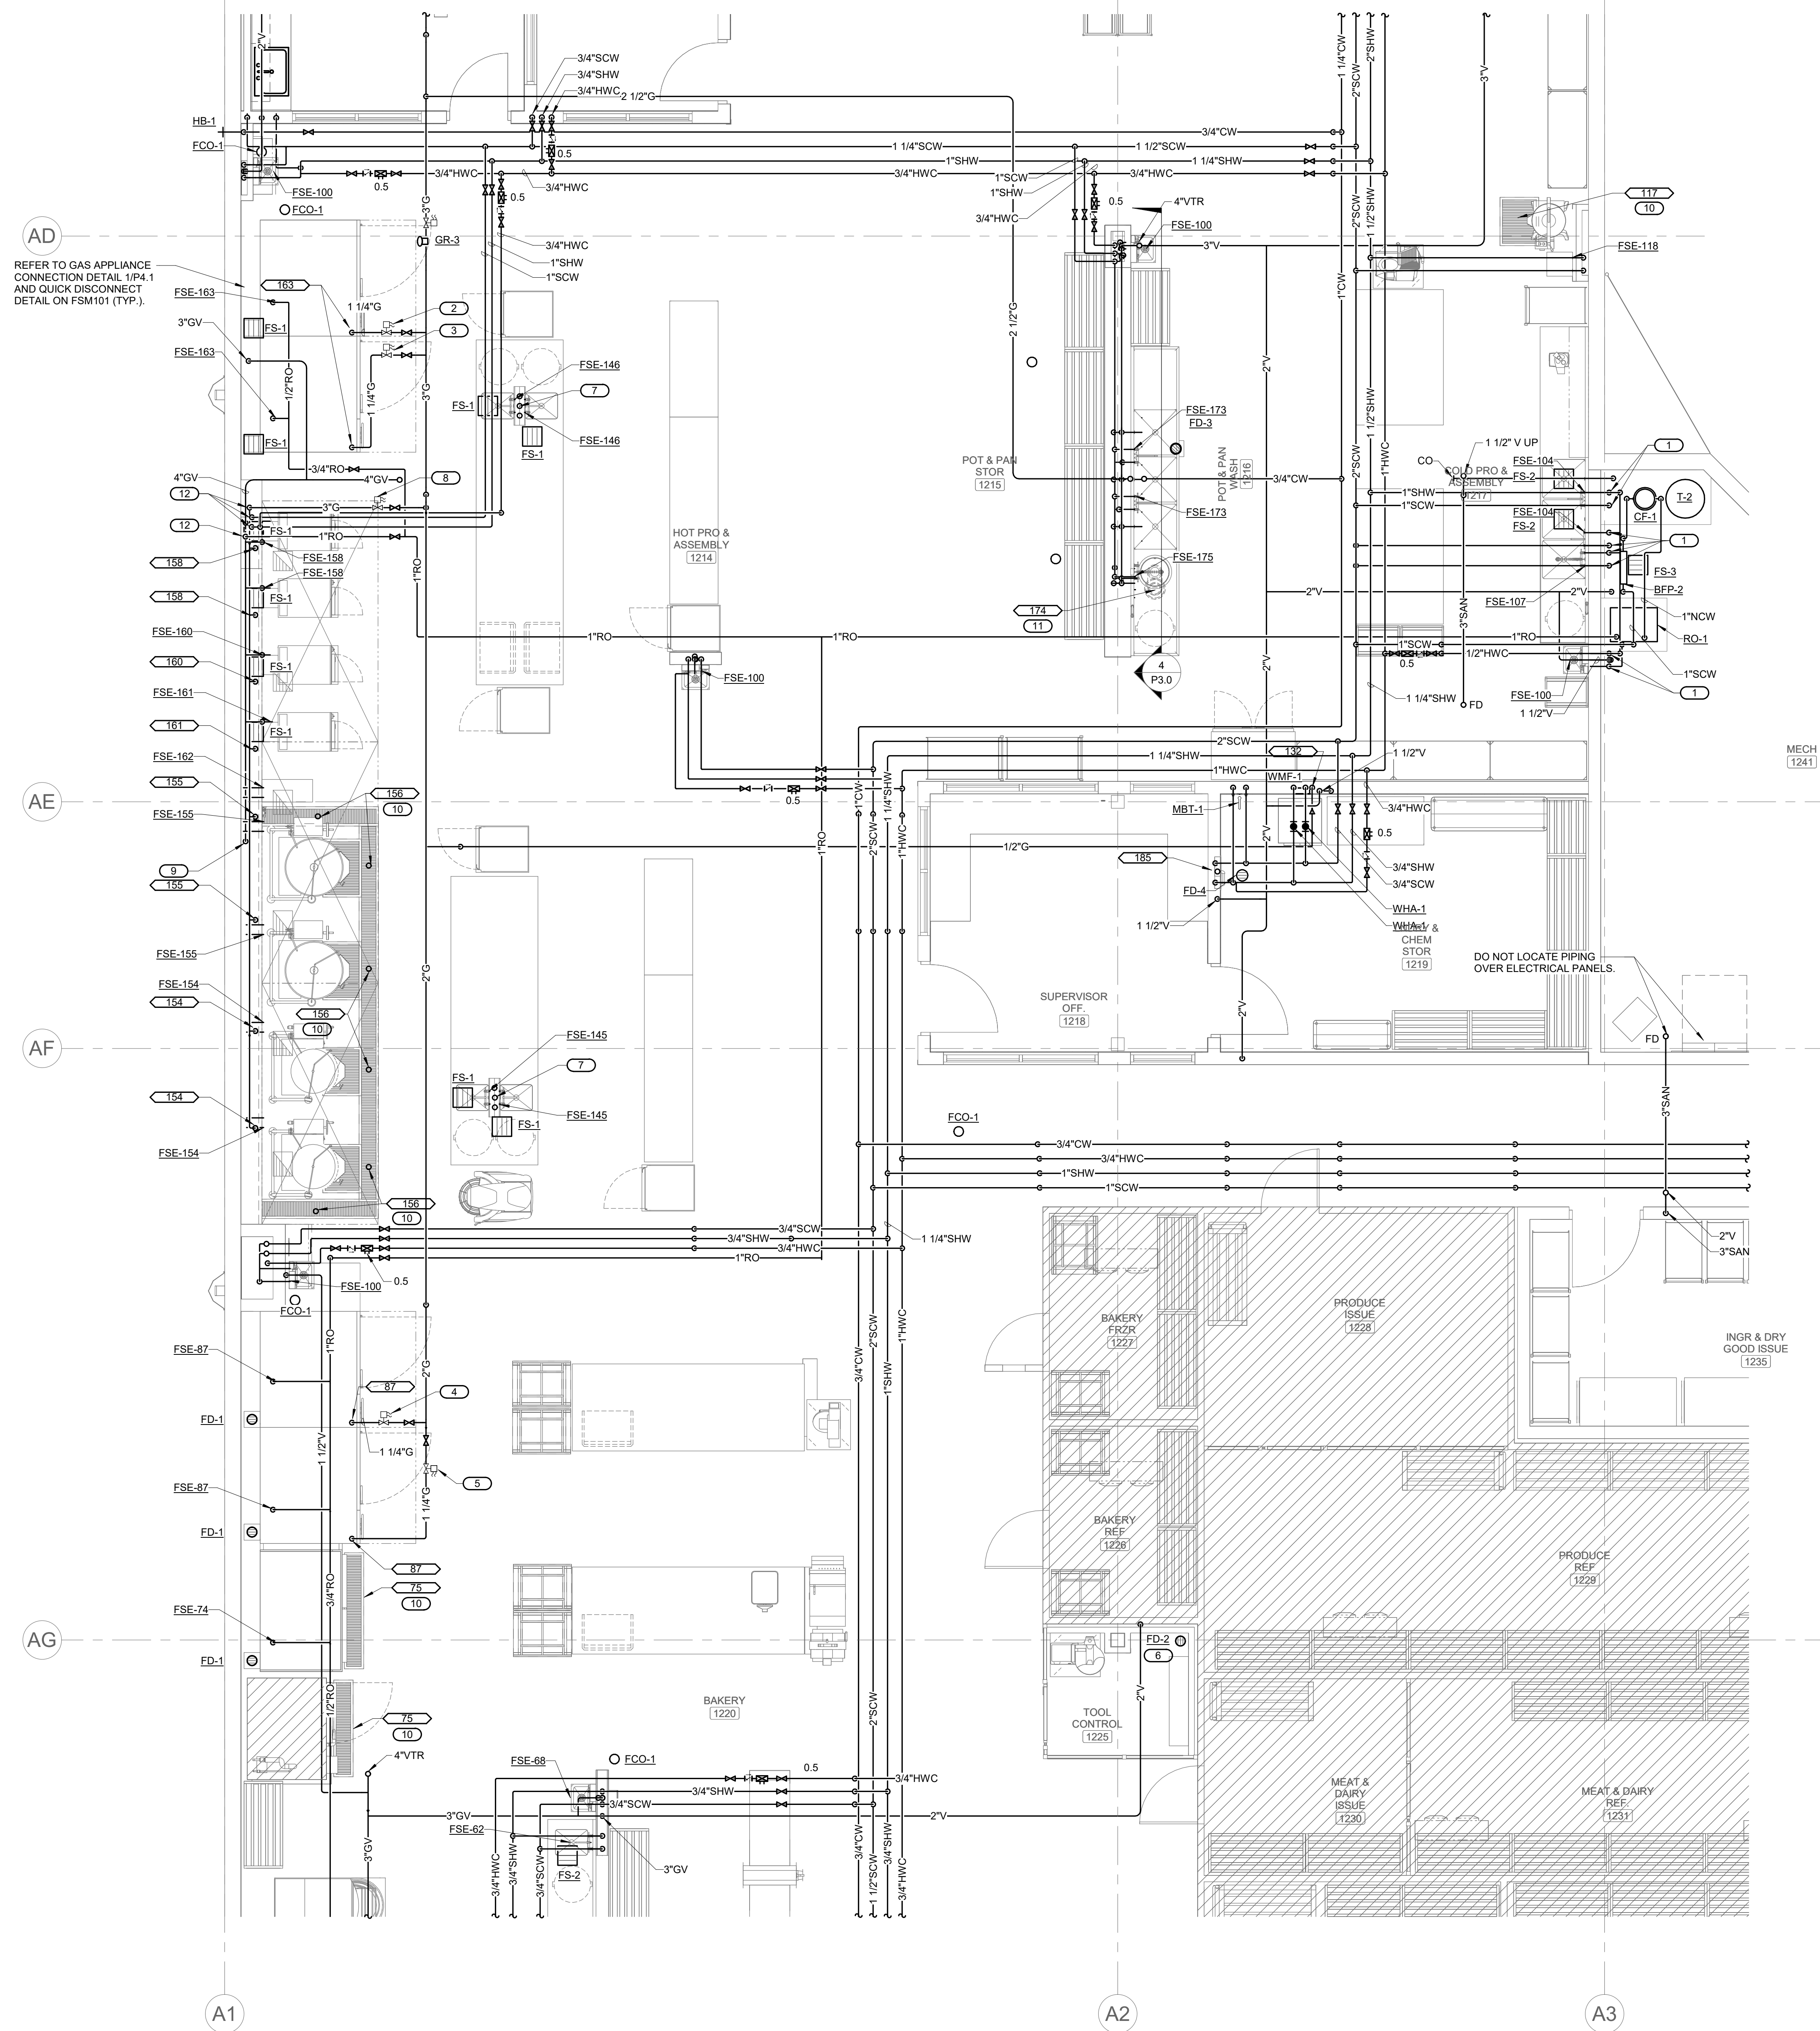

- KEYNOTES:** (#)
1. ROUTE PIPING EXPOSED IN MECHANICAL ROOM AND STUB THROUGH CMU TO FIXTURE.
 2. INSTALL GAS SHUT-OFF VALVE FURNISHED BY FSEC AS PART OF HOOD FIRE PROTECTION SYSTEM (FSE #169) SERVING RACK OVEN (FSE #163).
 3. INSTALL GAS SHUT-OFF VALVE FURNISHED BY FSEC AS PART OF HOOD FIRE PROTECTION SYSTEM (FSE #170) SERVING RACK OVEN (FSE #163).
 4. INSTALL GAS SHUT-OFF VALVE FURNISHED BY FSEC AS PART OF HOOD FIRE PROTECTION SYSTEM (FSE #89) SERVING RACK OVEN (FSE #87).
 5. INSTALL GAS SHUT-OFF VALVE FURNISHED BY FSEC AS PART OF HOOD FIRE PROTECTION SYSTEM (FSE #90) SERVING RACK OVEN (FSE #87).
 6. FLOOR DRAIN SHALL RECEIVE REFRIGERATION SYSTEM COIL CONDENSATE. ROUTING OF CONDENSATE PIPING TO FLOOR DRAIN SHALL BE BY FSEC.
 7. ROUTE PIPING UP TO ISLAND FIXTURES. REFER TO 3/P4.2.
 8. INSTALL GAS SHUT-OFF VALVE FURNISHED BY FSEC AS PART OF HOOD FIRE PROTECTION SYSTEM (FSE #151) SERVING MAIN GREASE EXHAUST HOOD (FSE #148).
 9. 4" GV CIRCUIT VENT SERVING FLOOR SINKS AND TROUGHS. COORDINATE ROUTING OF 4" GV WITH FSEC AND UDS CONFIGURATION. 4" GV SHALL ROUTE HORIZONTALLY IN UDS AND THEN RISE AT NORTH END WITH ALL UDS CONNECTIONS.
 10. FLOOR TROUGH PROVIDED BY FSEC, INSTALLED BY P.C.
 11. REFER TO DISPOSER DETAIL ON FSM101 FOR PIPING DETAIL AND SCOPE OF WORK BETWEEN FSEC AND P.C.
 12. P.C. TO ROUTE PIPING TO UTILITY DISTRIBUTION SYSTEM (UDS) PROVIDED BY FSEC. PIPING ALONG WALL BENEATH HOOD WILL BE PART OF THE UDS. THE UDS WILL HAVE STUB OUTS FOR EACH PIECE OF EQUIPMENT. P.C. SHALL CONNECT TO STUB OUTS AND EXTEND TO EQUIPMENT. ROUGH-IN SIZES FOR UDS SHALL BE 2 1/2" G, 1" SCW, 1" SHW AND 1" RO.

LEVEL 01 PLAN - AREA B - PLUMBING - MAIN KITCHEN AREAS
1/4" = 1'-0"

IMEG
www.imegcorp.com
IMEG CORP. RESERVES PROPRIETARY RIGHTS, INCLUDING COPYRIGHTS, TO THIS DRAWING AND THE DATA SHOWN THEREIN. SAID DRAWING AND/OR DATA ARE THE EXCLUSIVE PROPERTY OF IMEG CORP. AND SHALL NOT BE USED OR REPRODUCED FOR ANY OTHER PROJECT WITHOUT THE EXPRESS WRITTEN APPROVAL AND PARTICIPATION OF IMEG CORP. ©2024 IMEG CORP.

2882 100TH STREET
DES MOINES, IA 50322
P: 515.334.9000 F: 515.334.9008

REF. SCALE IN INCHES PROJECT #21007888.00

Farnsworth GROUP
14225 UNIVERSITY AVENUE, SUITE 110
WALKEE, IOWA 50263
(515) 225-3469 / info@f-w.com
www.f-w.com
Engineers | Architects | Surveyors | Scientists

RIPPE ASSOCIATES
FOODSERVICE DESIGN + CONSULTING

kpff

IMEG
Bishop Engineering

ISSUE: # DATE: DESCRIPTION:

BID SET

PROJECT: STATE OF IOWA - DEPARTMENT OF CORRECTIONS

CLARINDA CORRECTIONAL FACILITY - KITCHEN & LAUNDRY ADDITION


2000 N 16TH ST, CLARINDA, IA 51632

DATE: 02/09/2024
DESIGNED: MIKMCC
DRAWN: MIKMCC
REVIEWED: DELLE

SHEET TITLE: **ENLARGED PLAN - PLUMBING**

SHEET NUMBER: **P3.1**


PROJECT NO.: 0240202.00
RFB922300-02

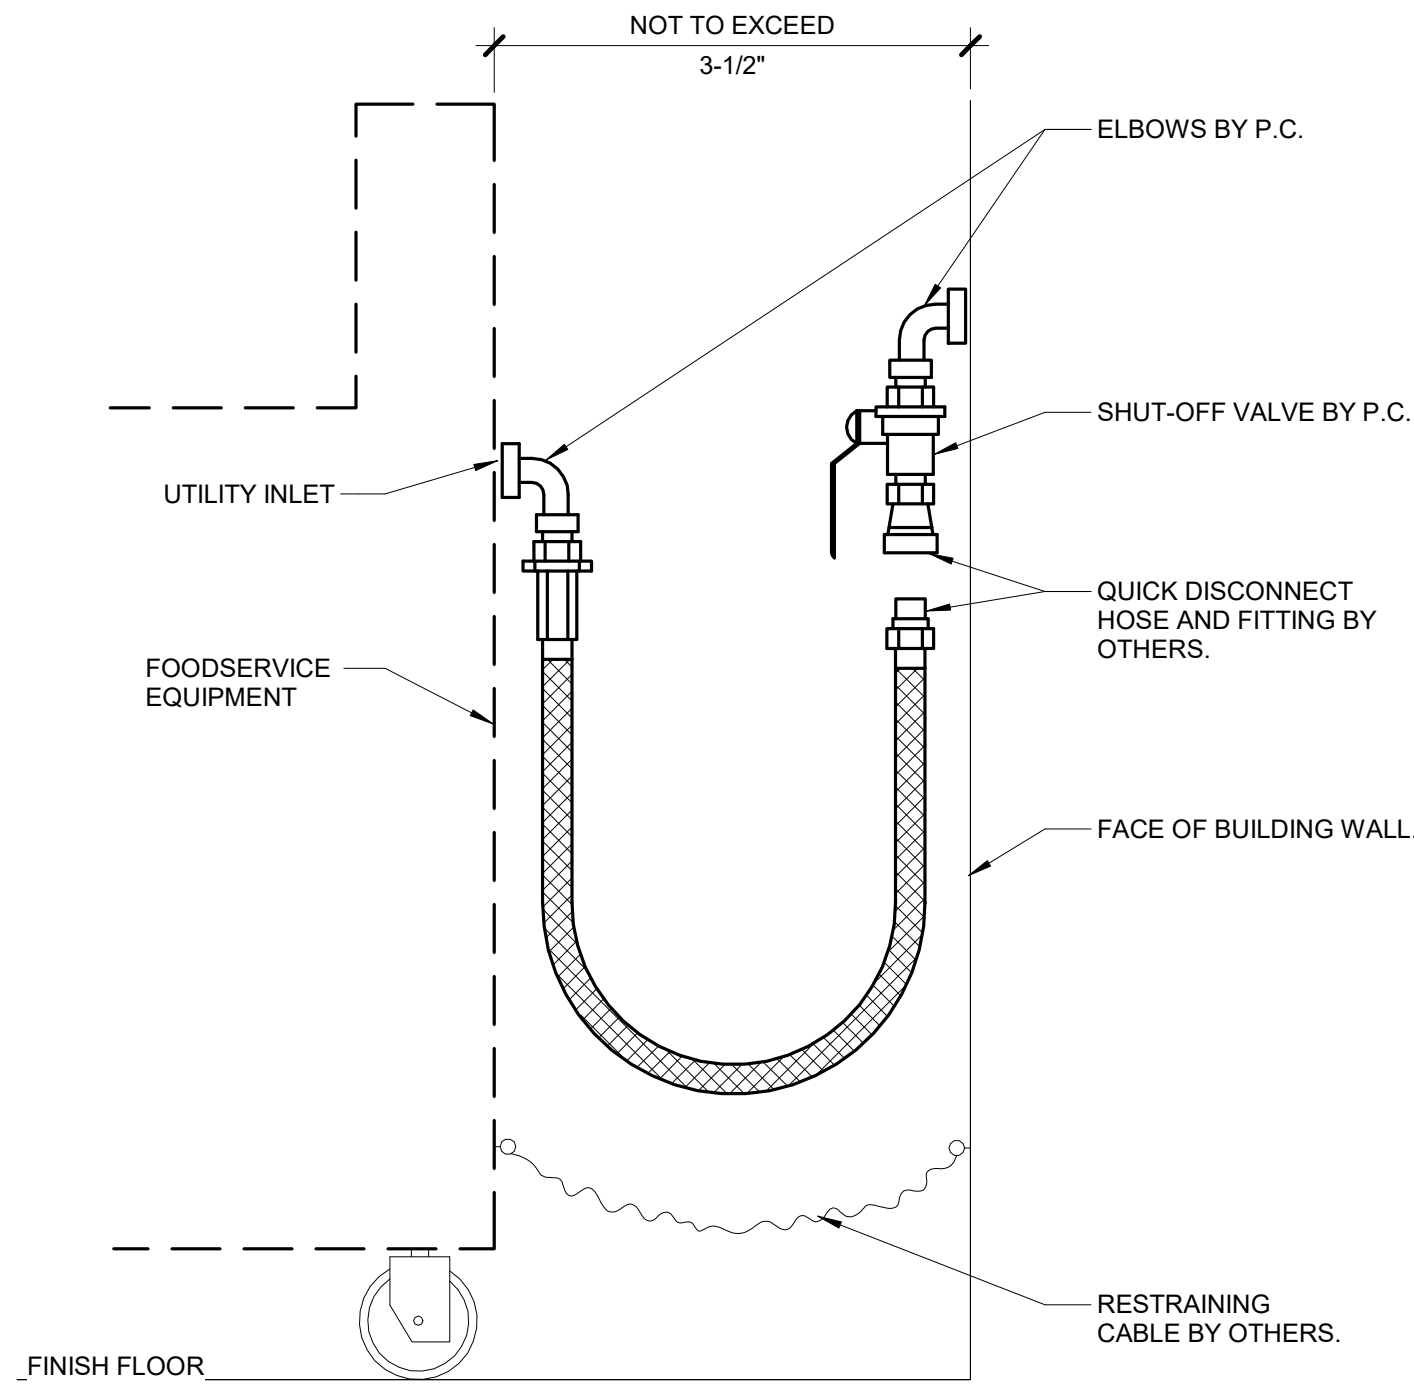

1 GAS APPLIANCE CONNECTION DETAIL

NO SCALE
NOTES:

1. VERIFY UTILITY INLET LOCATION ON KITCHEN APPLIANCE AND EXTEND PIPING AS REQUIRED TO ABOVE CONFIGURATION.
2. INSTALL GAS PRESSURE REGULATOR(PROVIDE BY OTHERS) DOWNSTREAM OF SHUT-OFF VALVE IF REQUIRED BY MANUFACTURER. PIPE GAS VENTS TO EXTERIOR.

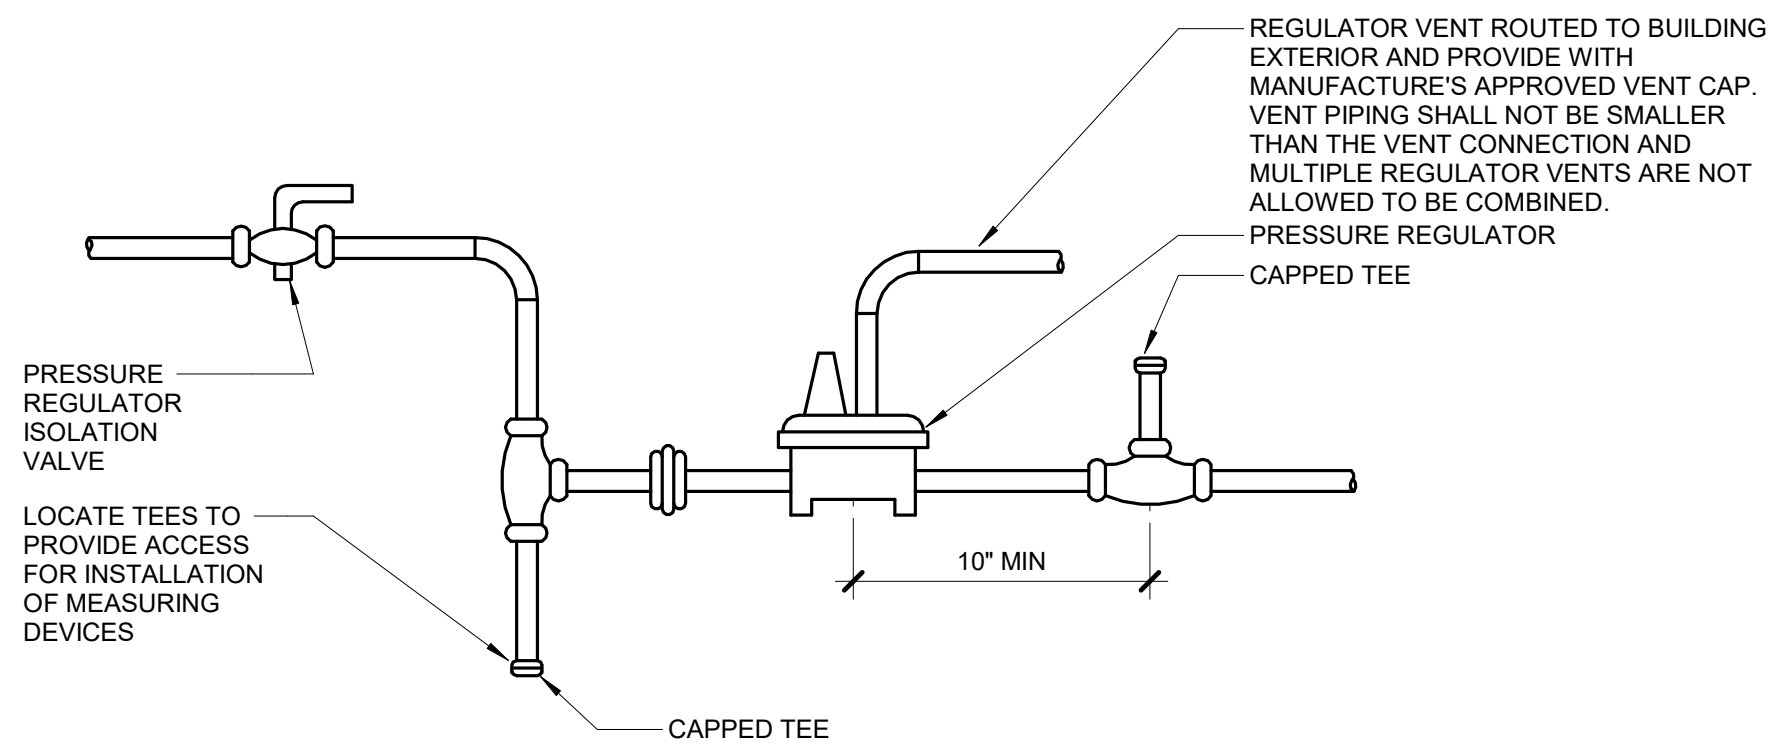


4 GAS PRESSURE REGULATOR DETAIL

NO SCALE

PROVIDE WATER HAMMER ARRESTER (WHA-#) AT PLUMBING FIXTURES AND QUICK CLOSING VALVES AS INDICATED ON DRAWINGS AND AS RECOMMENDED BY STANDARD PDI-WH201. REFER TO PLUMBING MATERIAL LIST FOR WATER HAMMER ARRESTER DESCRIPTION.


SINGLE / DOUBLE FIXTURE

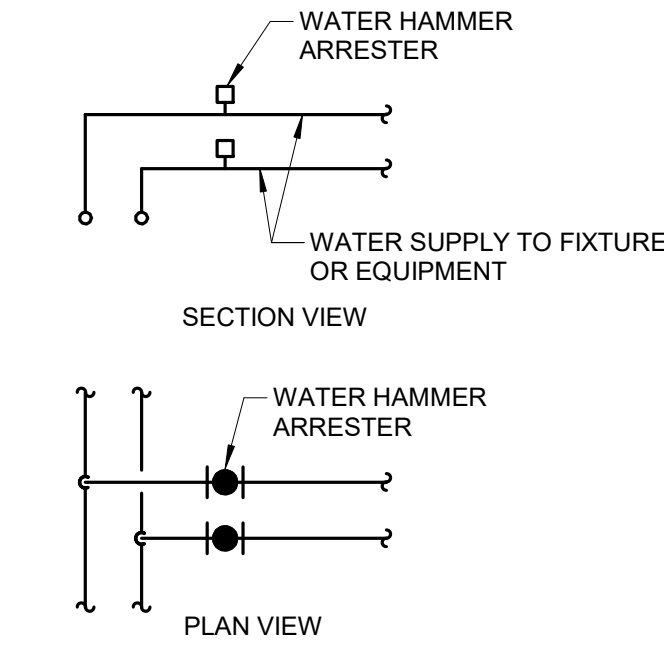

PDI SIZE	PIPE SIZE	FIXTURE UNIT LOAD
A	1/2"	1-11
B	3/4"	12-32
C	1"	33-60
D	1-1/4"	61-113
E	1-1/2"	114-154
F	2"	155-330

INSTALL WHA'S PER PDI STANDARDS AND MANUFACTURER'S INSTRUCTIONS. INSTALL IN HORIZONTAL OR VERTICAL POSITION, BUT NEVER UPSIDE DOWN. INSTALL IN LINE WITH WATER FLOW DIRECTION IF POSSIBLE. SIZE THE WHA AS SHOWN PER THE TABLES ABOVE. PROVIDE ACCESSIBILITY TO WHA WITH ACCESS PANEL OR INSTALL ABOVE ACCESSIBLE CEILING.

MULTIPLE FIXTURES

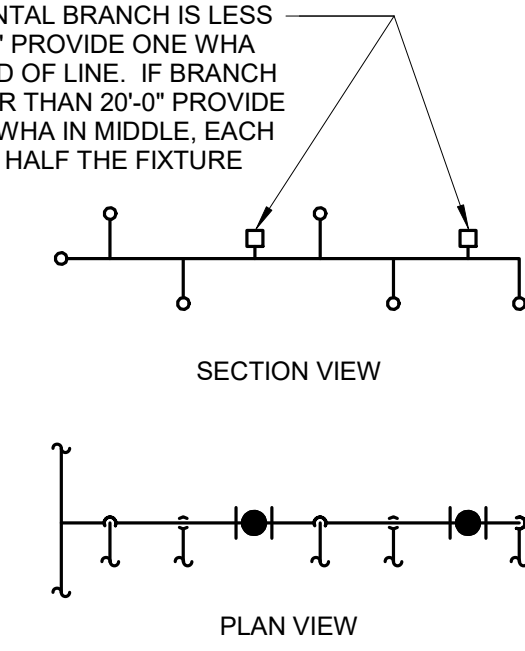


IF HORIZONTAL BRANCH IS LESS THAN 20'-0" PROVIDE ONE WHA AT THE END OF LINE. IF BRANCH IS GREATER THAN 20'-0" PROVIDE ANOTHER WHA IN MIDDLE, EACH SIZED FOR HALF THE FIXTURE UNITS.

FIXTURE UNIT CALCULATION		
FIXTURE	COLD	HOT
WATER CLOSET (F.V.)	10	--
WATER CLOSET (TANK)	5	--
URINAL	5	--
LAVATORY	1.5	1.5
JANITOR'S SINK	3	3
SHOWER/BATHTUB	2	3
DRINKING FOUNTAIN	2	-
KITCHEN SINK	2	2
ICE MAKER / BEVERAGE	1	-


2 WATER HAMMER ARRESTER LOCATION DETAIL

NO SCALE

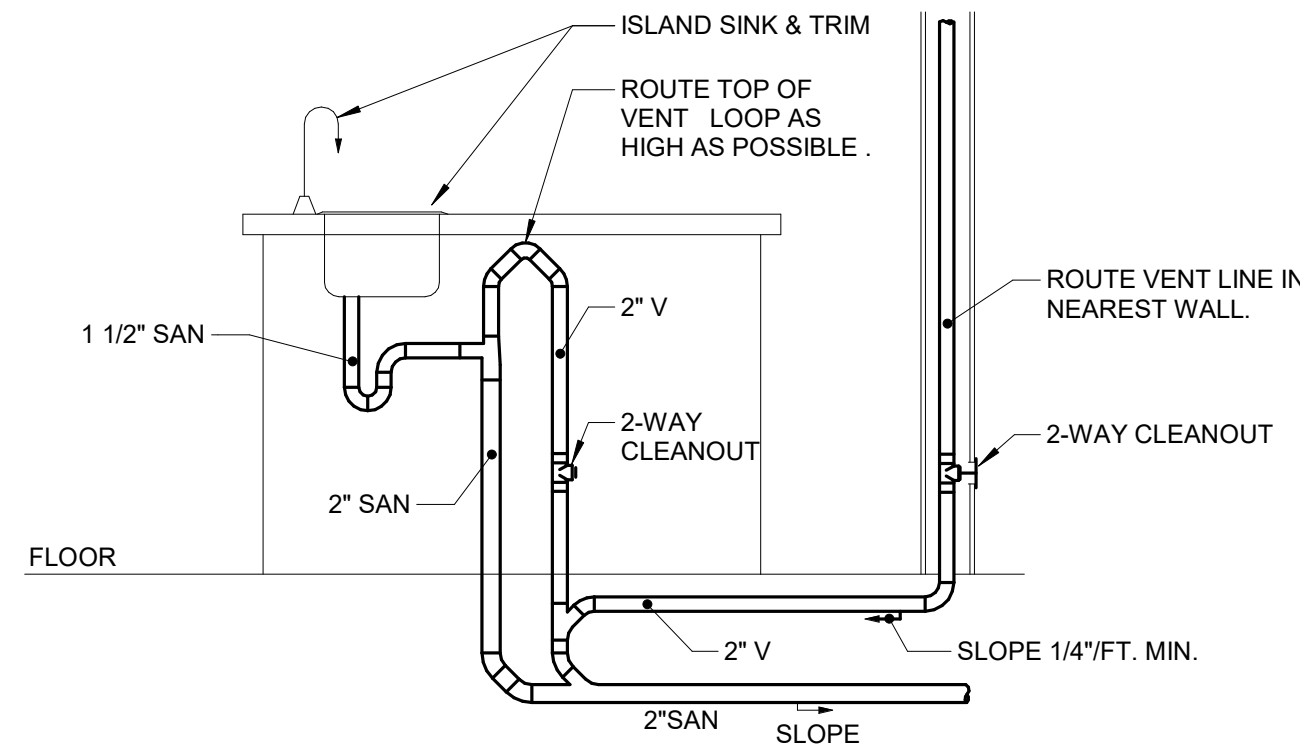


3 ISLAND SINK VENT DETAIL

NO SCALE

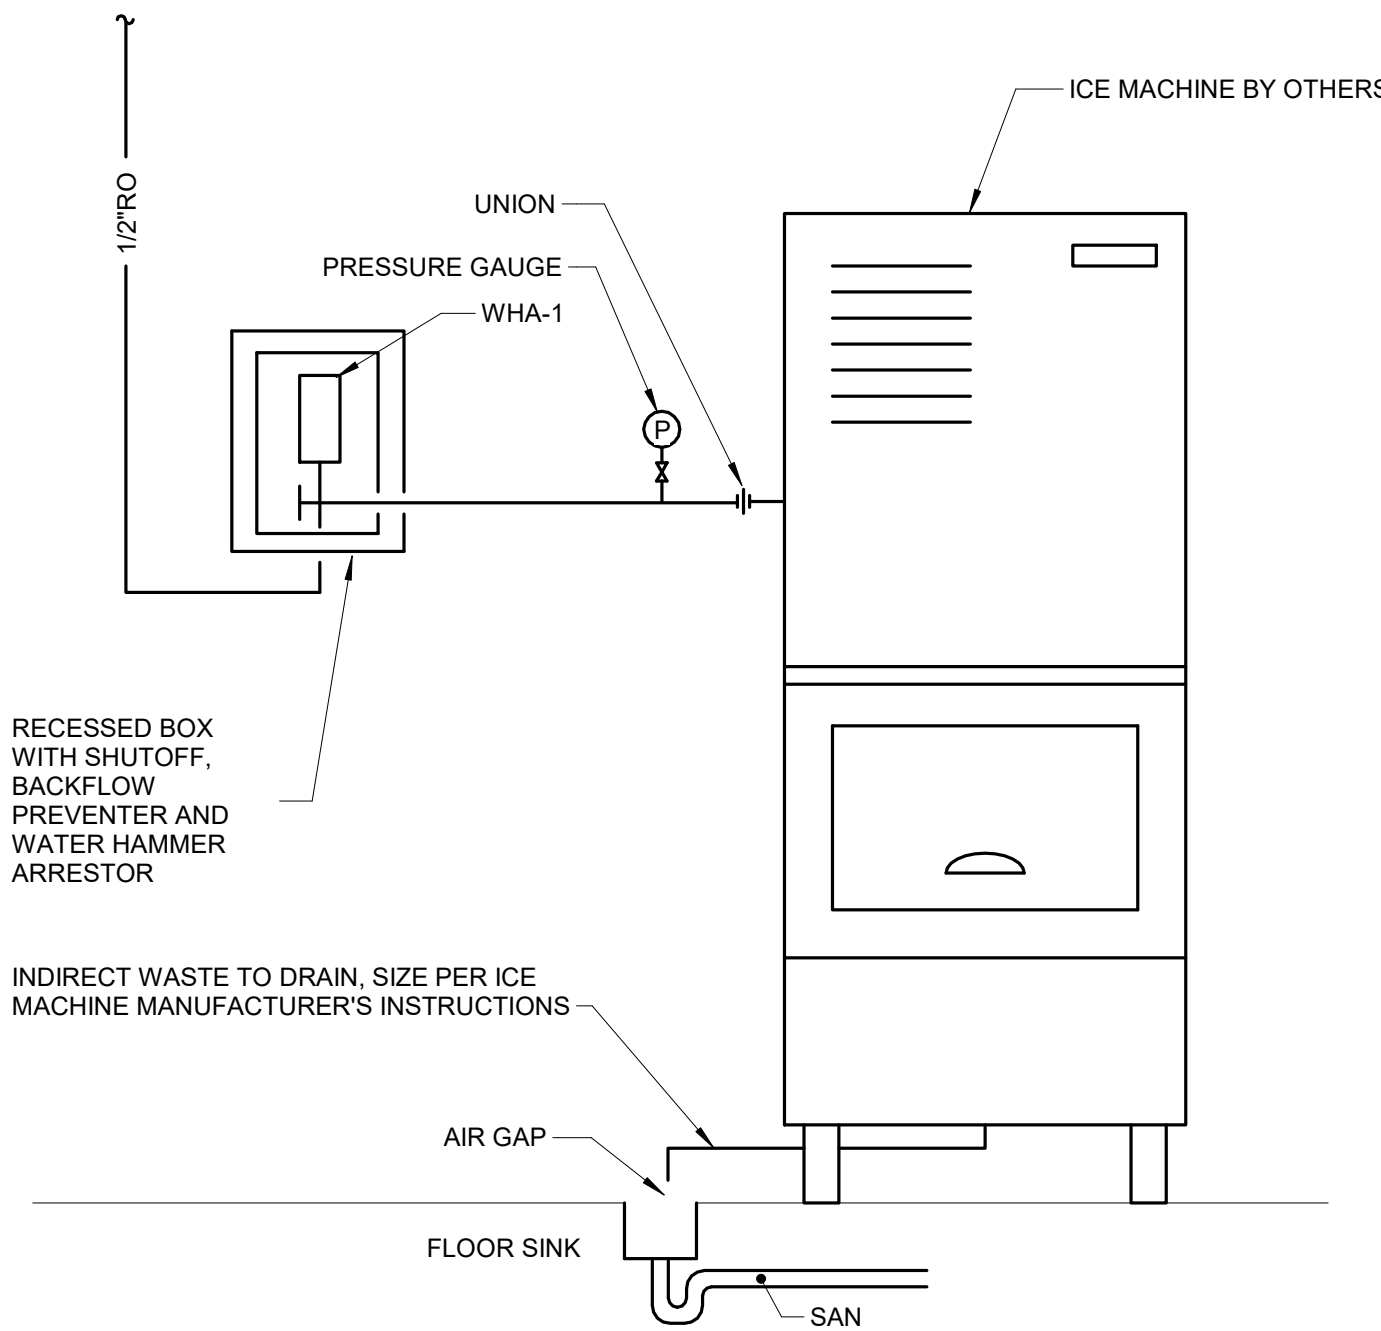

5 ICE MACHINE DETAIL

NO SCALE

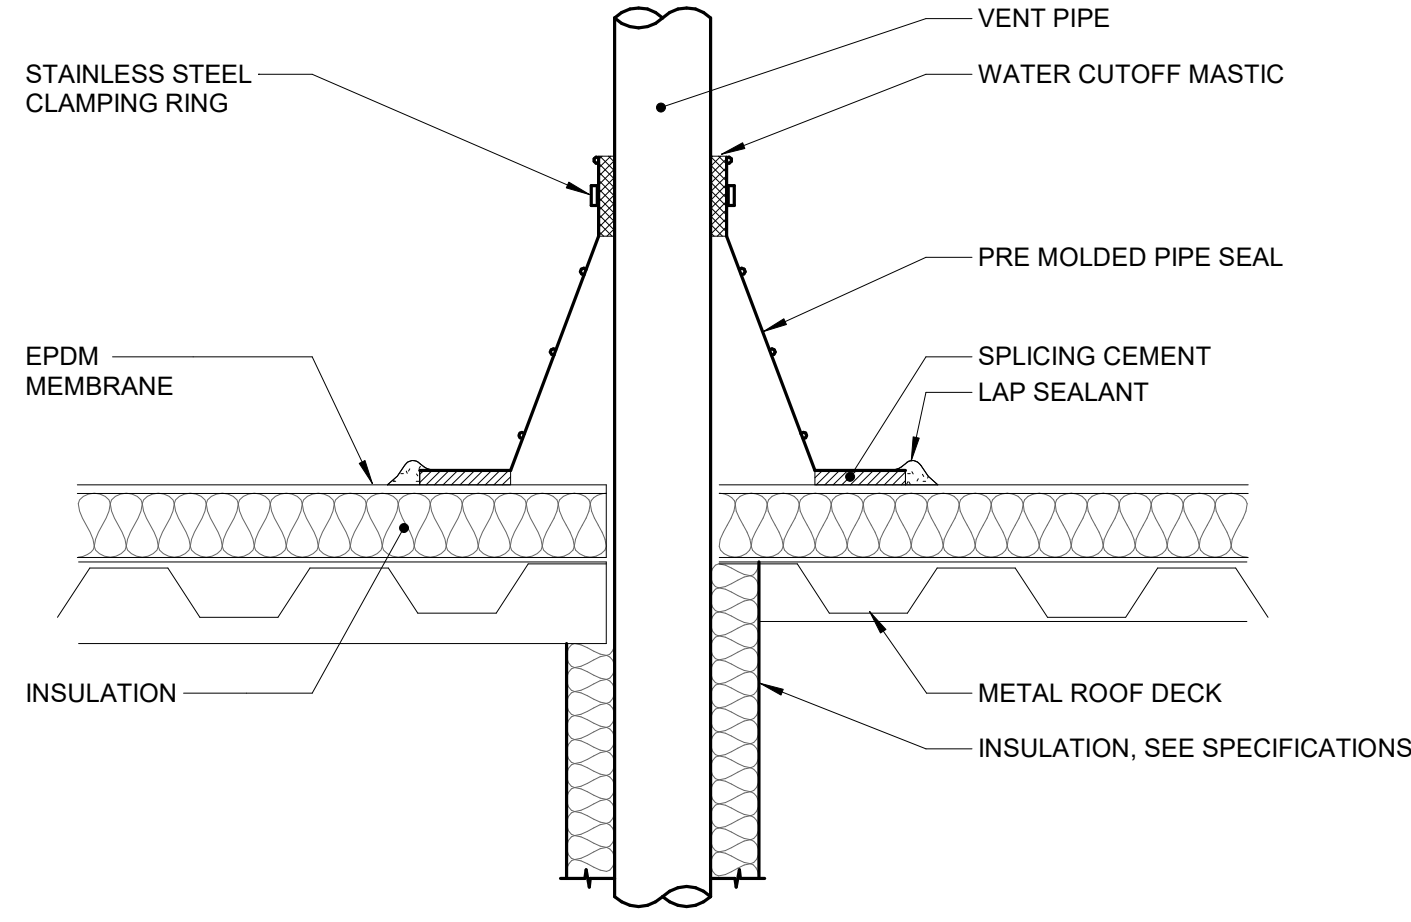

6 VENT PIPE FLASHING

NO SCALE


NOTES:

1. VENT PIPE SHALL BE A MINIMUM OF 3" DIAMETER UNLESS NOTED LARGER ON FLOOR PLANS. INCREASES, IF REQUIRED TO TRANSITION TO THE LARGER VTR SIZE, MUST BE INSTALLED AT LEAST 12 INCHES BELOW THE THERMAL ENVELOPE OF THE BUILDING.

IMEG
www.imegcorp.com
IMEG CORP. RESERVES PROPRIETARY RIGHTS, INCLUDING COPYRIGHTS, TO THIS DRAWING AND THE DATA SHOWN THEREON. SAID DRAWING AND/OR DATA ARE THE EXCLUSIVE PROPERTY OF IMEG CORP. AND SHALL NOT BE USED OR REPRODUCED FOR ANY OTHER PROJECT WITHOUT THE EXPRESS WRITTEN APPROVAL AND PARTICIPATION OF IMEG CORP. ©2024 IMEG CORP.

2882 100TH STREET
DES MOINES, IA 50322
P: 515.334.9000 F: 515.334.9008
PROJECT #21007888.00

0 1 2 3
REF. SCALE IN INCHES

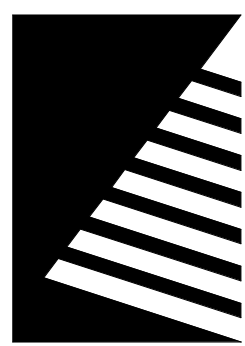

Farnsworth
GROUP

14225 UNIVERSITY AVENUE, SUITE 110
WALKEE, IOWA 50263
(515) 225-3469 / info@f-w.com

www.f-w.com
Engineers | Architects | Surveyors | Scientists

RIPPE ASSOCIATES
FOODSERVICE DESIGN + CONSULTING

kpff

IMEG

Bishop Engineering

ISSUE:
DATE: DESCRIPTION:

BID SET

PROJECT:
STATE OF IOWA - DEPARTMENT
OF CORRECTIONS

**CLARINDA
CORRECTIONAL
FACILITY - KITCHEN &
LAUNDRY ADDITION**

2000 N 16TH ST, CLARINDA, IA
51632

DATE: 02/09/2024

DESIGNED: MIKMCC

DRAWN: MIKMCC

REVIEWED: DELLLE

SHEET TITLE:


PLUMBING DETAILS

SHEET NUMBER:

P4.1

PROJECT NO.: 0240202.00

RF8922300-02

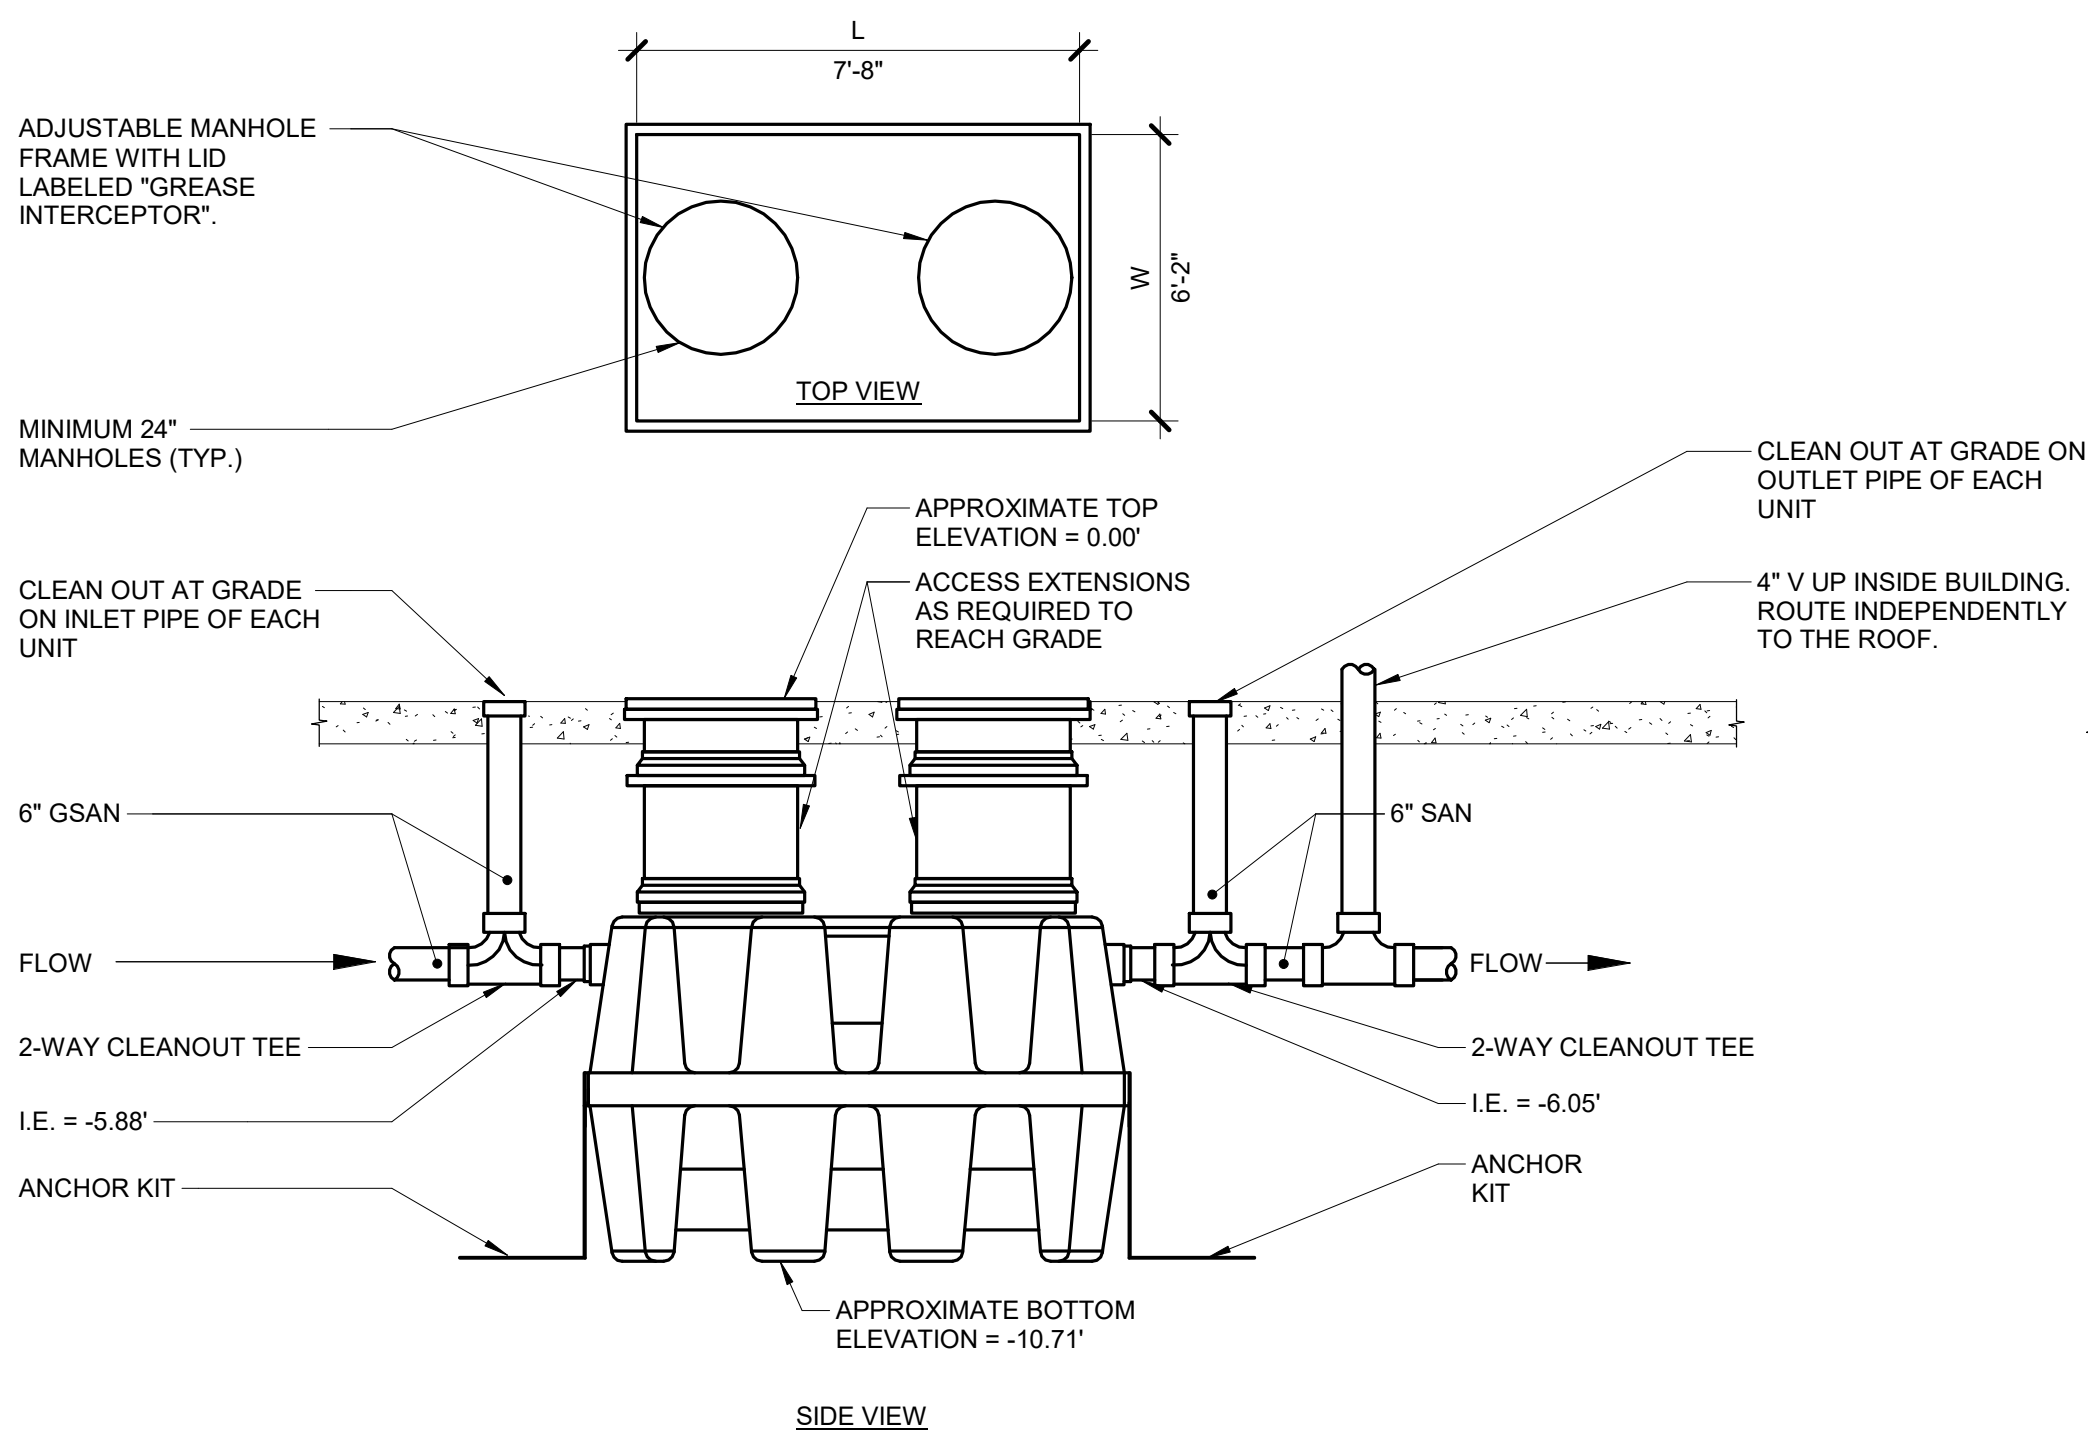


1 GREASE INTERCEPTOR DETAIL (EXTERIOR)

NO SCALE

NOTES:

1. REFER TO MANUFACTURERS RECOMMENDATIONS FOR SPECIFIC VENTING REQUIREMENTS.

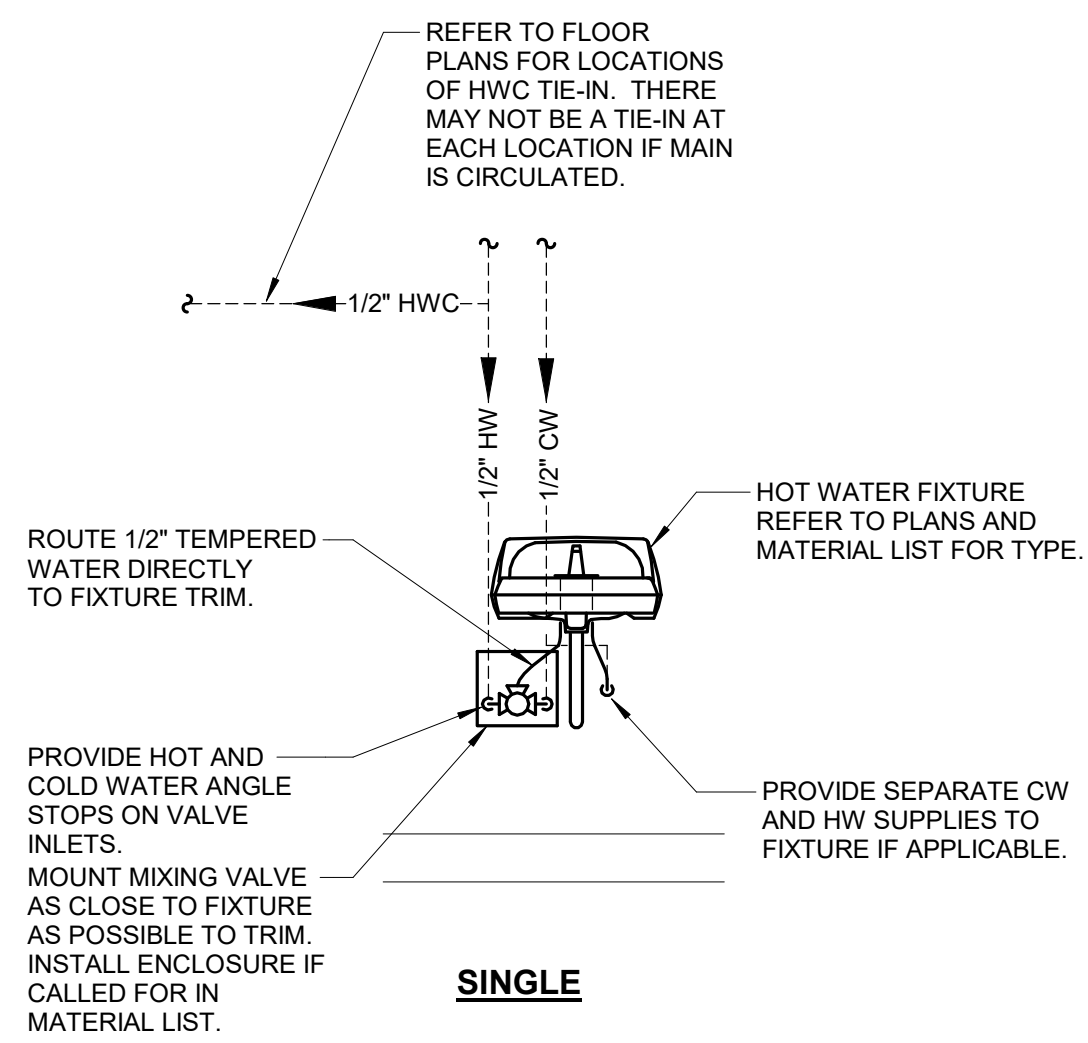


SINGLE

LAVATORY SHOWN; DETAIL IS APPLICABLE TO ALL HW FIXTURES AND DEVICES (E.G. LAVATORIES, SINKS, MOP SINKS, LAUNDRY TUBS, ETC.). REFER TO ROUGH-IN SCHEDULES FOR PIPE SIZES.


4 FIXTURE HOT WATER ROUTING DETAIL

NO SCALE

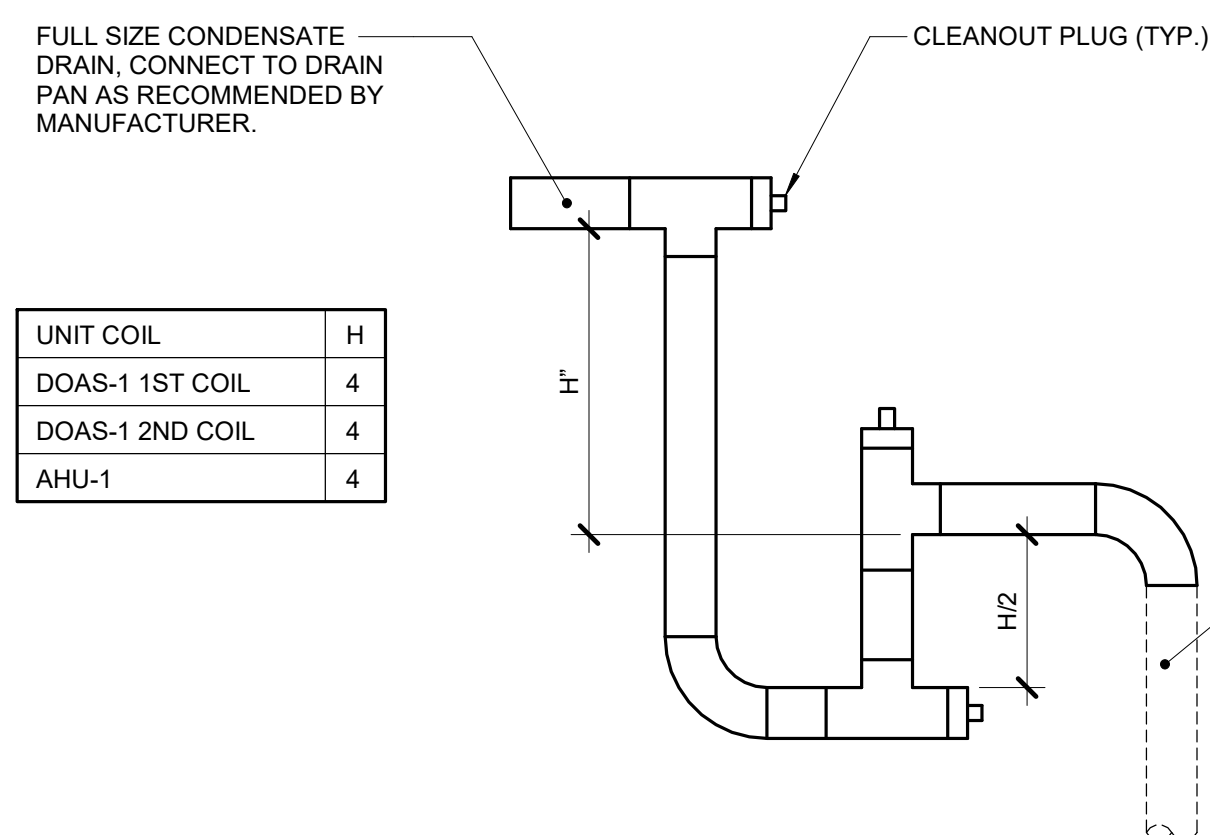

7 CONDENSATE TRAP DETAIL (DRAW-THROUGH)

NO SCALE

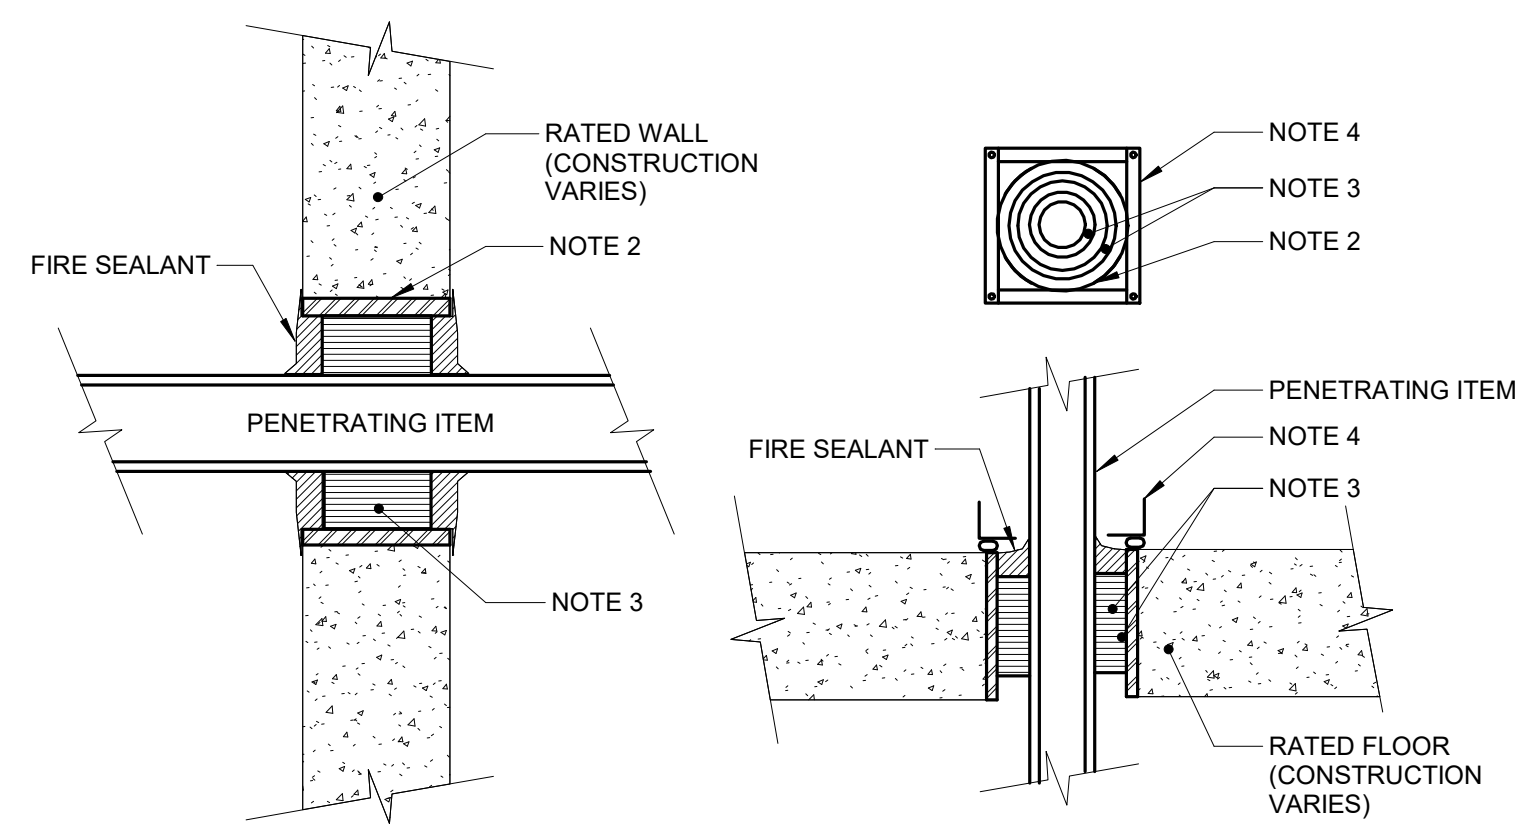


NOTES:

1. THIS GENERAL DETAIL APPLIES TO ALL ITEMS PENETRATING FIRE RATED WALLS OR FLOORS. THE INTENT IS TO MAINTAIN THE FIRE RATING AND TO ALLOW LONGITUDINAL MOVEMENT. REFER TO SPECIFICATION SECTION 07 84 00 FOR SELECTION OF THROUGH PENETRATION FIRE STOPPING.
2. SCHEDULE 5 PIPE SLEEVE EMBEDDED IN WALL OR FLOOR, OR SMOOTH CORE DRILL. EACH CONTRACTOR FURNISHES SLEEVE TO DIVISION 3 CONTRACTOR. COORDINATES SLEEVE LOCATIONS AND DEBURS SLEEVE. DIVISION 3 CONTRACTOR BUILDS SLEEVE INTO WALL OR FLOOR ALLOWING NO GAP AROUND SLEEVE. IF SLEEVE IS NOT PROVIDED WHEN WALL OR FLOOR IS BUILT, CONTRACTOR SHALL INSTALL SLEEVE. SLEEVE SIZE SHALL ALLOW ANNUAL SPACE REQUIRED BY THE SELECTED FIRE STOP SYSTEM.
3. INSTALL BACKING MATERIAL, SUCH AS MINERAL WOOL SAFING, AS REQUIRED FOR FIRE STOP SYSTEM. INSTALL IN ACCORDANCE WITH FIRE STOP SYSTEM APPLICATION LISTING. SECURE TO WALL OR FLOOR TO ALLOW LONGITUDINAL MOVEMENT OF PENETRATING ITEM WITHOUT MOVEMENT OF FIRE BARRIER.
4. WATERTIGHT WELDED 1"x1" 20 GAUGE MINIMUM GALVANIZED SHEET METAL ANGLE FRAME, BY CONTRACTOR IN EQUIPMENT ROOMS FOR WATER STOP. PLACE A BEAD OF WATERPROOF SEALANT BETWEEN FLOOR AND BOTTOM OF ANGLE FRAME. SECURE TO FLOOR WITH MASONRY ANCHORS IN CORNERS AND ON 12" MAXIMUM CENTERS. MULTIPLE PENETRATING ITEMS MAY BE ENCLOSED IN ONE FRAME.

5 FLOOR/WALL PENETRATION - RATED FIRE BARRIER

NO SCALE


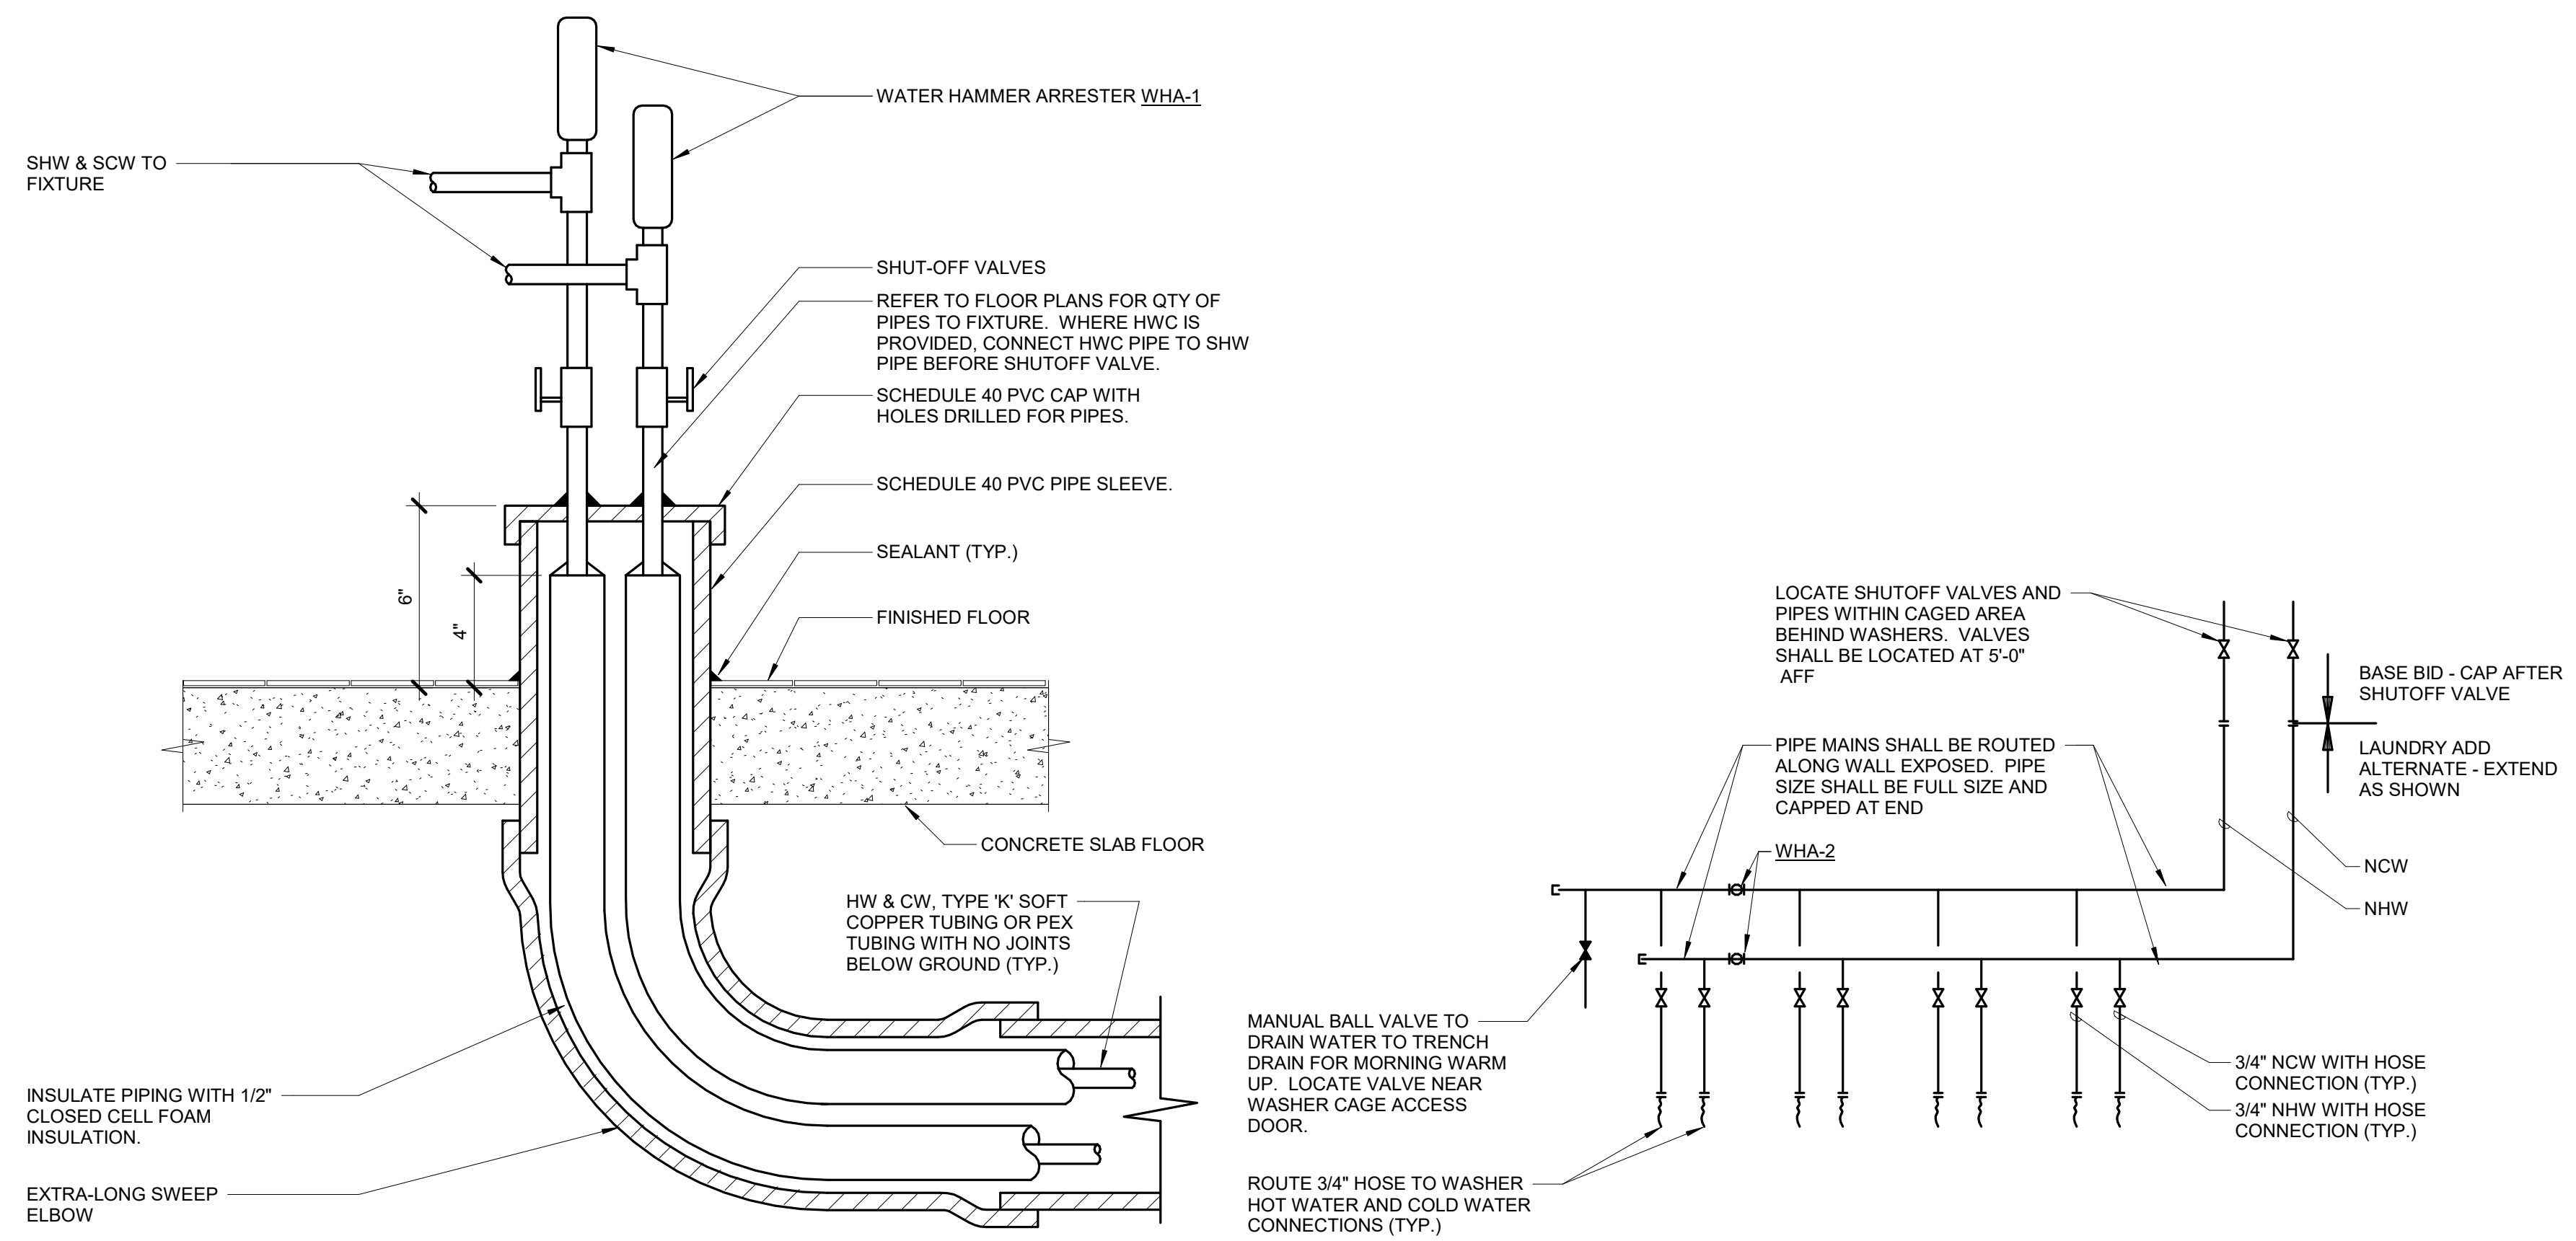


2 UNDERGROUND TUBING TO ISLAND FIXTURES

NO SCALE

3 WASHING MACHINE PIPING DETAIL

NO SCALE

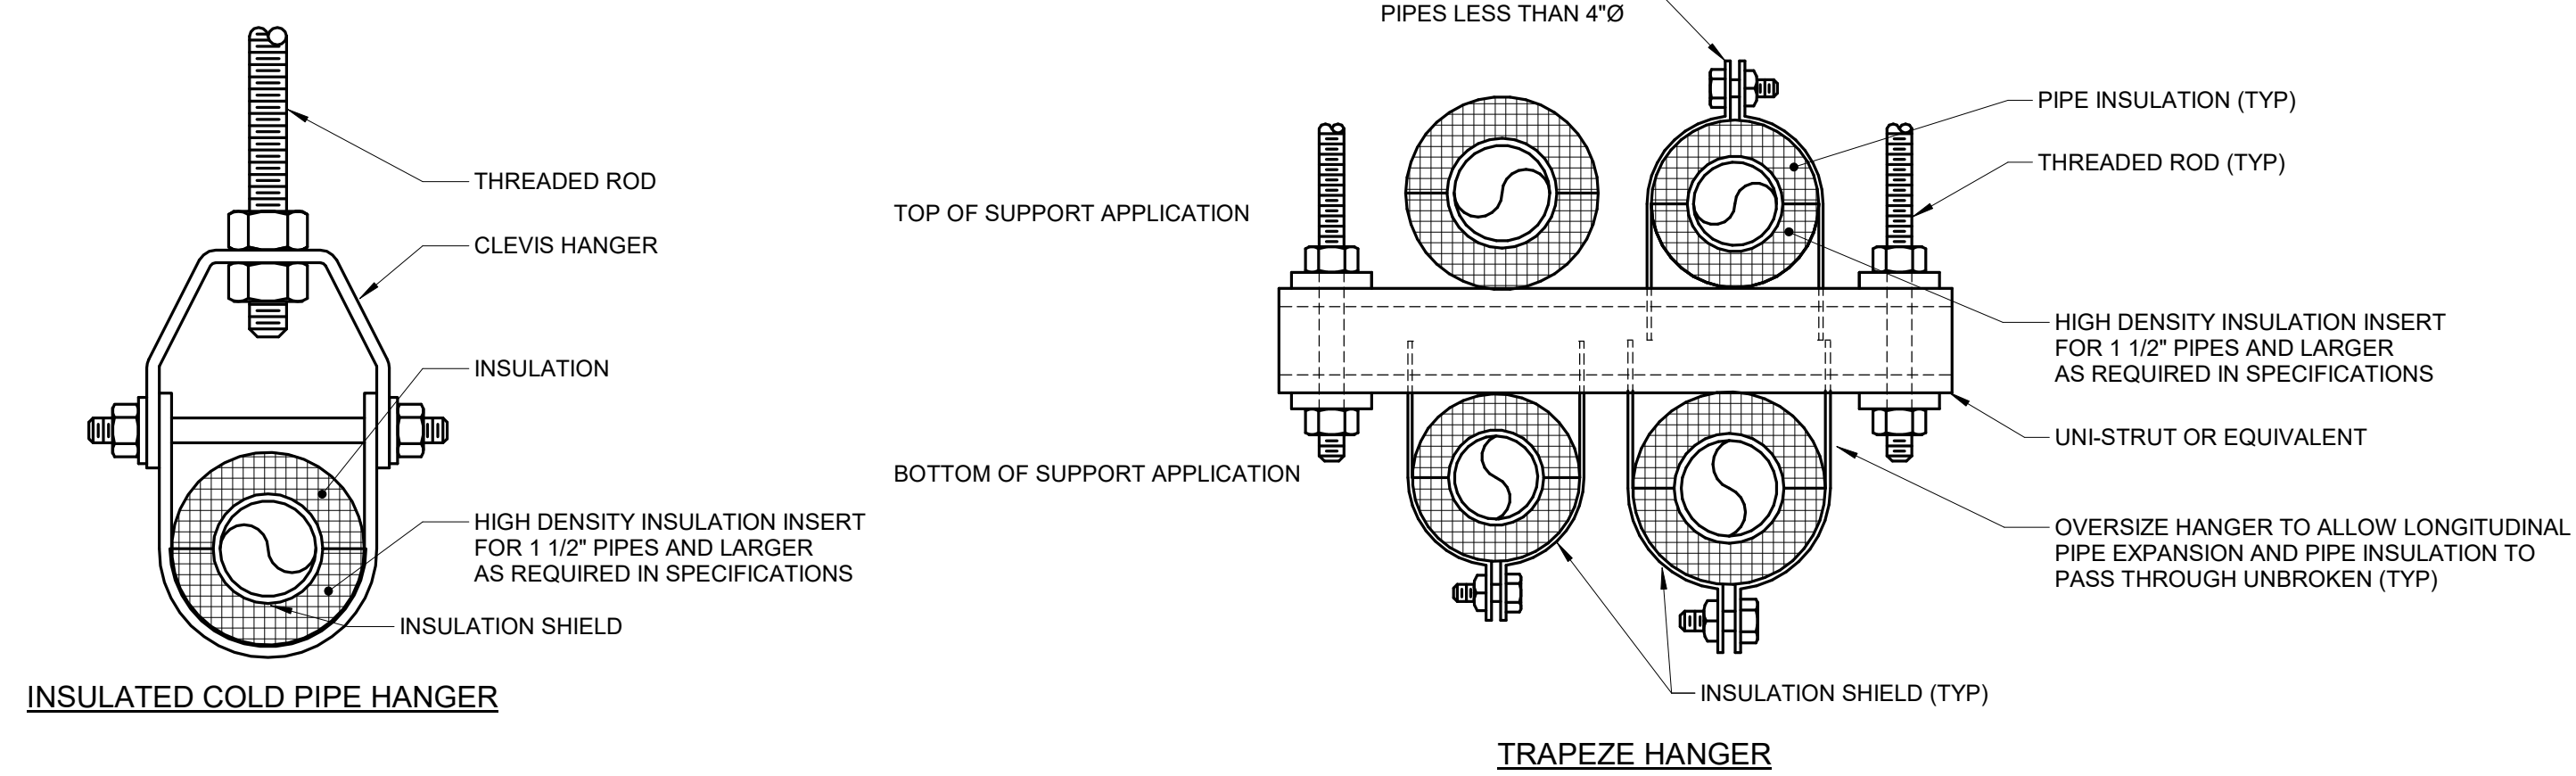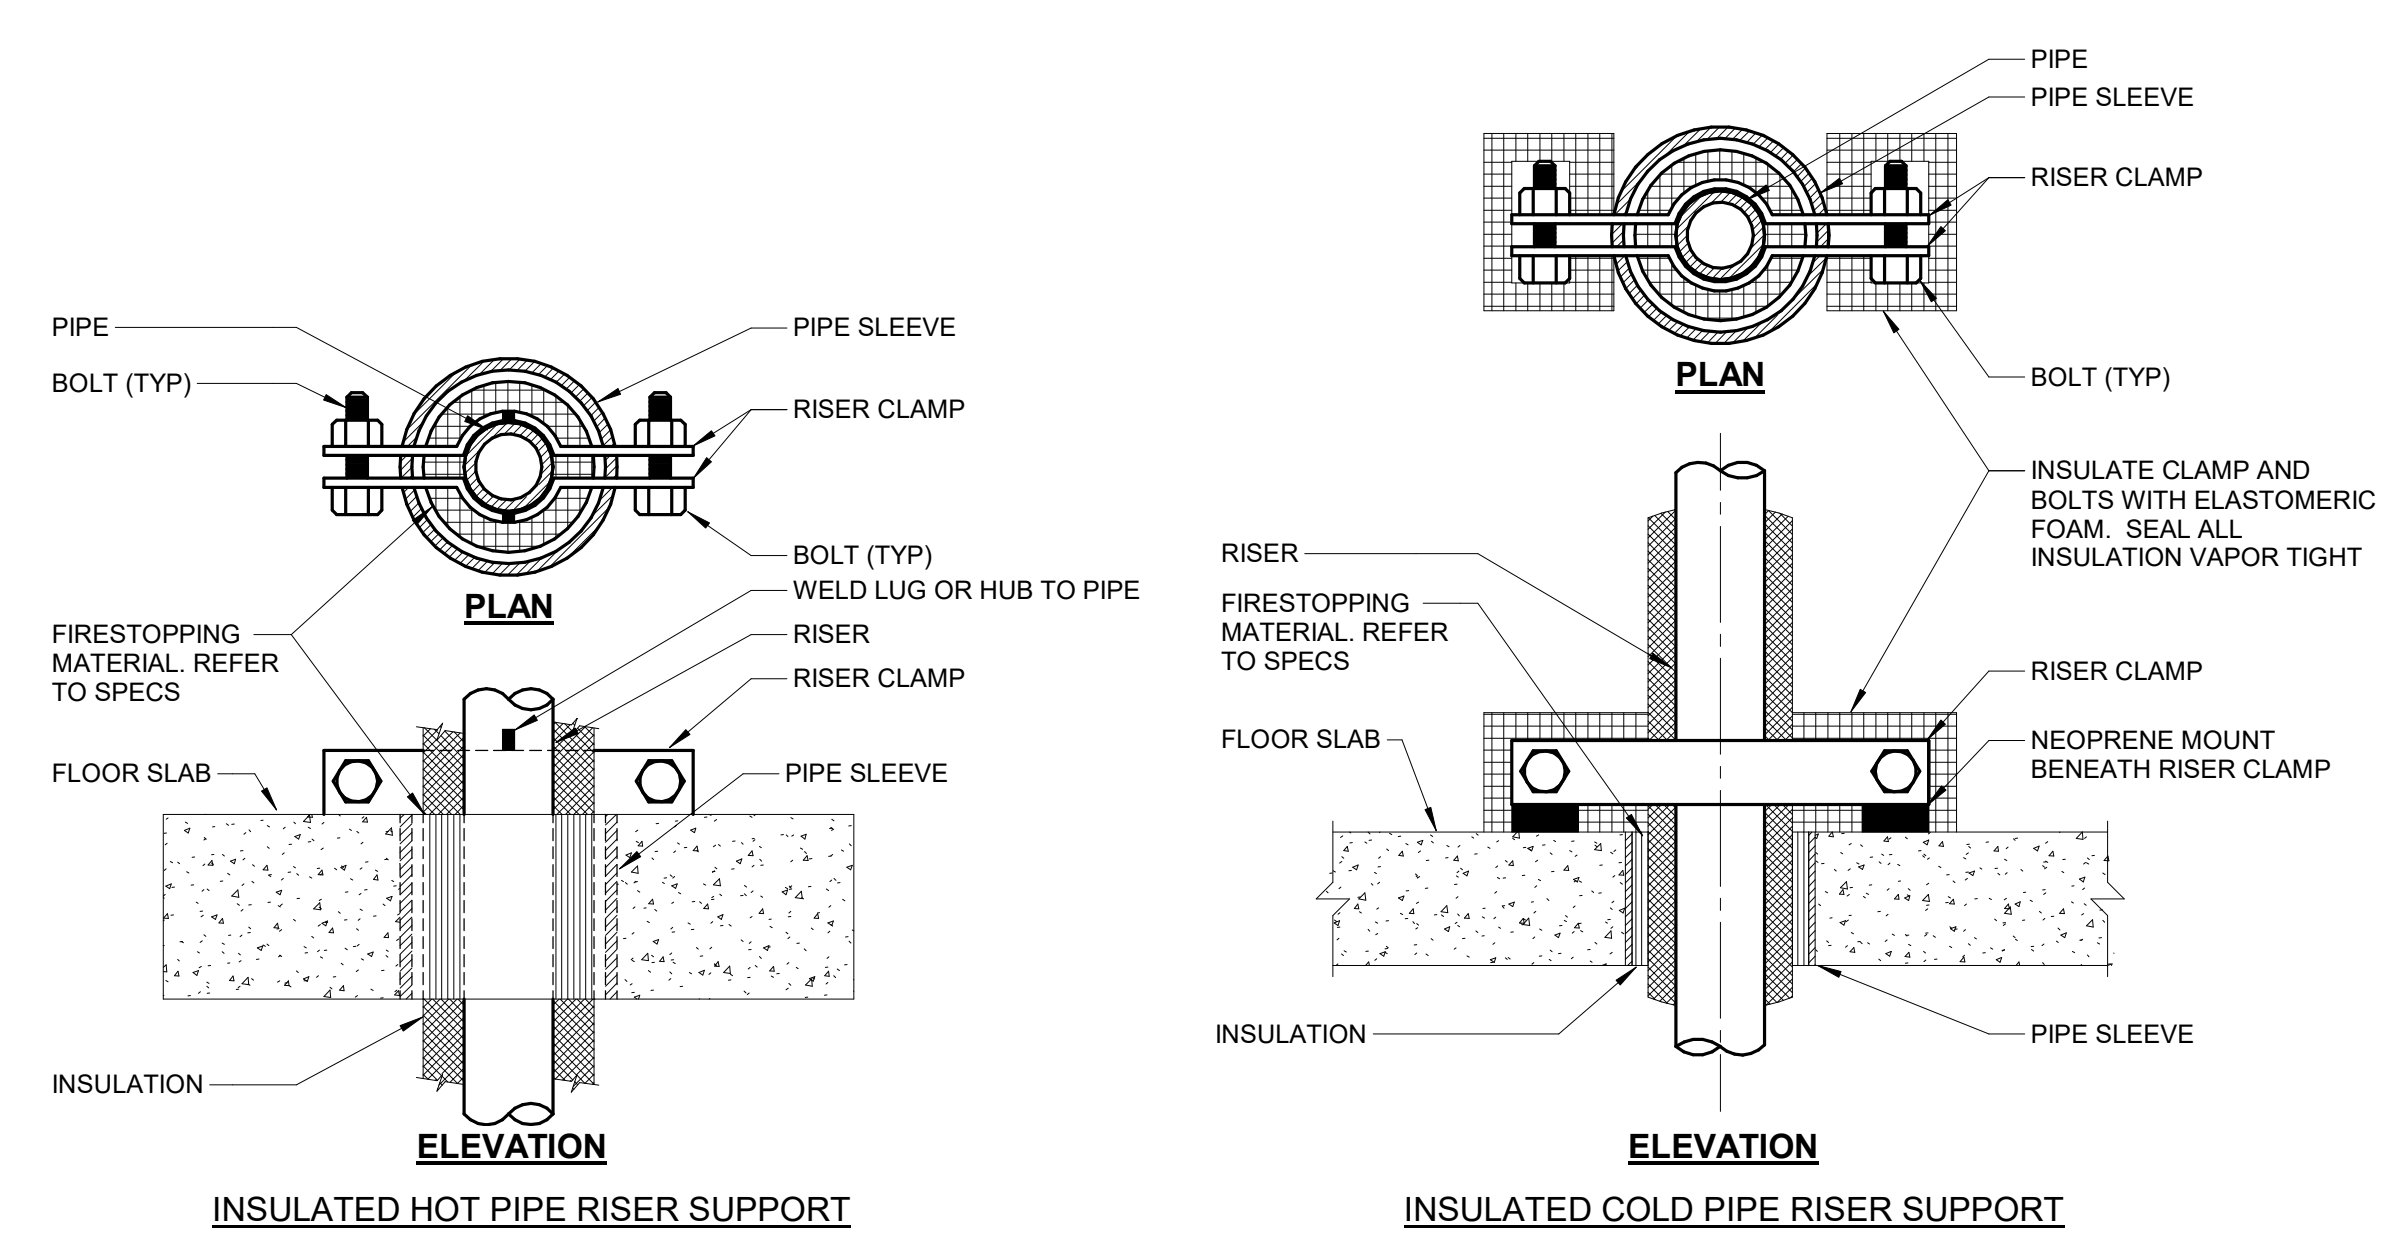

NOTES:

1. REFER TO SPECIFICATION SECTION 22 05 29-PLUMBING.


6 PIPE - HANGERS AND SUPPORTS

NO SCALE

IMEG
www.imegcorp.com
IMEG CORP. RESERVES PROPRIETARY RIGHTS, INCLUDING COPYRIGHTS, TO THIS DRAWING AND THE DATA SHOWN THEREON. SAID DRAWING AND/OR DATA ARE THE EXCLUSIVE PROPERTY OF IMEG CORP. AND SHALL NOT BE USED OR REPRODUCED FOR ANY OTHER PROJECT WITHOUT THE EXPRESS WRITTEN APPROVAL AND PARTICIPATION OF IMEG CORP. ©2004 IMEG CORP.

2882 10TH STREET
DES MOINES, IA 50322
P: 515.334.9000 F: 515.334.9008

REF. SCALE IN INCHES
PROJECT 421007888.00

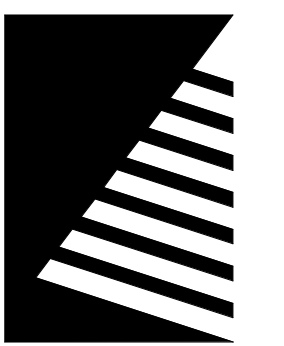

Farnsworth GROUP

14225 UNIVERSITY AVENUE, SUITE 110
WALKEE, IOWA 50263
(515) 225-3469 / info@f-w.com

www.f-w.com
Engineers | Architects | Surveyors | Scientists

RIPPE ASSOCIATES
FOODSERVICE DESIGN + CONSULTING

kpff

IMEG

Bishop Engineering

ISSUE:
DATE: DESCRIPTION:

DATE:

BID SET

PROJECT:
STATE OF IOWA - DEPARTMENT OF CORRECTIONS

CLARINDA CORRECTIONAL FACILITY - KITCHEN & LAUNDRY ADDITION

2000 N 16TH ST, CLARINDA, IA 51632

DATE: 02/09/2024

DESIGNED: MIKMCC

DRAWN: MIKMCC

REVIEWED: DELLLE


SHEET TITLE:

PLUMBING DETAILS

SHEET NUMBER:

P4.2

PROJECT NO.: 0240202.00
RF8922300-02

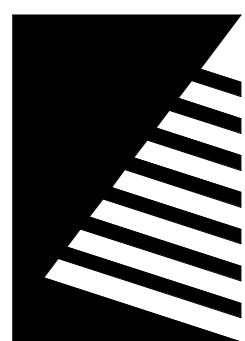

Farnsworth
GROUP

14225 UNIVERSITY AVENUE, SUITE 110
WALKEE, IOWA 50263
(515) 225-3469 / info@f-w.com

www.f-w.com
Engineers | Architects | Surveyors | Scientists

RIPPE ASSOCIATES
FOODSERVICE DESIGN + CONSULTING

kpff

IMEG

Bishop Engineering

ISSUE:
DATE: DESCRIPTION:

BID SET

PROJECT:
STATE OF IOWA - DEPARTMENT
OF CORRECTIONS

**CLARINDA
CORRECTIONAL
FACILITY - KITCHEN &
LAUNDRY ADDITION**

2000 N 16TH ST, CLARINDA, IA
51632


DATE: 02/09/2024
DESIGNED: MIKMCC
DRAWN: MIKMCC
REVIEWED: DELLE

SHEET TITLE:
**PLUMBING
DIAGRAMS**


SHEET NUMBER:

P5.1

PROJECT NO.: 0240202.00
RFB922300-02

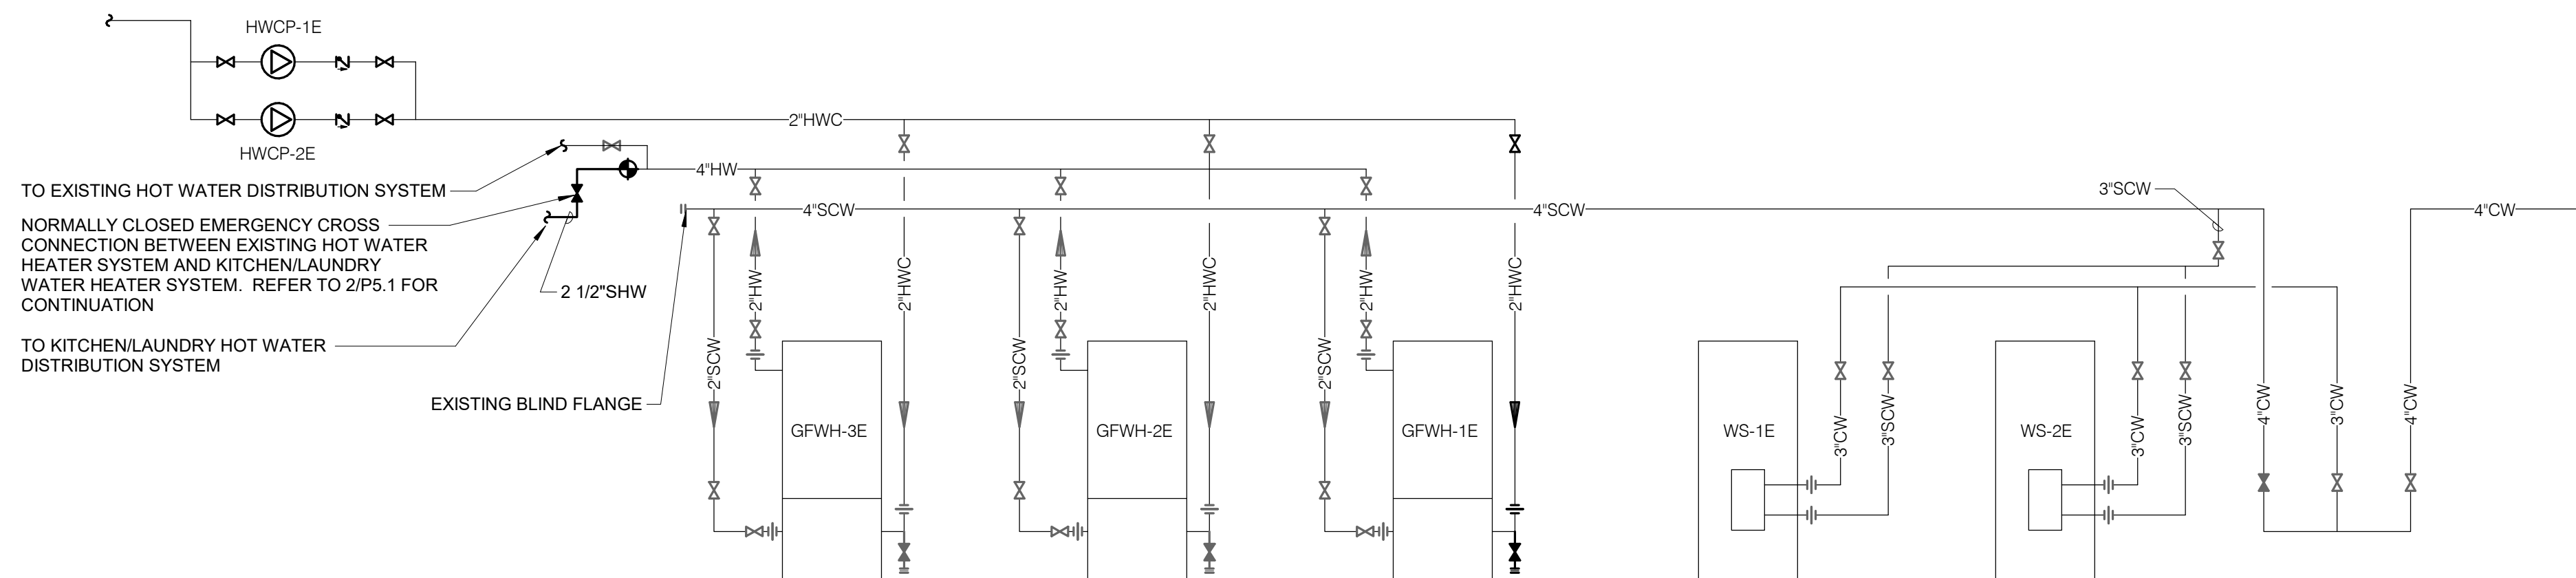

1 EXISTING WATER FLOW DIAGRAM
NO SCALE

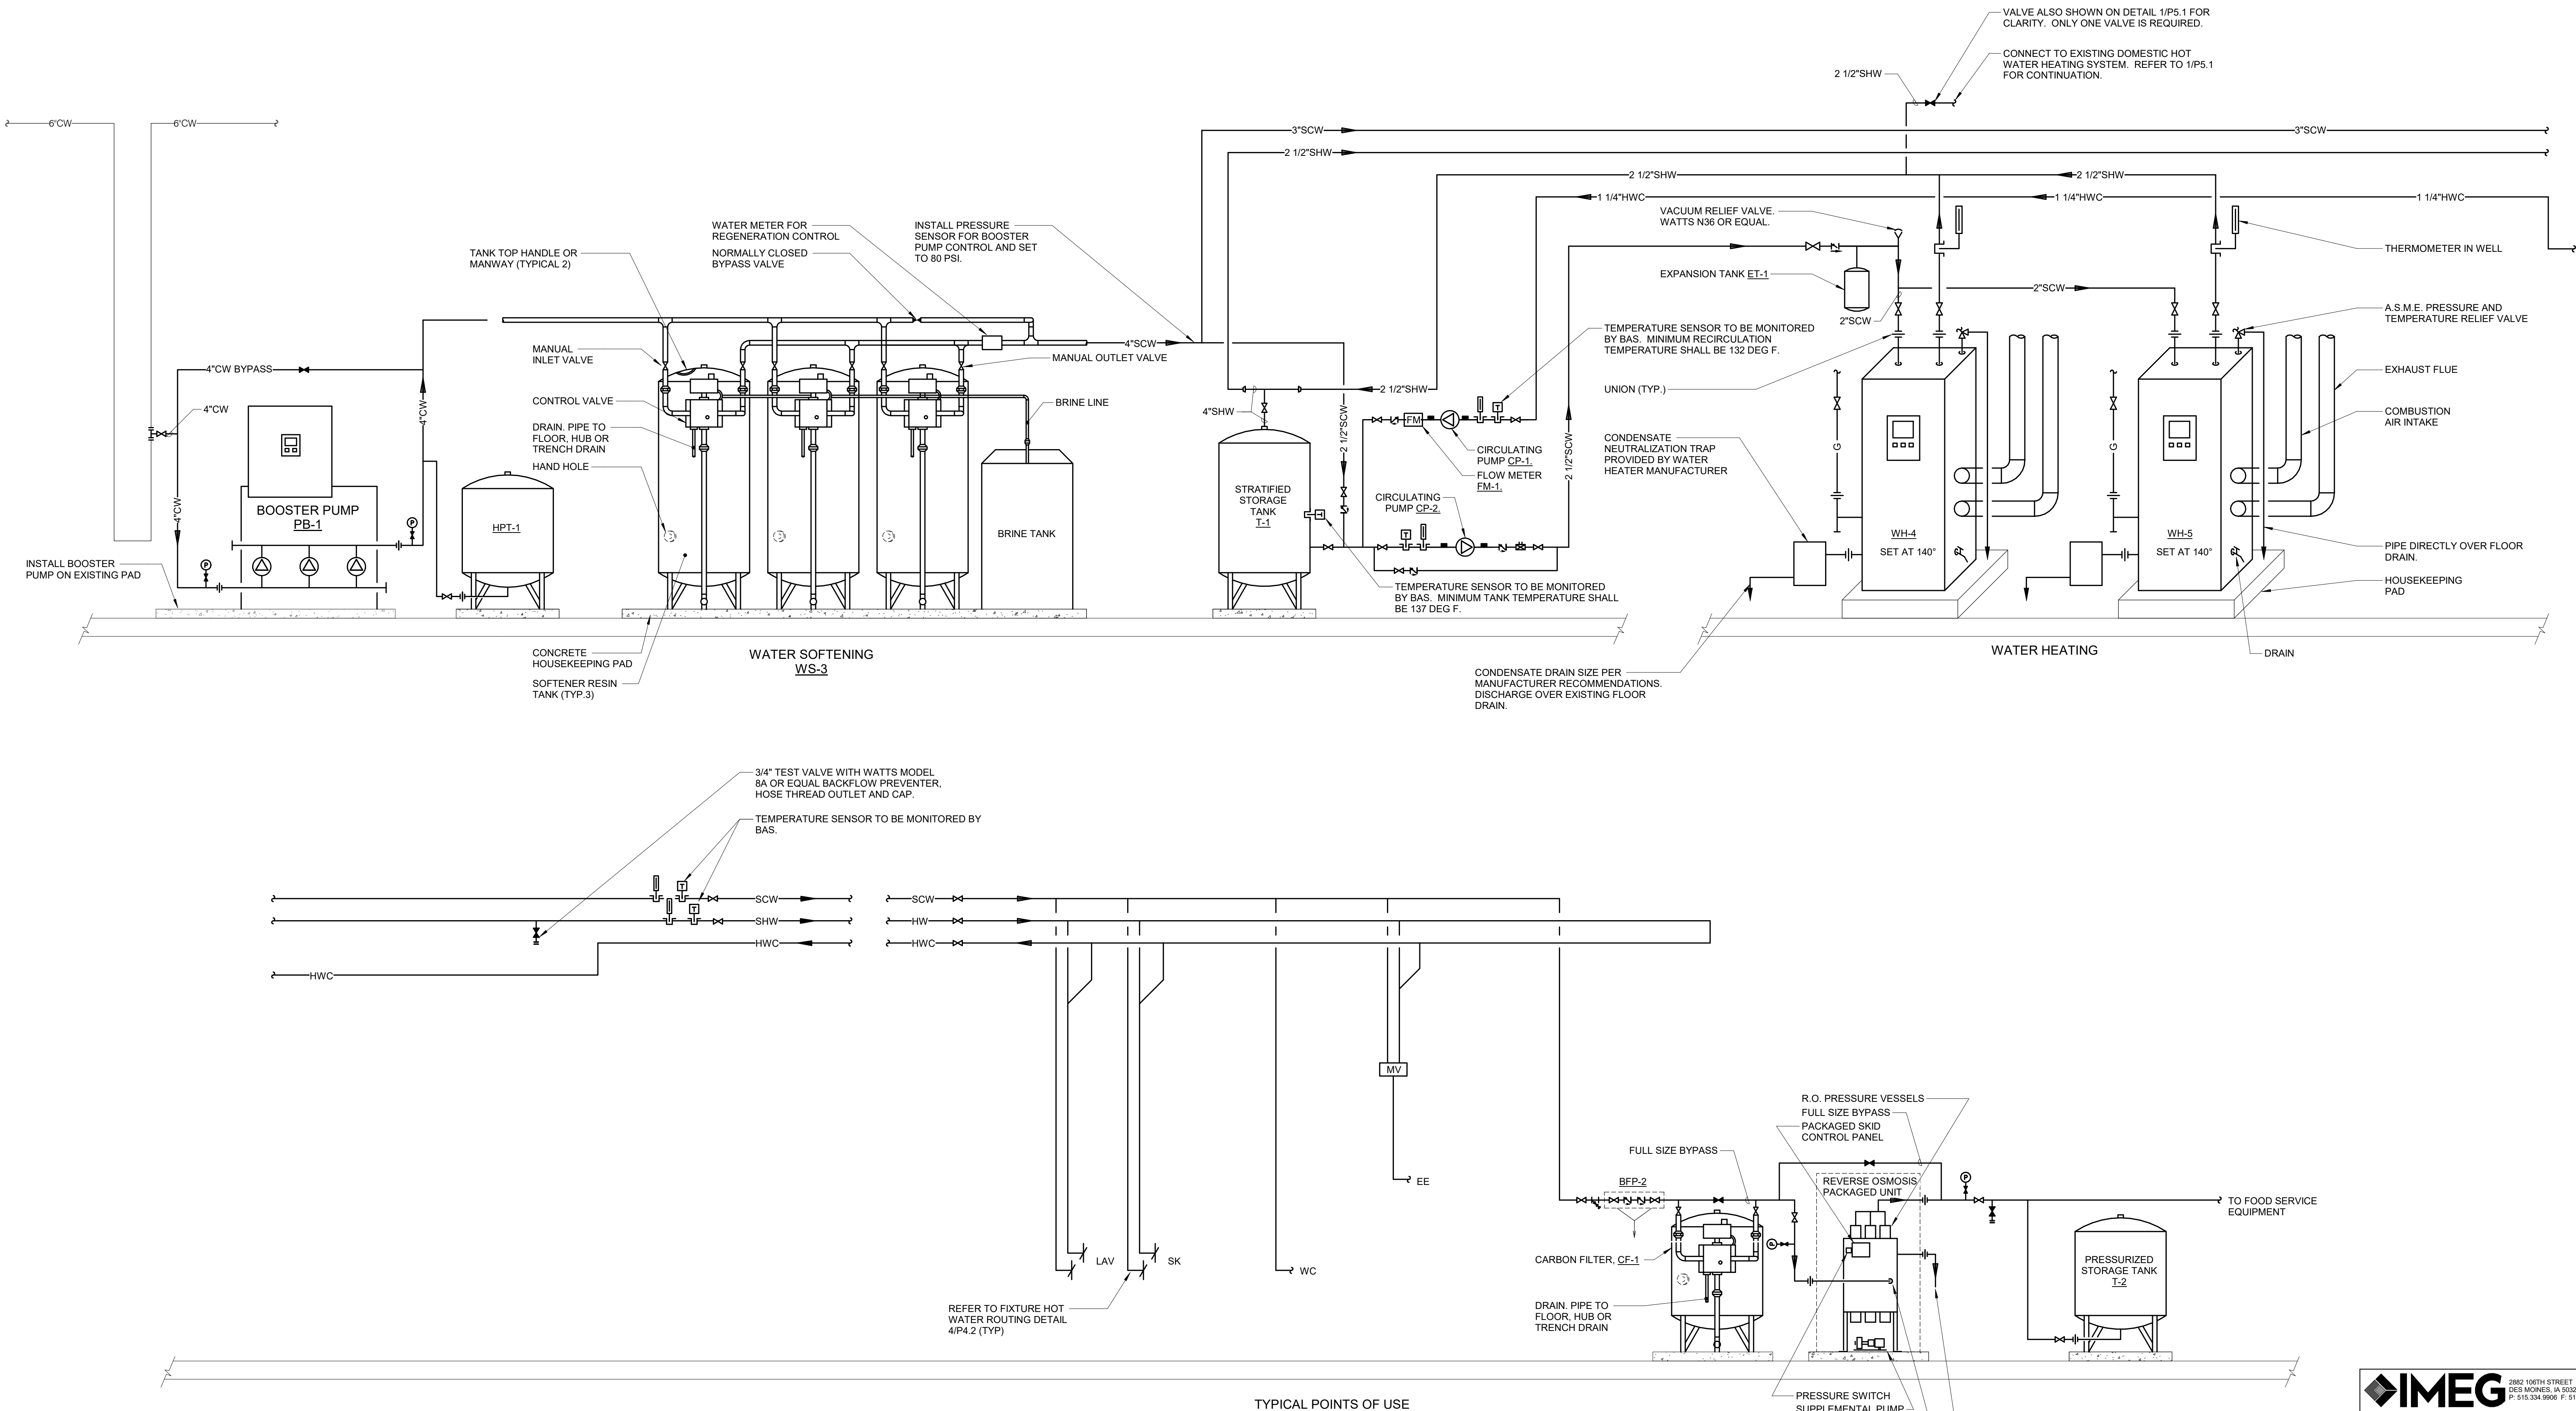


2 DOMESTIC WATER FLOW DIAGRAM
NO SCALE

IMEG
www.imegcorp.com
IMEG CORP. RESERVES PROPRIETARY RIGHTS, INCLUDING COPYRIGHTS, TO THIS DRAWING AND THE DATA SHOWN THEREIN. SAID DRAWING AND/OR DATA ARE THE EXCLUSIVE PROPERTY OF IMEG CORP. AND SHALL NOT BE USED OR REPRODUCED FOR ANY OTHER PROJECT WITHOUT THE EXPRESS WRITTEN APPROVAL AND PARTICIPATION OF IMEG CORP. ©2024 IMEG CORP.

2882 100TH STREET
DES MOINES, IA 50322
P: 515.334.9000 F: 515.334.9008

REF. SCALE IN INCHES PROJECT #21007888.00

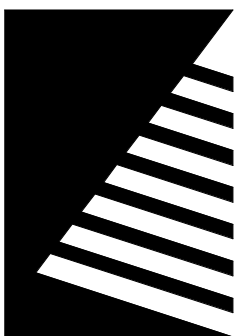

Farnsworth
GROUP

14225 UNIVERSITY AVENUE, SUITE 110
WAUKEGA, IOWA 52053
(515) 225-3469 / info@f-w.com

www.f-w.com

Engineers | Architects | Surveyors | Scientists

RIPE ASSOCIATES
FOODSERVICE DESIGN + CONSULTING

kpf

IMEG

Bishop Engineering

ISSUE:
DATE: DESCRIPTION:

BID SET

PROJECT:
STATE OF IOWA - DEPARTMENT
OF CORRECTIONS

CLARINDA
CORRECTIONAL
FACILITY - KITCHEN &
LAUNDRY ADDITION

2000 N 16TH ST, CLARINDA, IA
51632

DATE: 02/09/2024

DESIGNED: MIKMCC

DRAWN: MIKMCC

REVIEWED: DELLLE

SHEET TITLE:

PLUMBING
SCHEDULES

SHEET NUMBER:

P6.2

PROJECT NO.: 0240202.00

RFB922300-02

PLUMBING MATERIAL LIST CONTINUED

TAG NAME	DESCRIPTION	MANUFACTURER AND MODEL
SK-1	SINK - ACCESSIBLE, SELF-RIMMING SINGLE COMPARTMENT WITH FAUCET DECK [AND OVERFLOW], 18 GAUGE TYPE 304 STAINLESS STEEL, 31" (SIDE-TO-SIDE) X 21" (FRONT-TO-BACK) OVERALL SIZE, 28" x 16" x 8 3/8" DEEP BOWL, COMPLETELY UNDERCOATED, 3-1/2" DIAMETER DRAIN OUTLET LOCATION OFF-CENTERED REAR IN BOWL, PERFORATED TYPE 304 STAINLESS STEEL GRID STRAINER. SINK TRIM - SINGLE HANDLE MIXING FAUCET, BRASS CONSTRUCTION, CHROME-PLATED FINISH, CONVENTIONAL SWING SPOUT, NOMINAL 8" REACH, AERATOR, LEVER HANDLE, SUPPLIES AT 8" CENTERS. MAXIMUM FLOW TO BE 2.2 GPM IN COMPLIANCE WITH ENERGY POLICY ACT OF 2005 AND ASME/ANSI STANDARD A112.18.1M. FAUCET SHALL COMPLY WITH FEDERAL ACT 53874. PROVIDE RESTRICTIVE DEVICE AND ESCUTCHEON PLATE AS REQUIRED. ACCESSORIES - OFFSET 1-1/2" 17 GAUGE CHROME-PLATED BRASS TAILPIECE AND P-TRAP, QUARTER-TURN BALL VALVE TYPE 3/8" CHROME-PLATED BRASS ANGLE SUPPLIES WITH LOOSE KEY STOPS, CHROME-PLATED SOFT COPPER SUPPLY LINES. INSULATION KIT - PRE-MANUFACTURED FOR P-TRAP, STOP VALVES, AND SUPPLY LINES.	SINK - ELKAY (LRAD), JUST (SL-ADA/J-ADA-35), FRANK (ALBS) SINK TRIM - DELTA (100LF-HDF), AMERICAN STANDARD (4175-500), CHICAGO FAUCET (431-ABC), ELKAY (LK1000CR), KOHLER (K-15171), MOEN (57425), SPECKMANN (S-3702), SYMMONS (S-23) INSULATION KIT - MCGUIRE (PROWRAP), JUST (J-ADA), PLUMBEREX (PRO-EXTREME), TRUEBRO (LAV-GUARD2)
T-1	STORAGE TANK - VERTICAL CEMENT-LINED, HEAVY GAUGE STEEL JACKET, BAKED ENAMEL FINISH, 250 GALLON CAPACITY, 30" DIAMETER x 87" HIGH, MAGNESIUM ANODE ROD(S), FIBERGLASS OR FOAM INSULATION TO MEET LATEST ASHRAE/IES 90.1B STANDARD, 4" INLET/OUTLET, DRAIN AND RELIEF VALVE OPENINGS, ASME T&P RELIEF VALVE, 4"x7" HANDHOLES ON TANKS UP TO 30" IN DIAMETER, 11"x15" MANWAY ON TANKS 30" IN DIAMETER AND LARGER, STRUCTURAL SUPPORTS AS REQUIRED FOR INSTALLATION, 125 PSIG WORKING PRESSURE, ASME STAMPED, 5-YEAR WARRANTY.	A.O. SMITH (HD SERIES), BOCK (ST SERIES), AJAX BOILER (ACE SERIES), STATE (PVG SERIES), LOCHINVAR (RORC SERIES), GEMLINE (JST SERIES), RECO USA
T-2	RO PRESSURIZED STORAGE TANK - VERTICAL, COPOLYMER POLYPROPYLENE TANK REINFORCED WITH FIBERGLASS AND WITH SEALED EXPOXY RESIN, WATER CHAMBER WITH 100% BUTYL RUBBER DIAPHRAGM WITH COPOLYMER POLYPROPYLENE LOWER CHAMBER, 125 PSI MAX WORKING PRESSURE, 120°F MAXIMUM WORKING TEMPERATURE, PRE-CHARGED TO 20 PSI (ADJ.), 120 GALLONS WITH 79.6 GALLONS OF DRAWDOWN WITH 10 PSI PRE-CHARGE AND 80 PSI SUPPLY.	FLEXWAVE (FWRO 120) OR ENGINEER PREAPPROVED EQUAL
TD-1	TRENCH DRAIN - PRE-MANUFACTURED POLYSTYRENE TRENCH FORMING SYSTEM, 12" WIDE, 8 FOOT SECTIONS PRE-SLOPED AT 1/8" PER FOOT, ROUNDED BOTTOM, INTEGRAL DEFORMING GROVES, STEEL SUPPORT RAILS AND ANCHORING STUDS, HEAVY DUTY CAST IRON GRATE, H-20 RATED, INTEGRAL CATCH BASIN. TRENCH DRAIN SHALL BE 9'-0" LONG WITH CENTER CATCH BASIN AND 6" BOTTOM OUTLET. DEPTH AT SHALLOW END SHALL BE OF TRENCH SHALL BE 12"	ABT (TF-14) OR APPROVED EQUAL
TD-2	TRENCH DRAIN - PRE-MANUFACTURED POLYSTYRENE TRENCH FORMING SYSTEM, 12" WIDE, 8 FOOT SECTIONS PRE-SLOPED AT 1/8" PER FOOT, ROUNDED BOTTOM, INTEGRAL DEFORMING GROVES, STEEL SUPPORT RAILS AND ANCHORING STUDS, HEAVY DUTY CAST IRON GRATE, H-20 RATED, INTEGRAL CATCH BASIN. TRENCH DRAIN SHALL BE 21'-0" LONG WITH CENTER CATCH BASIN AND 6" BOTTOM OUTLET. DEPTH AT SHALLOW END SHALL BE OF TRENCH SHALL BE 12"	ABT (TF-14) OR APPROVED EQUAL
WC-1	WATER CLOSET - ACCESSIBLE, WALL MOUNTED, FLUSH VALVE TYPE, WHITE VITREOUS CHINA, SIPHON JET, WATER SAVING, ELONGATED BOWL, 1-1/2" TOP SPUD. FLUSH VALVE - EXPOSED, WALL MOUNTED SENSOR OPERATION, HARD WIRED, 1.6 GALLONS PER FLUSH, 11-1/2" ROUGH-IN, CHROME PLATED, 1" I.P.S. SCREWDRIVER STOP-CHECK VALVE WITH VANDAL RESISTANT CAP, HIGH BACK PRESSURE VACUUM BREAKER, ADJUSTABLE TAILPIECE, SPUD COUPLING AND FLANGE, WALL FLANGE WITH SET SCREW, MECHANICAL OVER-RIDE BUTTON, CHLORAMINE RESISTANT MATERIALS, CHROME PLATED COVER PLATE WITH TAMPER-PROOF SCREWS, TRANSFORMER AND LOW VOLTAGE WIRING, ADA COMPLIANT, 3 YEAR WARRANTY. ELECTRICAL REQUIREMENTS - 120VAC INPUT SEAT - WHITE, EXTRA HEAVY, OPEN FRONT, INJECTION MOLDED SOLID ANTI-MICROBIAL PLASTIC, SELF-SUSTAINING HINGE, STAINLESS STEEL OR PLATED STEEL POSTS AND NUTS. CONTRACTOR OPTION: COMBINATION WATER CLOSET/FLUSH VALVE PACKAGED SYSTEM BY AMERICAN STANDARD, KOHLER, SLOAN, OR ZURN ACCESSORIES - WATER CLOSET SUPPORT CARRIER RATED FOR 500 LBS. MOUNT WATER CLOSET WITH CARRIER BOLTED SECURELY TO FLOOR. TOP OF SEAT SHALL BE AT 17"-19" ABOVE FINISHED FLOOR (VERIFY EXACT MOUNTING HEIGHT WITH MANUFACTURER). VERIFY EQUIPMENT REQUIREMENTS AND ROUGH-IN LOCATIONS.	WATER CLOSET - AMERICAN STANDARD (2257-101), GERBER (25-030), KOHLER (K-84325), SLOAN (ST-2053), TOTO (C1708), ZURN (25510) FLUSH VALVE - ZURN (ZEM5800AV), SLOAN (111 ES-S), AMERICAN STANDARD (6067-161), DELANY (1302), HYDROTER (H-8000C), MOEN (8310AC16), AMTC (AEF-801-HWCIT-16) SEAT - BEIMS (3155SSCT), CHURCH (3155C), BENEKE (633PC), OLSONITE (95), SAME AS WATER CLOSET MANUFACTURER
WC-2	WATER CLOSET - ACCESSIBLE, OFF FLOOR, WALL MOUNTED, WALL OUTLET, WALL SUPPLY, 14 GAUGE STAINLESS STEEL, SEAMLESS WELDED CONSTRUCTION, SATIN FINISHED EXPOSED SURFACES, BLOWOUT TYPE, ELONGATED BOWL WITH SELF-DRAINING FLUSHING RIM, INTEGRAL CONTOURED SEAT. INSTALLED ON FINISHED WALL FROM THE FRONT. WALL CONCEALED SUPPLY WITH 1.6 GPF FLUSH. ACCESSORIES - WATER CLOSET SUPPORT CARRIER RATED FOR 500 LBS. FLUSH VALVE - CONCEALED IN ACCESS PANEL SENSOR OPERATION, HARD WIRED, 1.6 GALLONS PER FLUSH, 11-1/2" ROUGH-IN, CHROME PLATED, 1" I.P.S. SCREWDRIVER STOP-CHECK VALVE WITH VANDAL RESISTANT CAP, HIGH BACK PRESSURE VACUUM BREAKER, ADJUSTABLE TAILPIECE, SPUD COUPLING AND FLANGE, WALL FLANGE WITH SET SCREW, MECHANICAL OVER-RIDE BUTTON, CHLORAMINE RESISTANT MATERIALS, CHROME PLATED COVER PLATE WITH TAMPER-PROOF SCREWS, TRANSFORMER AND LOW VOLTAGE WIRING, ADA COMPLIANT, 3 YEAR WARRANTY. ACCESS PANEL SHALL BE 14 GAUGE STAINLESS STEEL WITH SATIN FINISH, 18 GAUGE STAINLESS STEEL RECESSED WALL BOX WITH VANDAL RESISTANT SCREWS. ELECTRICAL REQUIREMENTS - 120VAC INPUT	WATER CLOSET - ACORN 2100-W-1-1.6GPF-FVBO-ADA, WILLOUGHBY, METCRAFT FLUSH VALVE - ZURN (ZEM5800AV), SLOAN (111 ES-S), AMERICAN STANDARD (6067-161), DELANY (1302), HYDROTER (H-8000C), MOEN (8310AC16), AMTC (AEF-801-HWCIT-16)
WC-1	WALL CLEANOUT - END CAP, CAST IRON ACCESS BODY, GAS AND WATERTIGHT BRONZE OR BRASS THREADED PLUG, ROUND STAINLESS STEEL ACCESS COVER, EXTENDED MACHINE SCREW.	ZURN (Z-1441), SMITH (4422), WADE (W-8480-R/8550), JOSAM (58600-CO), WATTS (CO-380-RD), MIFAB (C1450-RD)
WH-4	WATER HEATER - GAS FIRED, CONDENSING, VERTICAL, MINIMUM 92% EFFICIENT, SEALED COMBUSTION, MINIMUM 10-1 MODULATING HEAT OUTPUT, METAL CABINET, BAKED ENAMEL FINISH, 160 PSI WORKING PRESSURE, FIBERGLASS OR FOAM INSULATION, BRASS WATER CONNECTIONS AND DRAIN VALVE, ASME APPROVED T&P RELIEF VALVE, AUTOMATIC WATER THERMOSTAT, BUILT-IN GAS REGULATING VALVE, ADJUSTABLE TEMPERATURE RANGE, 5-YEAR WARRANTY, UL LISTED, COMPLIANT TO NAECA, ASHRAE 90.1 AND ASHRAE 90A. 1572 GPH AT 100°F TEMPERATURE RISE HEATING CAPACITY, 19 GALLON STORAGE CAPACITY, 1,350,000 BTUH INPUT NATURAL GAS. ELECTRICAL REQUIREMENTS - 120V CIRCUIT, 20 AMPS, FOR BLOWER, CIRCULATING PUMP AND CONTROLS, HARD-WIRED. THIS EQUIPMENT REQUIRES EMERGENCY POWER. SET WATER TEMPERATURE AT 140°F. SET SUPPLY GAS PRESSURE AT 10" W.C. PROVIDE INTEGRATED WATER HEATER MANAGEMENT SYSTEM TO CONTROL SEQUENCING OF BOTH WATER HEATERS. PROVIDE SEQUENCING VALVES. CONDENSATE DRAIN NEUTRALIZATION TANK - RATED FOR MAXIMUM 6,000 MBH WATER HEATER AND 45 GPH CONDENSATE FLOW, POLYPROPYLENE RECTANGULAR TANK, 1"FNPT INLET AND OUTLET, REMOVABLE ACCESS COVER FOR CLEANING AND PELLET REPLACEMENT, 25 LBS PH NEUTRALIZING PELLETS. REFER TO FLOOR PLANS FOR EXISTING ELEVATOR DOOR SIZE AND CAB SIZE. MAXIMUM WATER HEATER DIMENSIONS SHALL ALLOW FOR INSTALLATION BY MOVING THROUGH BUILDING AND EXISTING ELEVATOR TO SECOND FLOOR MECHANICAL ROOM. INCLUDE COMPLETE GAS TRAIN INCLUDING GAS SAFETY SHUTOFF VALVE CONFORMING TO CSD-1 REQUIREMENTS. VENT ALL GAS VALVES TO OUTDOORS SEPERATELY.	AERCO (INN 1350N), INTELLIHOT (IQ1501), LOCHINVAR (AWH1500NPM) NEUTRALIZATION TANK - JIM BOILER WORKS (NB-6), NUTRASAFE (CN6T)

PLUMBING MATERIAL LIST CONTINUED

TAG NAME	DESCRIPTION	MANUFACTURER AND MODEL
WH-5	WATER HEATER - GAS FIRED, CONDENSING, VERTICAL, MINIMUM 92% EFFICIENT, SEALED COMBUSTION, MINIMUM 10-1 MODULATING HEAT OUTPUT, METAL CABINET, BAKED ENAMEL FINISH, 160 PSI WORKING PRESSURE, FIBERGLASS OR FOAM INSULATION, BRASS WATER CONNECTIONS AND DRAIN VALVE, ASME APPROVED T&P RELIEF VALVE, AUTOMATIC WATER THERMOSTAT, BUILT-IN GAS REGULATING VALVE, ADJUSTABLE TEMPERATURE RANGE, 5-YEAR WARRANTY, UL LISTED, COMPLIANT TO NAECA, ASHRAE 90.1 AND ASHRAE 90A. 1572 GPH AT 100°F TEMPERATURE RISE HEATING CAPACITY, 19 GALLON STORAGE CAPACITY, 1,350,000 BTUH INPUT NATURAL GAS. ELECTRICAL REQUIREMENTS - 120V CIRCUIT, 20 AMPS, FOR BLOWER, CIRCULATING PUMP AND CONTROLS, HARD-WIRED. THIS EQUIPMENT REQUIRES EMERGENCY POWER. SET WATER TEMPERATURE AT 140°F. SET SUPPLY GAS PRESSURE AT 10" W.C. PROVIDE INTEGRATED WATER HEATER MANAGEMENT SYSTEM TO CONTROL SEQUENCING OF BOTH WATER HEATERS. PROVIDE SEQUENCING VALVES. CONDENSATE DRAIN NEUTRALIZATION TANK - RATED FOR MAXIMUM 6,000 MBH WATER HEATER AND 45 GPH CONDENSATE FLOW, POLYPROPYLENE RECTANGULAR TANK, 1"FNPT INLET AND OUTLET, REMOVABLE ACCESS COVER FOR CLEANING AND PELLET REPLACEMENT, 25 LBS PH NEUTRALIZING PELLETS. REFER TO FLOOR PLANS FOR EXISTING ELEVATOR DOOR SIZE AND CAB SIZE. MAXIMUM WATER HEATER DIMENSIONS SHALL ALLOW FOR INSTALLATION BY MOVING THROUGH BUILDING AND EXISTING ELEVATOR TO SECOND FLOOR MECHANICAL ROOM. INCLUDE COMPLETE GAS TRAIN INCLUDING GAS SAFETY SHUTOFF VALVE CONFORMING TO CSD-1 REQUIREMENTS. VENT ALL GAS VALVES TO OUTDOORS SEPERATELY.	AERCO (INN 1350N), INTELLIHOT (IQ1501), LOCHINVAR (AWH1500NPM) NEUTRALIZATION TANK - JIM BOILER WORKS (NB-6), NUTRASAFE (CN6T)
WH-1	WATER HAMMER ARRESTOR - BELLOWS TYPE, PRE-CHARGED, ALL LEAD FREE STAINLESS STEEL CONSTRUCTION, ASSE 1010 APPROVED, PDI CERTIFIED, RATED FOR (1-11)12-30(13-40)B1-113(114-154)155-300 FXTURE UNITS. REFER TO DETAIL 2/P4.1 FOR WATER HAMMER ARRESTOR LOCATION AND SIZING INFORMATION. INSTALL PER MANUFACTURER'S RECOMMENDATIONS.	ZURN (Z1700), JR SMITH (5005-5050), WADE (W5-100), JOSAM (75000 SERIES), WATTS (SS), MIFAB (WHB)
WH-2	WATER HAMMER ARRESTOR - BELLOWS TYPE, PRE-CHARGED, ALL LEAD FREE STAINLESS STEEL CONSTRUCTION, ASSE 1010 APPROVED, PDI CERTIFIED, RATED FOR 155-300 FXTURE UNITS. INSTALL PER MANUFACTURER'S RECOMMENDATIONS.	ZURN (Z1700), JR SMITH (5005-5050), WADE (W5-100), JOSAM (75000 SERIES), WATTS (SS), MIFAB (WHB)
WMF-1	WASHING MACHINE FIXTURE - STAINLESS STEEL ENCLOSURE, 2" CENTER DRAIN, INLET STRAINER, SCREEN OR SEDIMENT BASKET, TWO INDEXED 1/2" DOMESTIC VALVES WITH THREADED OUTLETS, INTEGRAL WATER HAMMER ARRESTORS.	GUY GRAY (SSWB3 SERIES)
WS-3	WATER SOFTENER - TRIPLEX SOFTENER TANKS, AUTOMATIC REGENERATION TYPE BASED ON MULTIPLE TANK PROGRESSIVE CONTROL SYSTEM, BRINE REGULATION SYSTEM, POWER SUPPLY WITH CORD AND PLUG. SYSTEM DESIGN FLOW OF 150 GPM. EACH UNIT SHALL HAVE: CONTINUOUS FLOW RATE OF 152 GPM AT 15 PSI LOSS MAXIMUM FLOW RATE OF 210 GPM AT 25 PSI LOSS DESIGN FLOW RATE OF 50 GPM AT 142 PSI LOSS MINIMUM FLOW RATE OF 10 GPM TO AVOID CHANNELING MINIMUM CAPACITY OF 200,000 GRAINS PER TANK SALT DOSAGE OF 10 LBS PER CUBIC FOOT OF RESIN SOFTENER TANK SIZE: 30"x60" (QTY. 3) BRINE TANK SIZE: 30"x50" (QTY. 1) ELECTRICAL REQUIREMENTS - PROVIDE ONE 120V-1 PHASE RECEPTABLE PER CONTROL VALVE. THIS EQUIPMENT REQUIRES EMERGENCY POWER. REFER TO SPECIFICATIONS FOR ADDITIONAL REQUIREMENTS.	REFER TO SPECIFICATIONS BASIS OF DESIGN: CULLIGAN CSM-300-3

PRESSURE BOOSTER SYSTEM SCHEDULE

NOTES:
1. PROVIDE SHAFT GROUNDINGS AS REQUIRED IN THE MOTOR SPECIFICATION 22 05 13.
2. HP NOTED IS FOR EACH PUMP. SKID HAS A TOTAL OF THREE PUMPS.
3. GPM LISTED IS TOTAL DESIGN FLOW. FLOW OF EACH PUMP SHALL BE 50 GPM.
4. COORDINATE WIDTH OF BOOSTER PACKAGE TO ALLOW FOR MOVEMENT THROUGH BUILDING THROUGH 36" WIDE DOORS. PIPE MANIFOLD MAY NEED TO BE REMOVED WHILE BRING INTO BUILDING.

TAG NAME	AREA SERVED	CONFIGURATION	INLET PRESSURE PSI	OUTLET PRESSURE PSI	GPM (NOTE 3)	MINIMUM HYDRO/PNEUMATIC TANK SIZE	HP (NOTE 2)	RPM	VOLTAGE	PHASES	ELECTRICAL (NOTE 1)		SCCR (AMPS)	THIS REQUIRES EMERGENCY POWER	MANUFACTURER	MODEL	NOTES
											DISCONNECT	CONTROLLER/ STARTER BY (NOTE A)					
PB-1	KITCHEN/LAUNDRY	TRIPLEX	50	90	150	132	3	1800	480	3	BY (NOTE A) MFR.	TYPE (NOTE B) NF	5000	Yes	BELL & GOSSET	V3VFD6F80B1CK	NOTE 4

PIPE INSULATION SCHEDULE (PLUMBING)

GENERAL NOTES:
1. REFER TO THE SPECIFICATIONS FOR TYPE DESCRIPTIONS AND JACKETING REQUIREMENTS. VALUES LISTED BELOW ARE BASED ON ASHRAE / IECC REQUIREMENTS.
2. TYPE A INSULATION IS NOT ALLOWED IN NON-AIR CONDITIONED SPACES, SUCH AS MECHANICAL ROOMS, EXTERIOR ATTICS, ETC.
3. TYPE B INSULATION GREATER THAN 1" THICK SHALL BE INSTALLED USING MULTIPLE LAYERS OF 3/4" OR 1" WITH STAGGERED SEAMS.
4. TYPE E IS NOT ALLOWED IN RETURN AIR PLENUMS, UNLESS LISTED AND LABELED AS 25/50 RATED PER ASTM E84UL723
5. PROVIDE RIGID INSERT AT HANGERS, EITHER PRE-MANUFACTURED COUPLINGS (REFER TO PIPE HANGER AND SUPPORTS SPECIFICATIONS) OR TYPE C, D, OR E INSULATION. SEE SPEC. FOR MORE DETAILS.

PIPE SYSTEM	INSULATION TYPE AND THICKNESS PER NOMINAL PIPE OR TUBE SIZE				INSULATION TYPE AND THICKNESS PER NOMINAL PIPE OR TUBE SIZE (DIRECT BURIED)			NOTES
	< 1"	1" TO <1.5"	1.5" TO <4"	4" TO <8"	< 1"	1" TO <1.5"	1.5" TO <4"	
CW - COLD WATER - POTABLE	A 0.5", B 0.5", E 0.5"	A 0.5", B 0.5", E 0.5"	A 1", B 1", E 1"	A 1", B 1", E 1"				
D - DRAIN - PLUMBING	A 0.5", B 0.5", E 0.5"	A 0.5", B 0.5", E 0.5"	A 1", B 1", E 1"	A 1", B 1", E 1"				APPLY INSULATION ONLY TO LOW TEMP DRAINS (55 DEG AND LOWER IE: COOLING COIL CONDENSATE, ICE MACHINE DRAINS, ETC.)
GV - GREASE VENT	A 0.5", B 0.5", E 0.5"	A 0.5", B 0.5", E 0.5"	A 1", B 1", E 1"	A 1", B 1", E 1"				APPLY INSULATION ONLY WITHIN 10' OF EXTERIOR PENETRATION
HWC - HOT WATER CIRCULATING - POTABLE	A 1", B 1", E 1"	A 1", B 1", E 1"	A 1.5", E 1"	A 1.5", E 1"	C 1", E 1"	C 1", E 1"	C 1", E 1"	
MISC RELIEF, VENTS, INTAKES, AND DISCHARGES	A 0.5", B 0.5", E 0.5"	A 0.5", B 0.5", E 0.5"	A 1", B 1", E 1"	A 1", B 1", E 1"				APPLY INSULATION ONLY WITHIN 10' OF EXTERIOR PENETRATION ON COMPRESSOR INTAKES, VACUUM DISCHARGES, VENT/RELIEF LINES, ETC.
NOW - NON-POTABLE COLD WATER	A 0.5", B 0.5", E 0.5"	A 0.5", B 0.5", E 0.5"	A 1", B 1", E 1"	A 1", B 1", E 1"				
NHW - NON-POTABLE HOT WATER	A 1", B 1", E 1"	A 1", B 1", E 1"	A 1.5", E 1"	A 1.5", E 1"	C 1", E 1"	C 1", E 1"	C 1", E 1"	
RO - REVERSE OSMOSIS	A 0.5", B 0.5", E 0.5"	A 0.5", B 0.5", E 0.5"	A 1", B 1", E 1"	A 1", B 1", E 1"				
SAN - SANITARY DRAINAGE	A 0.5", B 0.5", E 0.5"	A 0.5", B 0.5", E 0.5"	A 1", B 1", E 1"	A 1", B 1", E 1"				APPLY INSULATION ONLY TO FLOOR DRAIN BODY, P-TRAP AND 10' DOWNSTREAM AT LOW TEMP DRAIN DISCHARGE (55 DEG AND LOWER IE: COOLING COIL CONDENSATE, ICE MACHINE DRAINS, ETC.)
SCW - SOFT COLD WATER	A 0.5", B 0.5", E 0.5"	A 0.5", B 0.5", E 0.5"	A 1", B 1", E 1"	A 1", B 1", E 1"				
SHW - SOFT HOT WATER	A 1", B 1", E 1"	A 1", B 1", E 1"	A 1.5", E 1"	A 1.5", E 1"	C 1", E 1"	C 1", E 1"	C 1", E 1"	
V - VENT	A 0.5", B 0.5", E 0.5"	A 0.5", B 0.5", E 0.5"	A 1", B 1", E 1"	A 1", B 1", E 1"				APPLY INSULATION ONLY WITHIN 10' OF EXTERIOR PENETRATION

AIR COMPRESSOR SCHEDULE

NOTES:
1. FURNISH WITH NO LOSS AUTOMATIC CONDENSATE DRAIN.

TAG NAME	AREA SERVED	CONFIGURATION	CAP. SCFM AT 100 PSI	RECEIVER CAPACITY (GAL.)	ELECTRICAL								MAX. DIMENSIONS			MANUFACTURER	MODEL	NOTES
					HP EACH	NO. OF POWER CONNECTIONS	VOLTAGE	PHASES	BY (NOTE A)	TYPE (NOTE B)	BY (NOTE A)	TYPE (NOTE C)	LENGTH	WIDTH	HEIGHT			
AC-1	LAUNDRY	SIMPLEX	3.3	30	1	1	120	1	MFR	NF	MFR	FV	42	16	37	QUINCY	QR-25 F210	NOTE 1

IMEG

www.imegcorp.com
IMEG CORP. RESERVES PROPRIETARY RIGHTS, INCLUDING COPYRIGHTS, TO THIS DRAWING AND THE DATA SHOWN THEREIN. SAID DRAWING AND/OR DATA ARE THE EXCLUSIVE PROPERTY OF IMEG CORP. AND SHALL NOT BE USED OR REPRODUCED FOR ANY OTHER PROJECT WITHOUT THE EXPRESS WRITTEN APPROVAL AND PARTICIPATION OF IMEG CORP. ©2024 IMEG CORP.

0 1 2 3
REF. SCALE IN INCHES PROJECT #21007888.00